

STANDARD MECHANICAL ABBREVIATIONS			
AF	AIRFOIL	ID	INSIDE(DIAMETER/DIMENSION)
AFF	ABOVE FINISHED FLOOR	IE	INVERT ELEVATION
AHP	APPARATUS HOUSING PLENUM	IN	INCH(ES)
ALT	ALTERNATIVE	INSUL	INSULATION
AL	ALUMINUM	ISOL	ISOLAT(OR)(ION)
APD	AIR PRESSURE DROP	KE	KITCHEN EQUIPMENT
APPROX	APPROXIMATELY	KW	KILOWATT
ARCH	ARCHITECT(URAL)	KWH	KILOWATT HOUR
AUTO	AUTOMATIC	L	LENGTH
BDD	BACKDRAFT DAMPER	LAT	LEAVING AIR TEMP
BI	BACKWARD INCLINED	LB	POUND
BLDG	BUILDING	LDB	LEAVING DRY BULB
BSMT	BASEMENT	LF	LINEAR FEET
BTU	BRITISH THERMAL UNIT	LFT	LEAVING FLUID TEMPERATURE
BTUH	BRITISH THERMAL UNITS PER HOUR	LVG	LEAVING
CFH	CUBIC FEET PER HOUR	LWB	LEAVING WET BULB
CFM	CUBIC FEET PER MINUTE	LWT	LEAVING WATER TEMPERATURE
CFS	CUBIC FEET PER SECOND	MAX	MAXIMUM
CLG	CEILING OR COILING	MBH	THOUSAND BTU PER HOUR
CONC	CONCRETE	MECH	MECHANICAL
CONN	CONNECT(ION)	MFR	MANUFACTURER
CONT	CONTINUE(ED)(UATION)	MIN	MINIMUM
CL	CENTERLINE	MISC	MISCELLANEOUS
DDC	DIRECT DIGITAL CONTROL	MTD	MOUNTED
DEFL	DEFLECTION	NC	NORMALLY CLOSED
DN	DOWN	NI	NOT IN CONTRACT
DND	DEW POINT	NO	NORMALLY OPEN
DWDI	DOUBLE WIDTH DOUBLE INLET	OAD	OUTSIDE AIR DAMPER
DWG	DRAWING	OC	ON CENTER DISTANCE
EA	EXHAUST AIR	OSA	OUTSIDE AIR
EAD	EXHAUST AIR DAMPER	PH	PHASE
EAT	ENTERING AIR TEMPERATURE	PP	POLYPROPYLENE
EDB	ENTERING DRY BULB	PSI	POUNDS PER SQUARE INCH
EFF	EFFICIENCY	PVC	POLYVINYL CHLORIDE
EFT	ENTERING FLUID TEMPERATURE	PVS	PVC COATED STEEL
ELEC	ELECTRIC(AL)	R (RAD)	RADIUS
ELEV	ELEVATION	RA	RETURN AIR
ENGR	ENGINEER	RAD	RETURN AIR DAMPER
EQ	EQUAL	REV	REVISION
EQUIP	EQUIPMENT	RH	RELATIVE HUMIDITY
ESP	EXTERNAL STATIC PRESSURE	RPM	REVOLUTIONS PER MINUTE
EWB	ENTERING WET BULB	SA	SUPPLY AIR
EWT	ENTERING WATER TEMPERATURE	SCFM	STANDARD CUBIC FEET PER MINUTE
EX	EXTRACTOR	SD	SMOKE DAMPER
EXH	EXISTING	SECT	SECTION
EXIST	EXISTING	SENS	SENSIBLE
EXP	EXPANSION	SIM	SIMILAR
F	DEGREES FAHRENHEIT	SP	STATIC PRESSURE
FC	FORWARD CURVED	SPEC	SPECIFICATION
FIG	FIGURE	SQ	SQUARE
FILT	FILTER	SF	SQUARE FOOT(FEET)
FLEX	FLEXIBLE	SQ IN	SQUARE INCH(ES)
FPD	FLUID PRESSURE DROP	SS	STAINLESS STEEL
FPM	FEET PER MINUTE	STL	STEEL
FPS	FEET PER SECOND	STRUCT	STRUCTUR(E)(AL)
FT	FEET/FOOT	SWP	SINGLE WALL PLENUM
FU	FIXTURE UNIT	SWSI	SINGLE WIDTH SINGLE INLET
FUT	FUTURE	TEMP	TEMPERATURE
FV	FACE VELOCITY	TSP	TOTAL STATIC PRESSURE
GA	GAGE/GAUGE	TYP	TYPICAL
GAL	GALLON	V	VOLTS
GALV	GALVANIZED	VD	VOLUME DAMPER
GLY	GLYCOL	VEL	VELOCITY
GPH	GALLONS PER HOUR	VERT	VERTICAL
GPM	GALLONS PER MINUTE	VTR	VENT THROUGH ROOF
H	HEIGHT	W	WIDTH
HORIZ	HORIZONTAL	WG	WATER GAUGE
HP	HORSEPOWER	WPD	WATER PRESSURE DROP
HTG	HEATING	W/	WITH
		W/O	WITHOUT

CONTROL SYMBOLS	
	DAMPER WITH OPERATOR
	2-WAY CONTROL VALVE
	3-WAY CONTROL VALVE
	DIGITAL OUTPUT FROM DDC PANEL
	DIGITAL INPUT TO DDC PANEL
	ANALOG OUTPUT FROM DDC PANEL
	ANALOG INPUT TO DDC PANEL
	DIFFERENTIAL PRESSURE SWITCH
	DAMPER END SWITCH
	TERMINAL UNIT (VAV OR CV)
	DUCT SMOKE DETECTOR
	WATER FLOW METER WITH ELECTRONIC TRANSMITTER
	PUSH BUTTON SWITCH
	ELECTRONIC HUMIDITY TRANSMITTER
	ELECTRONIC TEMPERATURE SENSOR
	FLOW SWITCH
	ELECTRONIC SENSOR WITH AVERAGING
	CARBON DIOXIDE SENSOR
	STATIC PRESSURE SENSOR
	CURRENT TRANSFORMER

HVAC PIPING			
	D	DRAIN (CONDENSATE/INDIRECT)	
	CHF	CHEMICAL FEED	
	ICW	INDUSTRIAL COLD WATER (MAKE-UP)	
	CHWS	CHILLED WATER SUPPLY	
	CHWR	CHILLED WATER RETURN	
	HWS	HEATING WATER SUPPLY	
	HWR	HEATING WATER RETURN	
	HWRR	HEATING WATER REVERSE RETURN	

DUCT DETAILS (LOW VELOCITY)			
	RADIUS ELBOW		TURNING VANES IN ALL ELBOWS & TEES
	FLEX CONNECTION		ACOUSTICAL LINER
	DUCT OFFSETS		TRANSITIONS
	RECTANGULAR DUCT FITTINGS		RECTANGULAR TO ROUND FITTINGS

CEILING SUPPLY DIFFUSERS(C-1,C-2)		
CFM RANGE	SQUARE NECK SIZE (BASED ON: TITUS PMC)	NOMINAL FACE SIZE C-1
0-200	6x6	24x24
201-270	8x8	24x24
271-345	10x10	24x24
346-500	12x12	24x24
501-780	15x15	24x24

NOTE: C-2 FACE SIZE EQUALS NECK SIZE PLUS 7-INCHES.

RETURN AIR GRILLES & REGISTERS(C-3)		
CFM RANGE	NECK SIZE (BASED ON: TITUS PAR)	NOMINAL FACE SIZE
0-1500	22x22	24x24

RETURN AIR GRILLES & REGISTERS(C-4)		
CFM RANGE	NECK SIZE (BASED ON: TITUS PAR)	NOMINAL FACE SIZE
0-340	10x10	12x12
341-680	14x14	16x16
681-1125	18x18	20x20
1126-1670	22x22	24x24

DUCT LEGEND			
	FLOW DIRECTION (NONE SHOWN IF 4-WAY)		FACE SIZE (SIDEWALL & FLOOR GRILLE) SIZE & NUMBER OF SLOTS (SLOT DIFFUSER)
	RETURN/EXHAUST SUPPLY		AIR QUANTITY
	SEE SPECS FOR TYPE		SEE SCHEDULE FOR SIZE
	CEILING DIFFUSERS & GRILLES		SIDEWALL, SLOTS & FLOOR GRILLES
	BOX TYPE & NUMBER		BOX TYPE SPECIFICATION REFERENCE
	TERMINAL UNITS		EQUIPMENT
	DUCT SECTIONS		DAMPERS
	LOW PRESSURE DUCTWORK		RETURN OR EXH. GRILLE CONNECTION
	SUPPLY DIFFUSER CONNECTION		SUPPLY DIFFUSER HARD CONNECTION
	MEDIUM PRESSURE DUCTWORK		SIDE WALL SUPPLY GRILLE CONNECTION
	BRANCH FITTINGS		SYMBOLS

MISC. VALVES & COCKS	
	SHUT-OFF VALVE
	CHECK VALVE
	2-WAY CONTROL VALVE
	3-WAY CONTROL VALVE
	BALANCING VALVE
	FLOW CONTROL VALVE
	SOLENOID VALVE
	PRESSURE REDUCING VALVE
	AIR VENT (MANUAL/AUTOMATIC)
	RELIEF VALVE
	STRAINER
	STRAINER W/ BLOWDOWN
	DRAIN VALVE
	HOSE BIBB
	WALL HYDRANT
	PRESSURE GAUGE
	PRESSURE/TEMPERATURE TEST PLUG
	THERMOMETER
	TEMPERATURE TRANSMITTER
	SHOCK ARRESTOR
	VACUUM BREAKER
	WATER FLOW METER
	REDUCED PRESSURE BACKFLOW PREVENTER
	BACKWATER VALVE
	OUTSIDE SCREW & YOKE
	WATER METER

MISC. FITTINGS & SYMBOLS	
	DIRECTION OF FLOW
	DIRECTION OF SLOPE
	PIPE SLEEVE
	REDUCER
	ANCHOR
	ELBOW (90°)
	ELBOW (45°)
	TEE
	CROSS
	JOINT OR COUPLING POINT
	UNION
	FLANGED CONNECTION
	CAP
	PLUG OR BLIND FLANGE
	RISER
	ELBOW UP
	ELBOW DOWN
	TEE UP
	TEE DOWN
	FLEXIBLE CONNECTION
	BALL JOINT
	MECHANICAL COUPLING

LEGENDS, SYMBOLS AND ABBREVIATIONS – MECHANICAL

PCC ROCK CREEK CAMPUS NEW BUILDING

PORTLAND COMMUNITY COLLEGE

ROCK CREEK CAMPUS

1763 NW Springdale Road

PORTLAND, OREGON 97264

(503) 227-1254

THOMAS HACKER ARCHITECTS INC.

733 SW OAK STREET

PORTLAND, OREGON 97205

(503) 227-1254

PAE CONSULTING ENGINEERS

808 SW THIRD AVENUE

PORTLAND, OREGON 97204


(503) 226-2921

EXPIRES 12-31-04

REVISIONS : 03/21/03

DATE : 02/14/03

SCALE : NONE

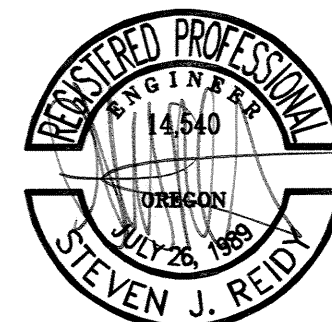

EXPIRES 12-31-04

DRAWN BY : TM

JOB NO. : 0115

DWG. NO. : M0.01

THOMAS HACKER ARCHITECTS INC.



TERMINAL UNIT SCHEDULE									
TERMINAL UNIT	TYPE	SERVICE AREA	INLET DIA. (IN)	SUPPLY CFM		HEATING CFM	HEATING COIL		NOTES
				MAX	MIN		MBH	GPM	
AHU-1									
TU-1-101	WR	ELECTRICAL	12	1,500	450	450	17.9	0.9	
TU-1-102	WR	EXECUTIVE DEAN	8	540	170	380	15.5	0.8	
TU-1-103	WR	ADMIN OFFICES	14	1,760	790	790	30.1	1.5	
TU-1-104	WR	DEAN OF STUDENTS	4	150	80	80	1.4	0.5	
TU-1-105	WR	DEAN OF INSTRUCTION	7	480	150	370	15.1	0.8	
TU-1-106	WR	CAREER CLASSROOM	10	980	480	480	7.8	0.5	②
TU-1-107	WR	CONFERENCE ROOM	7	460	150	480	7.2	0.5	
TU-1-108	WR	CORRIDOR	14	2,000	940	940	34.2	1.7	
TU-1-109	WR	STAFF WORKROOM	7	440	140	280	11.4	0.6	
TU-1-110	WR	PEN/PENCIL TESTING	12	1,380	660	660	11.0	0.6	①
TU-1-111	WR	EXTERIOR OFFICES	12	1,200	360	980	40.2	2.0	
TU-1-112	WR	HALLWAY	7	500	330	330	6.0	0.5	
TU-1-113	WR	CAREER CENTER	9	900	470	470	8.5	0.5	②
TU-1-114	WR	COMMONS	9	780	380	380	6.9	0.5	
TU-1-115	WR	COMMONS	8	600	380	380	6.9	0.5	
TU-1-116	WR	CONFERENCE ROOM	9	750	280	750	30.8	1.5	
TU-1-117	WR	COPY	5	250	80	80	1.3	0.5	
TU-1-118	WR	ADMISSIONS	6	300	110	110	2.0	0.5	
TU-1-119	WR	ADMISSIONS	14	2,000	600	800	32.6	1.6	
TU-1-120	WR	ADMISSIONS	12	1,520	570	800	32.6	1.6	
TU-1-121	WR	FINICIAL AID	10	950	320	320	5.8	0.5	
TU-1-122	WR	ADMIN. CORD. OFFICE	7	440	140	440	20.8	1.0	
TU-1-123	WR	CASHIER	10	1,100	330	1,100	50.0	2.5	①
TU-1-201	WR	A/V WORKROOM	8	530	180	180	3.3	0.5	
TU-1-202	WR	A/V WORKROOM	8	640	200	640	26.1	1.3	
TU-1-203	WR	ELEV. ELEC. IT	12	1,340	410	410	8.2	0.5	
TU-1-204	WR	CIRCULATION WORKROOM	12	1,270	390	1,270	52.0	2.6	
TU-1-205	WR	STAFF LOUNGE	5	230	100	100	1.8	0.5	
TU-1-206	WR	RESERVES	10	1,100	1020	1020	39.3	2.0	
TU-1-207	WR	CIRCULATION WORKROOM	9	795	430	430	7.8	0.5	
TU-1-208	WR	CONFERENCE ROOM	6	380	150	150	2.5	0.5	
TU-1-209	WR	READING AREA	9	735	420	420	7.6	0.5	
TU-1-210	WR	READING AREA	12	1,680	640	1160	47.5	2.4	①
TU-1-211	WR	REFERENCE OFFICE	7	420	140	420	22.1	1.1	
TU-1-212	WR	A/V GROUP	7	440	170	170	2.9	0.5	
TU-1-213	WR	EXTERIOR PERIODICAL	10	960	300	560	22.9	1.1	
TU-1-214	WR	PERIODICAL COLLECTION	7	460	310	310	5.6	0.5	
TU-1-215	WR	READING AREA	12	1,680	640	1160	47.5	2.4	
TU-1-216	WR	LOBBY	10	950	450	950	52.1	2.6	①②
TU-1-217	WR	COMP ROOM	6	400	220	400	24.7	1.2	
TU-1-218	WR	CONTROL ROOM	6	400	130	200	8.1	0.5	
TU-1-219	WR	GROUP STUDY	8	700	210	700	28.6	1.4	②
TU-1-220	WR	LEARNING CLASSROOM	12	1,200	670	670	25.2	1.3	②
AHU-2									
TU-2-101	WR	SHIPPING/RECEIVING	7	440	260	440	19.9	1.0	①
TU-2-102	WR	BOOKKEEPING	12	2,000	530	2,000	82.0	4.1	
TU-2-103	WR	BOOKKEEPING	12	1,400	870	870	15.6	0.8	
TU-2-104	WR	ELECTRIC ROOM	9	900	270	270	4.3	0.5	
TU-2-105	WR	TOILETS	8	770	310	310	5.5	0.5	
TU-2-106	WR	OFFICE	5	220	100	100	1.8	0.5	
TU-2-107	WR	LARGE CONFERENCE	14	1,760	1030	1030	16.6	0.8	
TU-2-108	W	ELEVATOR MACHINE ROOM	6	400	120	120	1.7	0.5	
TU-2-109	WR	RECEPTION HALL	12	2,090	660	2,090	85.5	4.3	①
TU-2-110	WR	FOOD PROCESSING	8	720	310	450	18.3	0.9	
TU-2-111	WR	LARGE CONFERENCE	14	1,760	1030	1030	16.6	0.8	
TU-2-112	WR	LARGE CONFERENCE	14	1,960	1000	1310	53.6	2.7	
AHU-3									
TU-3-201	WR	LIBRARY	14	1,920	1080	1080	18.6	0.9	①②
TU-3-202	WR	LIBRARY	14	1,940	590	1470	60.1	3.0	②
TU-3-203	WR	TOILETS	8	560	260	260	4.6	0.5	
TU-3-204	WR	IT/STORAGE	8	600	180	180	3.2	0.5	
TU-3-205	WR	GENERAL COLLECTION	8	720	480	480	8.6	0.5	
TU-3-206	WR	GENERAL COLLECTION	12	1,400	860	860	25.4	1.3	
TU-3-207	WR	EXTERIOR READING	10	1,100	360	730	29.7	1.5	
TU-3-208	WR	LARGE READING AREA	16	2,400	1060	1470	60.3	3.0	
TU-3-209	WR	LARGE READING AREA	16	2,300	1060	1470	60.3	3.0	
TU-3-210	WR	STUDY ROOMS	12	1,970	1930	1360	80.7	4.0	①
GENERAL NOTES:									
2. ENTERING AIR TEMPERATURE 55°F									
3. ALL HEATING COILS MUST MEET SUMMER CONDITIONS OF 120°F ENTERING WATER TEMP., LEAVING AIR TEMP. OF 75° & GPM AS INDICATED.									
4. PROVIDE MINIMUM OF 36" CLEARANCE IN FRONT OF CONTROL BOXES.									
NOTES:									
① 3-WAY CONTROL VALVE.									
② WRAP TERMINAL UNIT WITH DUCT SOUND CONTROL WRAP.									
ENTERING WATER TEMPERATURE 140°F LAT AND GPM AS INDICATED									
ENTERING WATER TEMPERATURE 120°F LEAVING AIR TEMPERATURE 75°F									
KEY									
VV = VARIABLE AIR VOLUME TERMINAL UNIT									
VVR = VARIABLE AIR VOLUME TERMINAL UNIT WITH REHEAT COIL.									
CVR = CONSTANT AIR VOLUME TERMINAL UNIT WITH REHEAT COIL.									
TU - X - XXX									
_____ TERMINAL UNIT NUMBER									
_____ FLOOR UNIT IS LOCATED ON									
_____ AIR HANDLER NUMBER									
_____ TERMINAL UNIT									

EVAPORATIVE CONDENSING CHILLERS																								
TAG NUMBER	ACTUAL CAPACITY (TONS)	CONDENSING TEMP (AMBIENT/WB)	EVAPORATOR				ELECTRICAL										INDUSTRIAL COLD WATER (ICW)		WEIGHT (LBS)	BASED ON:	NOTES			
			EWT F	LWT F	GPM	MAX WPD FT (wg.)	FOULING FACTOR	COMPRESSOR RLA		FAN FLA		UNIT MCA	VOLTS/Ø	CONTROL POWER KW/V/PH	KW/TON	EER	IPLV	UNIT HEAT TAPE MCA/V/PH						
								QTY.	RLA/COMP	QTY.	FLA/FAN											CKT 1	QTY.	SIZE
ECC-1	210	105/70	58	43	300	15	.00025	4	96.5	4	3.5	436	460/3	1.0/120/1	0.76	14.7	17.6	20/208/1	2	1"	16,000	McQuay EGR-220	①②③	
NOTES:			① PROVIDE SINGLE POINT POWER CONNECTION.				② SEE SPECIFICATIONS FOR UNIT VIBRATION ISOLATION.																③ PROVIDE ENCLOSED CHEMICAL TREATMENT SYSTEM.	

EXHAUST FANS											
TAG NUMBER	LOCATION	SERVICE	TYPE	CFM	TSP (in. wg)	FAN RPM	MOTOR		APPROX. WEIGHT (LBS)	BASED ON	NOTES
							HP	VOLTS/Ø			
EF-1	MECHANICAL ROOM	TOILET EXHAUST	INLINE	2,780	1.0	1,299	1.0	208/3	250	GREENHECK BSQ-160	①②
EF-2	MECHANICAL ROOM	STAFF LOUNGE	INLINE	480	0.75	1,760	0.33	120/1	150	GREENHECK BSQ-80	①②
NOTES: ① PROVIDE STARTERS AND DISCONNECTS. ② PROVIDE AUTOMATIC DAMPER.											

BOILERS												
TAG NUMBER	BOILER TYPE	INPUT CAPACITY MBH	OUTPUT CAPACITY MBH	SUPPLY TEMP F	RETURN TEMP F	GPM	MAX WPD (FT.)	FUEL TYPE	ELECTRICAL		BASED ON	NOTES
									VOLTS/Ø	FLA		
B-1	HIGH EFFICIENCY, CONDENSING	1,000	900	140	100	45	5	2 PSI NAT. GAS	120/1	20	AERCO KC-1000	①
B-2	HIGH EFFICIENCY, CONDENSING	1,000	900	140	100	45	5	2 PSI NAT. GAS	120/1	20	AERCO KC-1000	①
B-3	HIGH EFFICIENCY, CONDENSING	1,000	900	140	100	45	5	2 PSI NAT. GAS	120/1	20	AERCO KC-1000	①

NOTES: ① PROVIDE SINGLE MASTER BOILER CONTROL PANEL FOR ALL BOILERS.

TAG NUMBER	LOCATION	SERVICE	PUMP TYPE	FLOW GPM	HEAD (ft. wg)	EFF %	MOTOR			BASED ON	NOTES
							HP	VOLTS/Ø	RPM		
CHWP-1	MECHANICAL ROOM 225	ECC-1	IN-LINE	310	36	71%	5	460/3	1750	B&G SERIES 80 5x5x7	
CHWP-2	MECHANICAL ROOM 225	ECC-1	IN-LINE	310	36	71%	5	460/3	1750	B&G SERIES 80 5x5x7	
CHWP-3	MECHANICAL ROOM 225	BUILDING/AHU COILS	IN-LINE	310	92	71%	15	460/3	1750	B&G SERIES 80 3x3x9½B	VFD DRIVEN
CHWP-4	MECHANICAL ROOM 225	BUILDING/AHU COILS	IN-LINE	310	92	71%	15	460/3	1750	B&G SERIES 80 3x3x9½B	VFD DRIVEN
HWP-1	MECHANICAL ROOM 224	BOILER B-1	IN-LINE	45	25	40%	0.75	460/3	1750	B&G SERIES 80 2x2x7	
HWP-2	MECHANICAL ROOM 224	BOILER B-2	IN-LINE	45	25	40%	0.75	460/3	1750	B&G SERIES 80 2x2x7	
HWP-3	MECHANICAL ROOM 224	BOILER B-3	IN-LINE	45	25	40%	0.75	460/3	1750	B&G SERIES 80 2x2x7	
HWP-4	MECHANICAL ROOM 224	BUILDING PUMP	IN-LINE	135	88	65%	7.5	460/3	1750	B&G SERIES 80 2½x2½x9½B	VFD DRIVEN
HWP-5	MECHANICAL ROOM 224	BUILDING PUMP	IN-LINE	135	88	65%	7.5	460/3	1750	B&G SERIES 80 2½x2½x9½B	VFD DRIVEN
HWP-6	MECHANICAL ROOM 225	AHU-1 HEATING COIL	IN-LINE	30	18	36%	0.50	460/3	1750	B&G SERIES 80 1½x1½x7B	
HWP-7	MECHANICAL ROOM 234	AHU-2 HEATING COIL	IN-LINE	14.5	18	36%	0.33	120/1	1750	GRUNDFOS UP-43-75	
HWP-8	MECHANICAL ROOM 234	AHU-3 HEATING COIL	IN-LINE	17.9	18	36%	0.33	120/1	1750	GRUNDFOS UP-43-75	

GENERAL NOTES: 1. PROVIDE STARTERS AND DISCONNECTS FOR UNITS WITHOUT VFD DRIVES.

FIN TUBE RADIATORS									
ITEM	LOCATION	OUTPUT BTU/HR/LINEAR FOOT	WTD (F)	EWI (F)	GPM	FINS (PER FOOT)	SIZE	BASED ON	REMARKS
FTR-1	---	375	12	140	0.25	50	3/4x3/4	TRANE E3	INFORMATION PROVIDED IS FOR A SINGLE 4' SECTION, PROVIDE ENCLOSURE EXTENSIONS FOR PIPING AT ENDS.

CABINET UNIT HEATERS													
TAG NUMBER	TYPE	LOCATION	CAPACITY OUTPUT MBH	CFM	MOTOR			COIL			BASED ON	OPERATING WEIGHT LBS	REMARKS
					HP	VOLTS	PH	EWT F	GPM	MIN WTD F			
CUH-1	CABINET UNIT HEATER	SHIPPING/RECEIVING	20	340	1/16	120	1	140	2.0	40	TRANE FFCB040	120	
CUH-2	CABINET UNIT HEATER	VESTIBULE 137	20	340	1/16	120	1	140	2.0	40	TRANE FFBB040	120	①

GENERAL NOTES: 1. PROVIDE LOW VOLTAGE THERMOSTAT.

NOTES: ① PROVIDE 3-WAY CONTROL VALVE

DUCT SILENCERS						
TAG NUMBER	SERVICE	LENGTH (FT.)	S.P. DROP (IN.)	MODEL NUMBER	BASED ON:	DIMENSIONS
ST-1	AHU-1	5	0.15	IAC LFL	INDUSTRIAL ACOUSTIC COMPANY	60x24
ST-2	AHU-1	3	0.09	IAC L	INDUSTRIAL ACOUSTIC COMPANY	108x18
ST-3	AHU-3	3	0.14	IAC LFL	INDUSTRIAL ACOUSTIC COMPANY	84x18
ST-4	TU-3-201	3	0.10	IAC LFL	INDUSTRIAL ACOUSTIC COMPANY	24x12
ST-5	TU-3-202	3	0.10	IAC LFL	INDUSTRIAL ACOUSTIC COMPANY	24x12
ST-6	AHU-2	3	0.10	IAC L	INDUSTRIAL ACOUSTIC COMPANY	42x12
ST-7	AHU-2	3	0.10	IAC L	INDUSTRIAL ACOUSTIC COMPANY	48x18

GENERAL NOTES:

1. PROVIDE DUCTWORK TRANSITIONS TO ACCOMMODATE SOUND TRAP SIZE.

AIR SEPARATORS						
TAG NUMBER	LOCATION	SERVICE	GPM	MPD	BASED ON	NOTES
AS-1	SECOND FLOOR MECH ROOM	HEATING WATER SERVICE	135	2'	B&G RL-3	
AS-2	SECOND FLOOR MECH ROOM	CHILLED WATER SERVICE	300	2'	B&G RL-5	

ROOF VENTS							
TAG NUMBER	THROAT AREA (SQ.FT.)	THROAT SIZE	HEIGHT	NO. OF LOUVERS	SERVICE	BASED ON	NOTES
EAV-1	3.1	16x28	12¼"	4	HOISTWAY VENT	GREENHECK WRH	

GENERAL NOTES:

1. HEIGHT LISTED DOES NOT INCLUDE HEIGHT OF ROOF CURB.

ITEM	LOCATION	AREA SERVED	SUPPLY						COOLING COIL								HEATING COIL				RETURN						OPER WT LBS	REMARKS				
			AIRFLOW CFM	MIN OSA CFM	TSP IN WG	FAN RPM	BHP	VFD	MOTOR		EAT		LAT		MIN WTR	EWT F	COIL GPM	WPD FT WG	EAT	LAT	MIN WTD	EWT F	COIL GPM	AIRFLOW CFM	TSP IN WG	FAN RPM			BHP	VFD	MOTOR	
									HP	VOLT/PH	DB	WB	DB	WB																	HP	VOLT/PH
AHU-1	SOUTH 2ND FLOOR MECHANICAL ROOM	ADMIN/MEDIA	34,500	10,950	5.50	1,219	41.4	YES	50	460/3	80.6	64.5	52	52	16	43	165.7	18	55.3	70.0	40	140	27.6	32,000	1.25	494	10.0	YES	15	460/3	28,000	
AHU-2	NORTH 2ND FLOOR MECHANICAL ROOM	FIRST FLOOR	14,000	5,350	5.40	2,150	18.3	YES	20	460/3	80	65	52	52	16	43	69.6	18	52.1	70.0	40	140	13.6	12,000	1.50	1068	4.62	YES	7.5	460/3	15,000	
AHU-3	2ND FLOOR MECHANICAL ROOM	SECOND FLOOR	14,000	6,650	5.40	2,150	18.3	YES	20	460/3	83	65.5	52	52	16	43	77	18	47.6	70.0	40	140	17.0	12,500	1.50	1097	4.92	YES	7.5	460/3	15,000	

GENERAL NOTES:

1. UNITS MOUNTED ON CONCRETE CURBS, SEE VIBRATION ISOLATION SPECIFICATIONS FOR INTERNAL AND EXTERNAL ISOLATION REQUIREMENTS.
2. ALL SUPPLY AND RETURN FAN MOTORS TO BE 460 VOLT/3Ø WITH VARIABLE FREQUENCY DRIVES.
3. HEATING COILS BASED ON MAX FACE VELOCITY OF 650 FPM, 0.2 IN MAX (wg) APD, 140 F EWT AND 5 FT (wg) MAX WPD.
4. COOLING COILS BASED ON MAX FACE VELOCITY OF 500 FPM, 0.75 IN MAX (wg) APD AND 43 F EWT AND 18 FT(wg.) MAX WPD.
5. MINIMUM OSA CALCULATED BASED ON ASHRAE STANDARD 62.

SCHEDULES – MECHANICAL

PCC ROCK CREEK CAMPUS
NEW BUILDING

PORTLAND COMMUNITY COLLEGE
ROCK CREEK CAMPUS
17705 NW Springville Road
PORTLAND, OREGON 97229

THOMAS HACKER ARCHITECTS INC.
733 SW OAK STREET
PORTLAND, OREGON 97205
(503) 227-1254

PAE CONSULTING ENGINEERS
808 SW THIRD AVENUE
PORTLAND, OREGON 97204
(503) 226-2921

REVISIONS : 03/21/03

DATE : 02/14/03
SCALE : NONE

THOMAS HACKER
ARCHITECTS INC.



EXPIRES	12-31-04
DRAWN BY :	TM
JOB NO. :	0115

DWG. NO. **M**

DWG. NO.

MO.02






GENERAL NOTES:

1. INSULATE ALL UNDERGROUND CHILLED WATER SUPPLY PIPING.
ALL CHILLED WATER RETURN PIPING NOT TO BE INSULATED,
UNLESS OTHERWISE NOTED.

NOTES:

- ① COORDINATE PIPE ROUTING WITH OTHER UNDERGROUND SERVICE PIPING.
- ② PROVIDE A 12" PIPE SLEEVE IN FOOTING FOR ROUTING OF CHILLEDWATER
LINES INTO MECHANICAL ROOM, PROVIDE A 2" SLEEVE FOR ICW.

1 SITE PLAN — MECHANICAL
M1.01 1' = 20'-0"

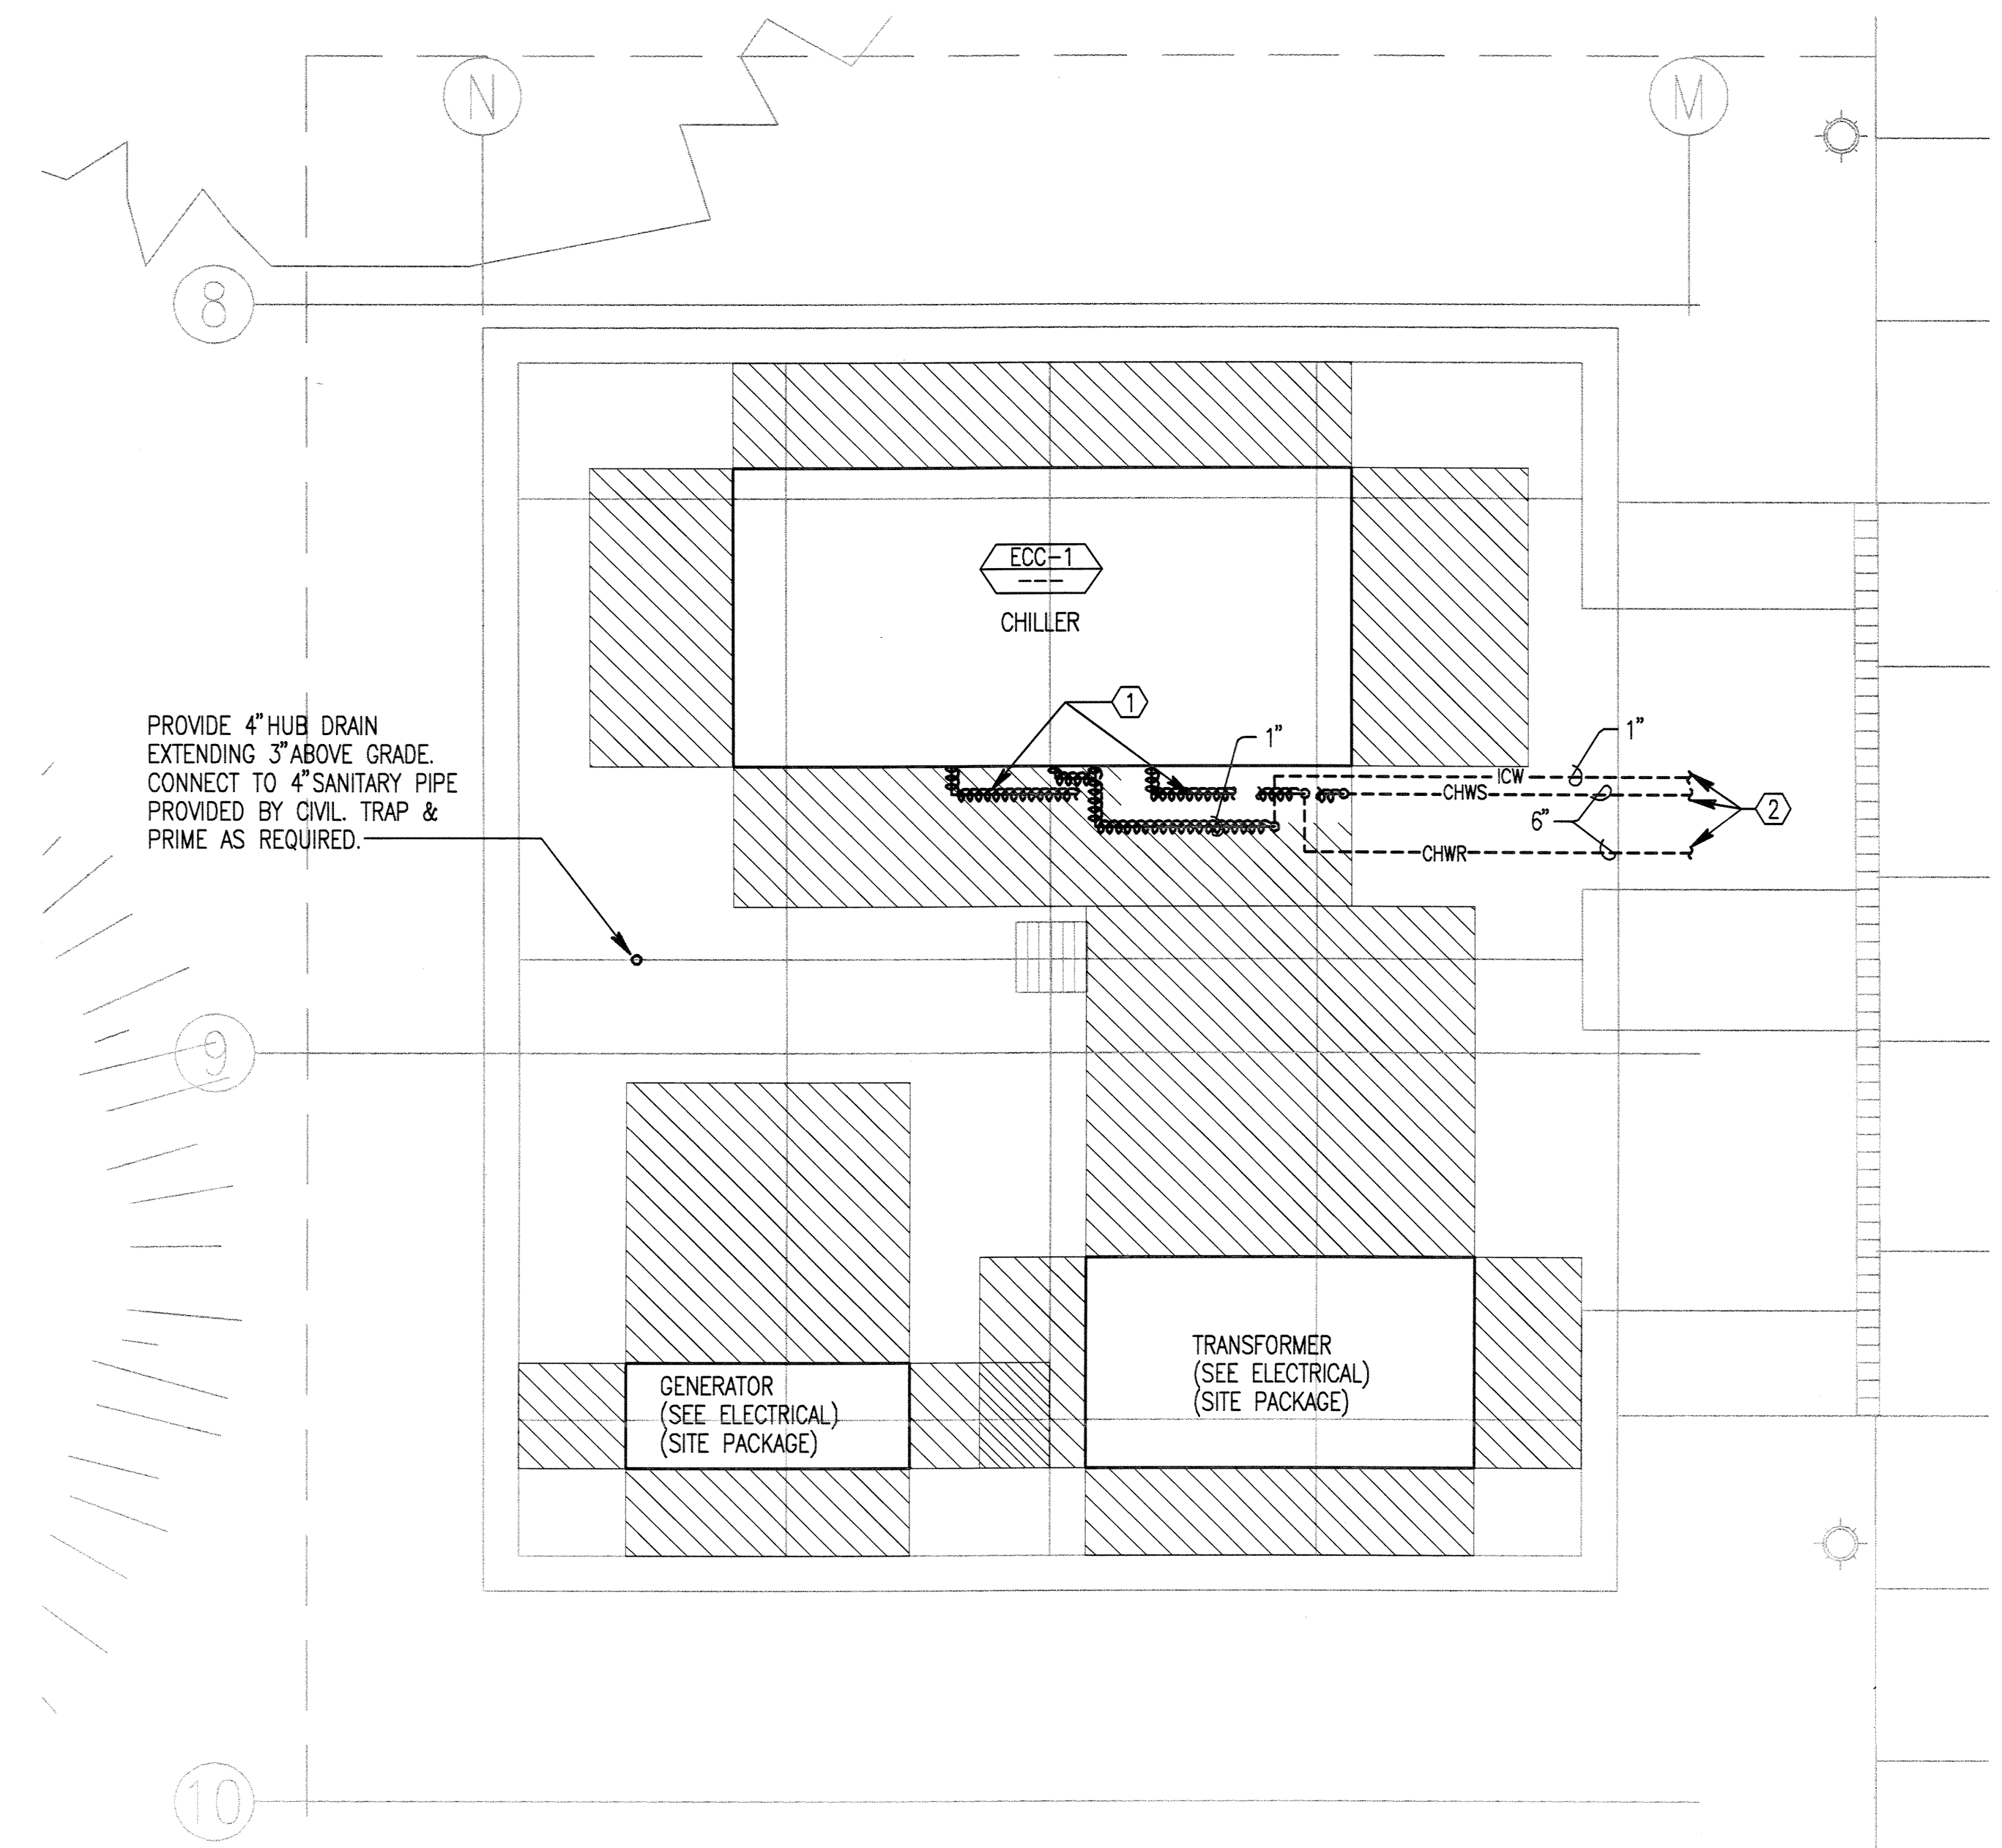

NOTES:

- ① CHILLED WATER AND COLD WATER PIPING TO BE RACKED SO ALL VALVES ARE ACCESSIBLE.
PROVIDE HEAT TRACING ON ALL EXTERIOR ABOVE GRADE PIPING.
- ② REFER TO 1/M101 FOR CONTINUATION.

2 TRASH ENCLOSURE — MECHANICAL
M1.01 1' = 1/4"

**SITE PLAN
MECHANICAL
PCC ROCK CREEK CAMPUS
NEW BUILDING**

PORTLAND COMMUNITY COLLEGE
ROCK CREEK CAMPUS
9702 NW Springdale Road
PORTLAND, OREGON 97229

THOMAS HACKER ARCHITECTS INC
733 SW OAK STREET
PORTLAND, OREGON 97205
503 222-0254

PAE CONSULTING ENGINEERS
808 SW THIRD AVENUE
PORTLAND, OREGON 97204
503 226-2921



REVISIONS : 3/21/03

DATE : 02/14/03
SCALE : AS SHOWN

EXPIRES 12-31-04
DRAWN BY : TM
JOB NO. : 0115

DWG. NO.

M1.01

**THOMAS HACKER
ARCHITECTS INC.**




GENERAL NOTES:

1. ALL BRANCH PIPING TO TERMINAL UNITS, CABINET UNIT HEATERS, AND UNIT HEATERS TO BE 3/4" UNLESS OTHERWISE NOTED.

NOTES:

1. 60 C-1
2. 60 C-3
3. 160 C-3
4. 230 C-3
5. 420 C-3
6. 260 C-4
7. 16x12
8. 450 C-3
9. CONNECT TO GRILLES BY OTHERS. SEE ARCHITECTURE DRAWINGS BALANCE TO 500 CFM EACH.
10. OPEN TO GRILLE FOR RETURN AIR TO CEILING. FOR GRILLE SEE ARCHITECTURAL DRAWINGS.
11. CONNECT TO GRILLE BY OTHERS. SEE ARCHITECTURAL DRAWINGS.
12. 300 C-1
13. PROVIDE ENCLOSURE EXTENSIONS TO HOUSE PIPING.
14. ROUTE DUCT OVER STRUCTURAL LID.
15. BLANK OFF 1" OF SLOT DIFFUSER. INSTALL SPECIFIED PLENUM BOOT OVER SLOT DIFFUSER.

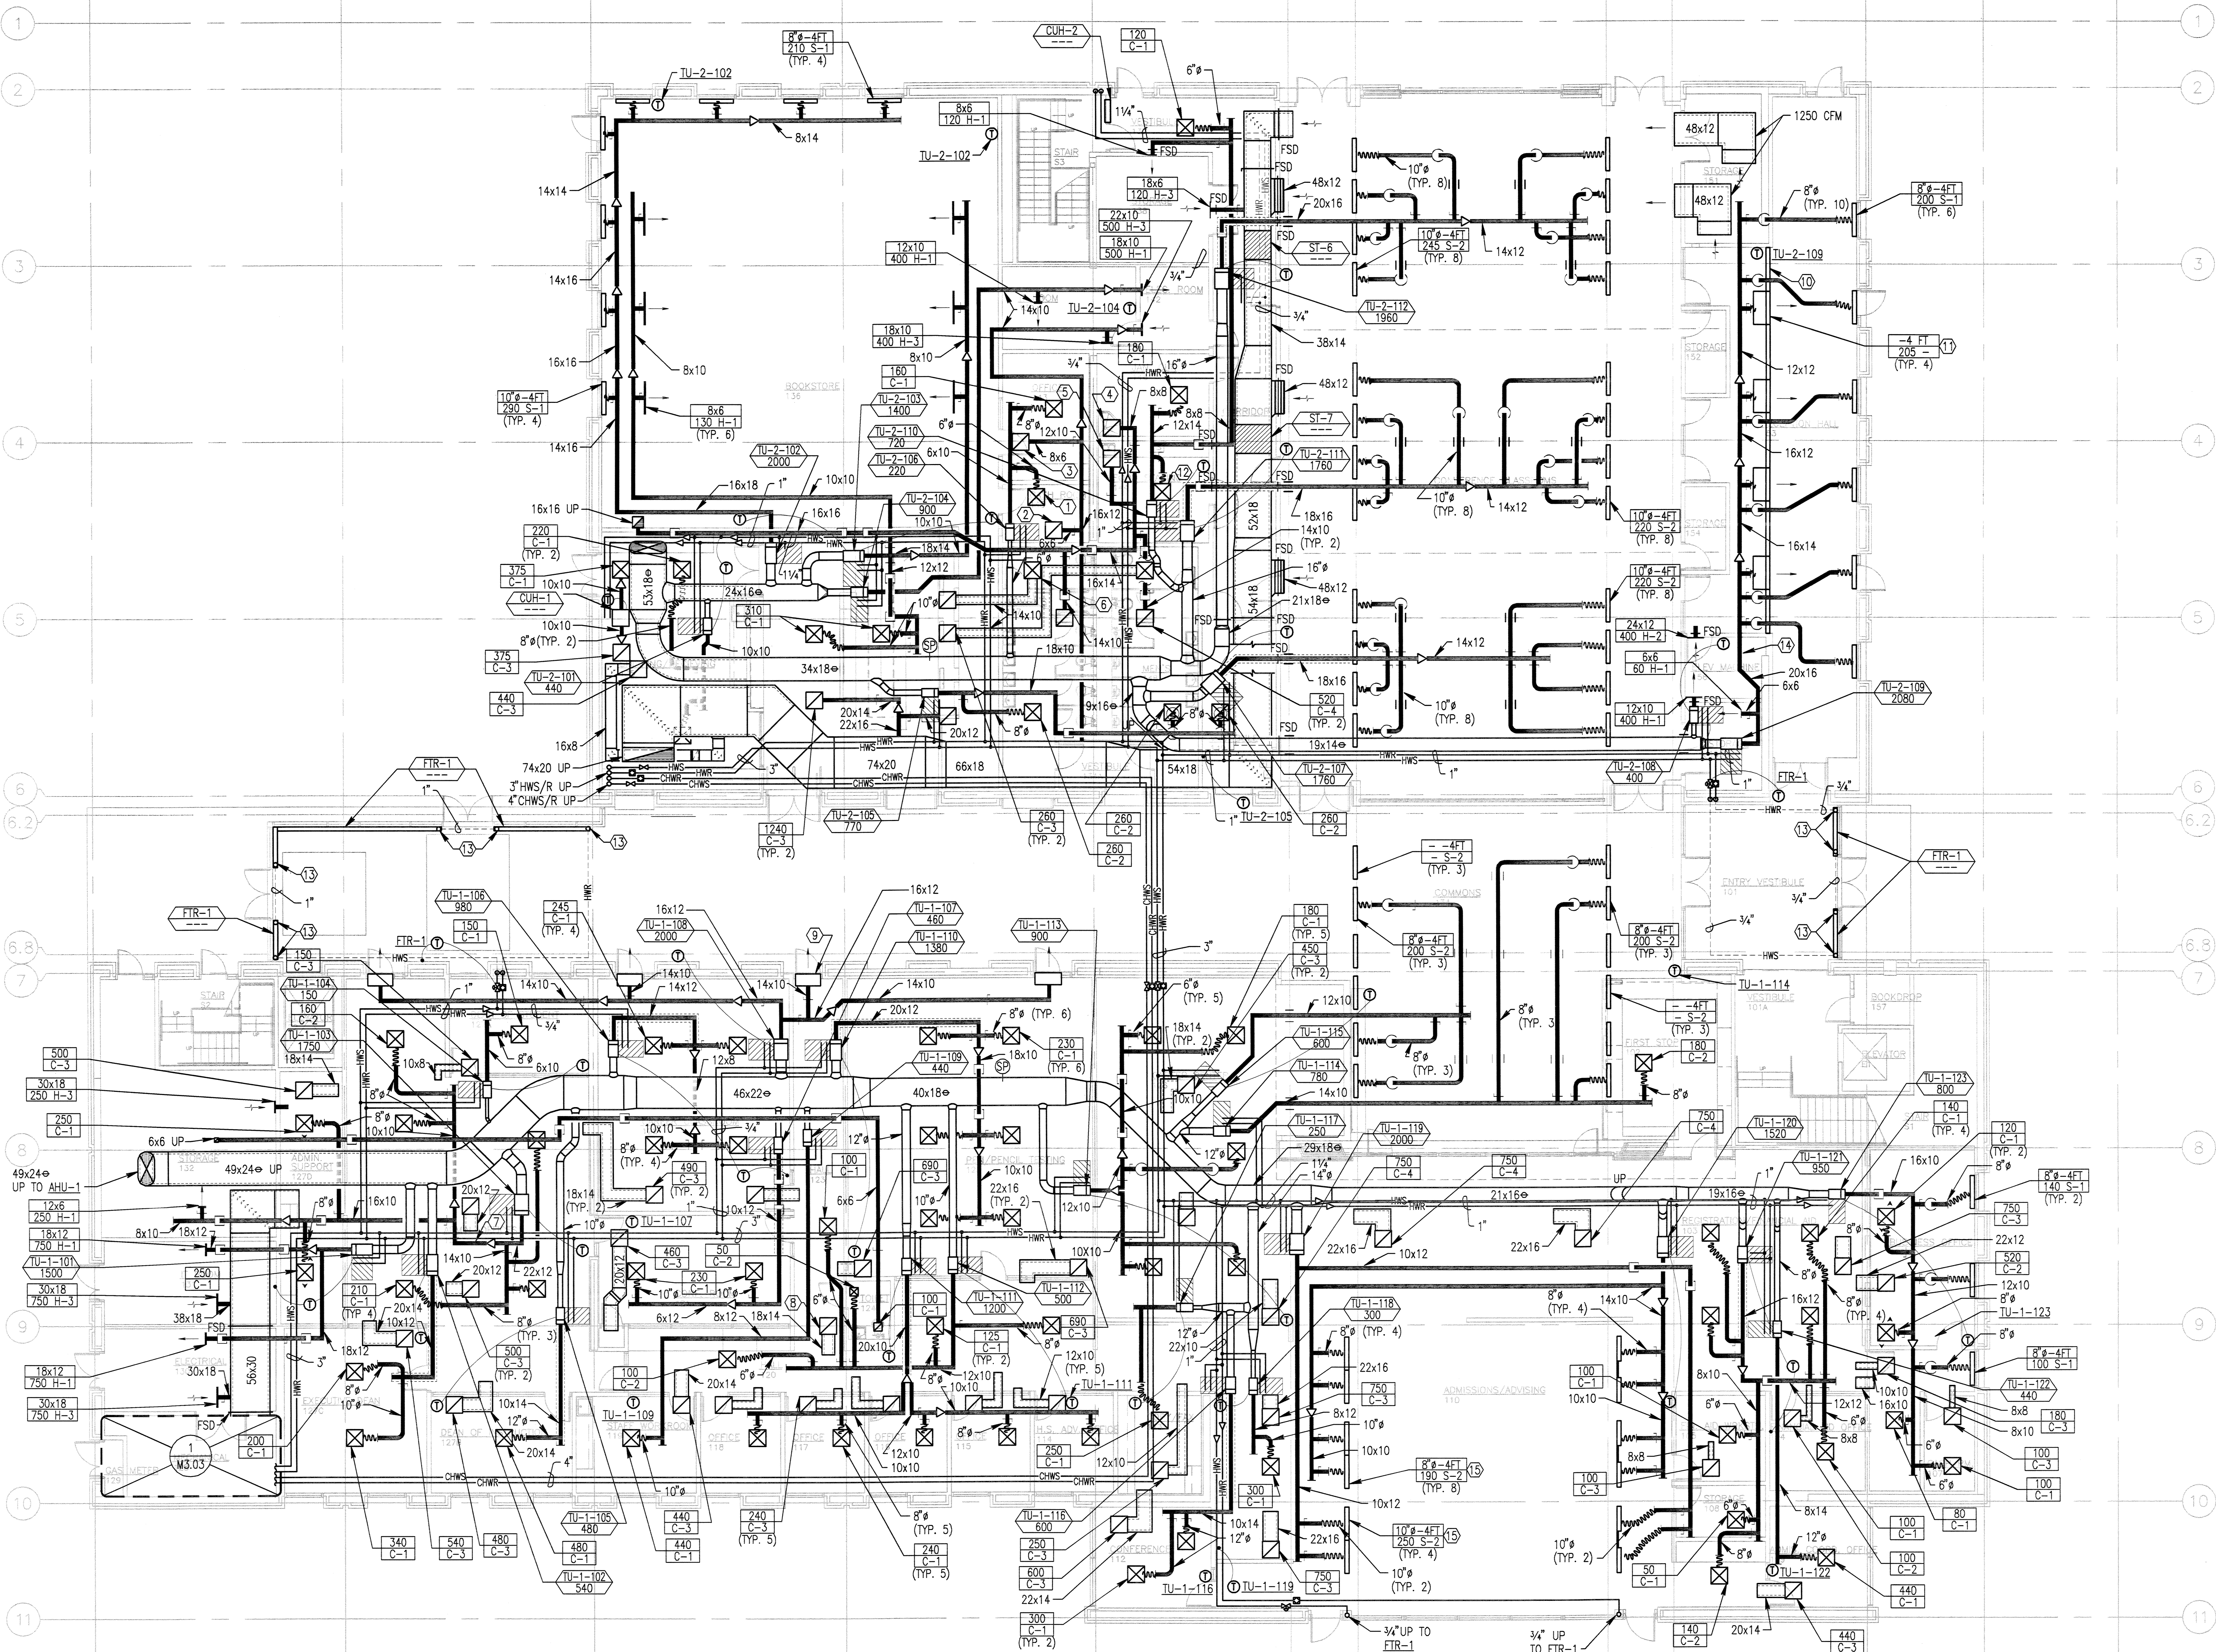

1 FIRST FLOOR PLAN -MECHANICAL
SCALE: 1/8" = 1'-0"

FIRST FLOOR PLAN HVAC
PCC ROCK CREEK CAMPUS NEW BUILDING

PORTLAND COMMUNITY COLLEGE
ROCK CREEK CAMPUS
5702 NW Springdale Road
PORTLAND, OREGON 97229

THOMAS HACKER ARCHITECTS INC.
723 SW OAK STREET
PORTLAND, OREGON 97205
503.227.2541

PAE CONSULTING ENGINEERS
806 SW THIRD AVENUE
PORTLAND, OREGON 97204
503.226.2921

REVISIONS : 1 03/21/03

DATE : 02/14/03
SCALE : 1/8" = 1'-0"




EXPIRES 12-31-04
DRAWN BY : TM
JOB NO. : 0115

DWG. NO.

M2.01

THOMAS HACKER ARCHITECTS INC.

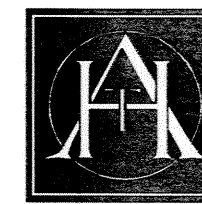


GENERAL NOTES:

- ALL BRANCH PIPING TO TERMINAL UNITS, CABINET UNIT HEATERS, AND UNIT HEATERS TO BE 3/4" UNLESS OTHERWISE NOTED.

NOTES:

- 3 - 30x8 LINED DUCTS. CONNECT TO ARCHITECTURAL GRILLE. RISE UP INTO STRUCTURE WITH 2" OFFSET.
- 2"x10" RETURN AIR SECTION.
- 3"x10" RETURN AIR SECTION.
- 5"x10" RETURN AIR SECTION.
- RUNNING CONTROL WIRE AND CONDUIT. CONNECT TO OPERABLE WINDOW ACTUATOR CONDUIT BY DIV 16.
- HOLD TIGHT TO STRUCTURE.

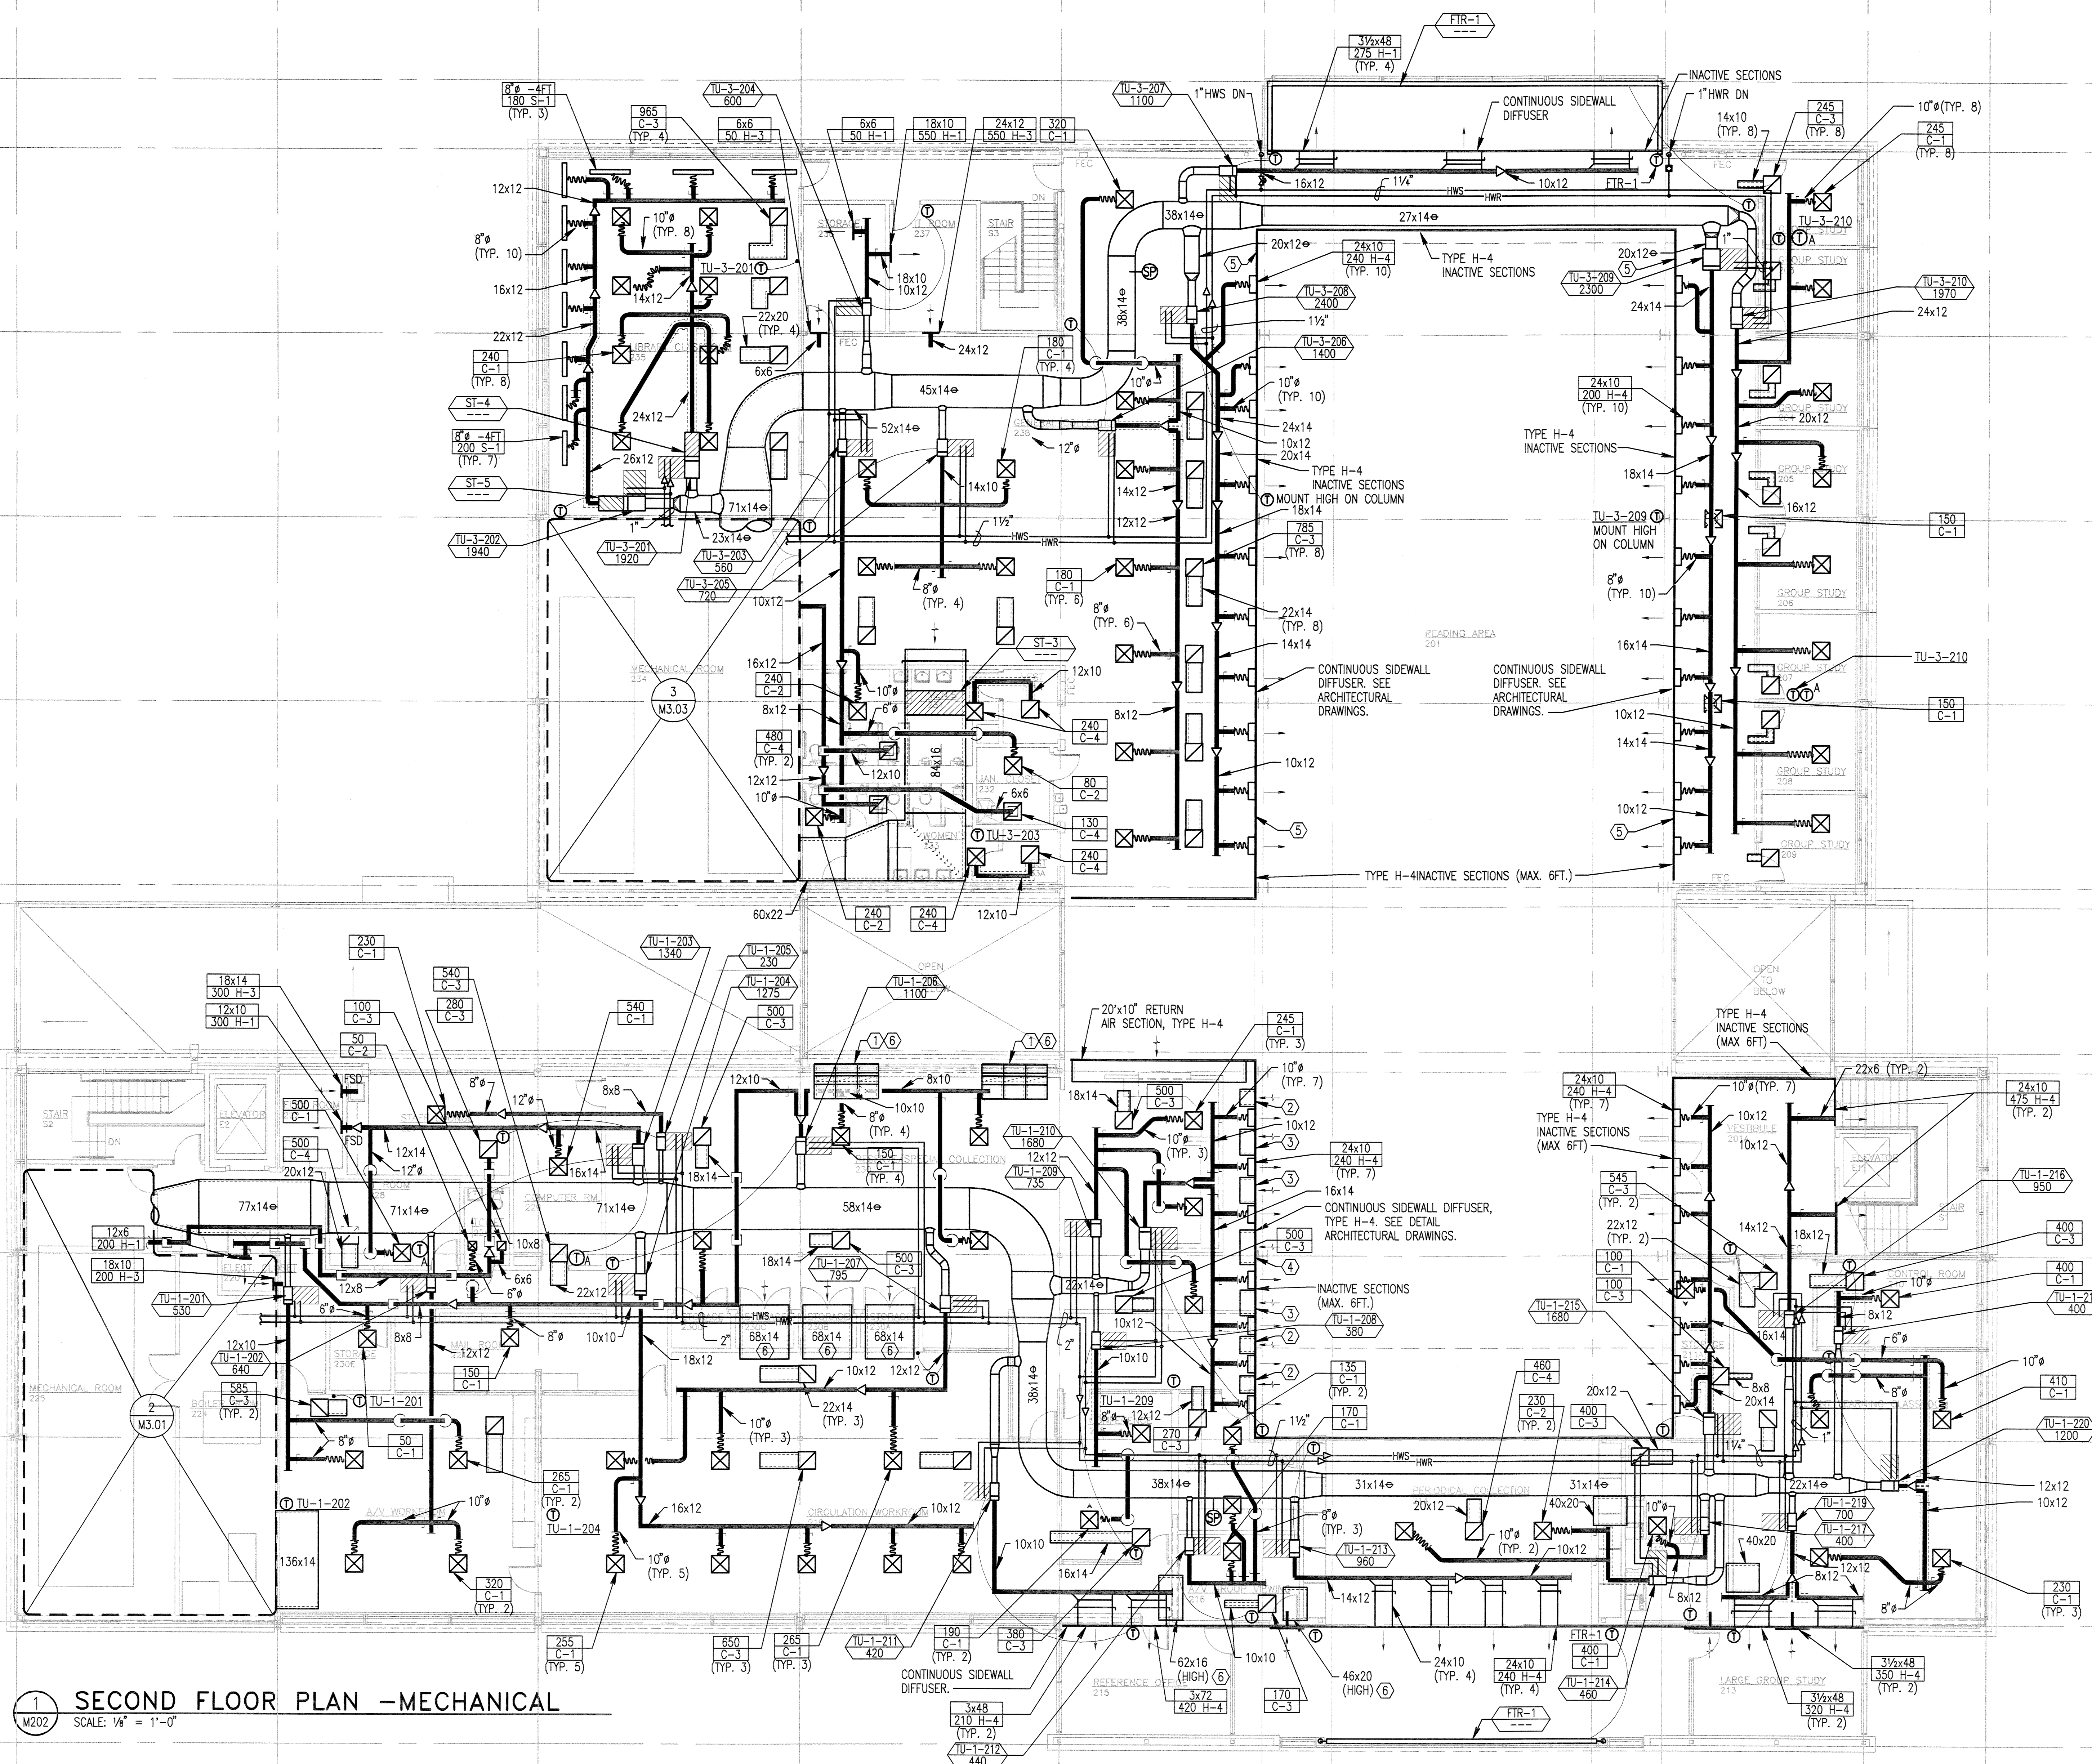

1 SECOND FLOOR PLAN -MECHANICAL
M202 SCALE: 1/8" = 1'-0"

1 SECOND FLOOR PLAN -MECHANICAL
M202 SCALE: 1/8" = 1'-0"

SECOND FLOOR PLAN HVAC

PCC ROCK CREEK CAMPUS NEW BUILDING

PORTLAND COMMUNITY COLLEGE
ROCK CREEK CAMPUS
3705 NW Springville Road
PORTLAND, OREGON 97204

THOMAS HACKER ARCHITECTS INC.
733 SW OAK STREET
PORTLAND, OREGON 97205
(503) 227-1254

PAE CONSULTING ENGINEERS
808 SW THIRD AVENUE
PORTLAND, OREGON 97204
(503) 226-2821

REVISIONS : 1 03/21/03

DATE : 02/14/03
SCALE : 1/8" = 1'-0"



EXPIRES 12-31-04
DRAWN BY : TM
JOB NO. : 0115

DWG. NO.


M2.02

THOMAS HACKER ARCHITECTS INC.




1 ROOF PLAN - MECHANICAL
SCALE: 1/8" = 1'-0"


ROOF PLAN
HVAC
PCC ROCK CREEK CAMPUS
NEW BUILDING
PORTLAND COMMUNITY COLLEGE
ROCK CREEK CAMPUS
17025 NW Sanguine Road
PORTLAND, OREGON 97229
THOMAS HACKER ARCHITECTS INC
733 SW GAIN STREET
PORTLAND, OREGON 97205
503.227.1254
PAE CONSULTING ENGINEERS
808 SW THIRD AVENUE
PORTLAND, OREGON 97204
503.226.2921

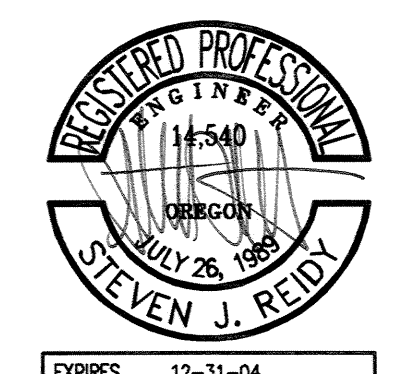

REVISIONS :
DATE : 02/14/03
SCALE : NONE
DRAWN BY :
JOB NO. : 0115
DWG. NO. : M2.03


THOMAS HACKER
ARCHITECTS INC.

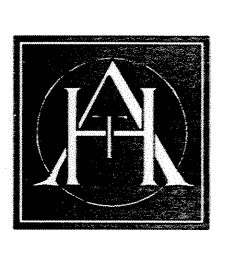

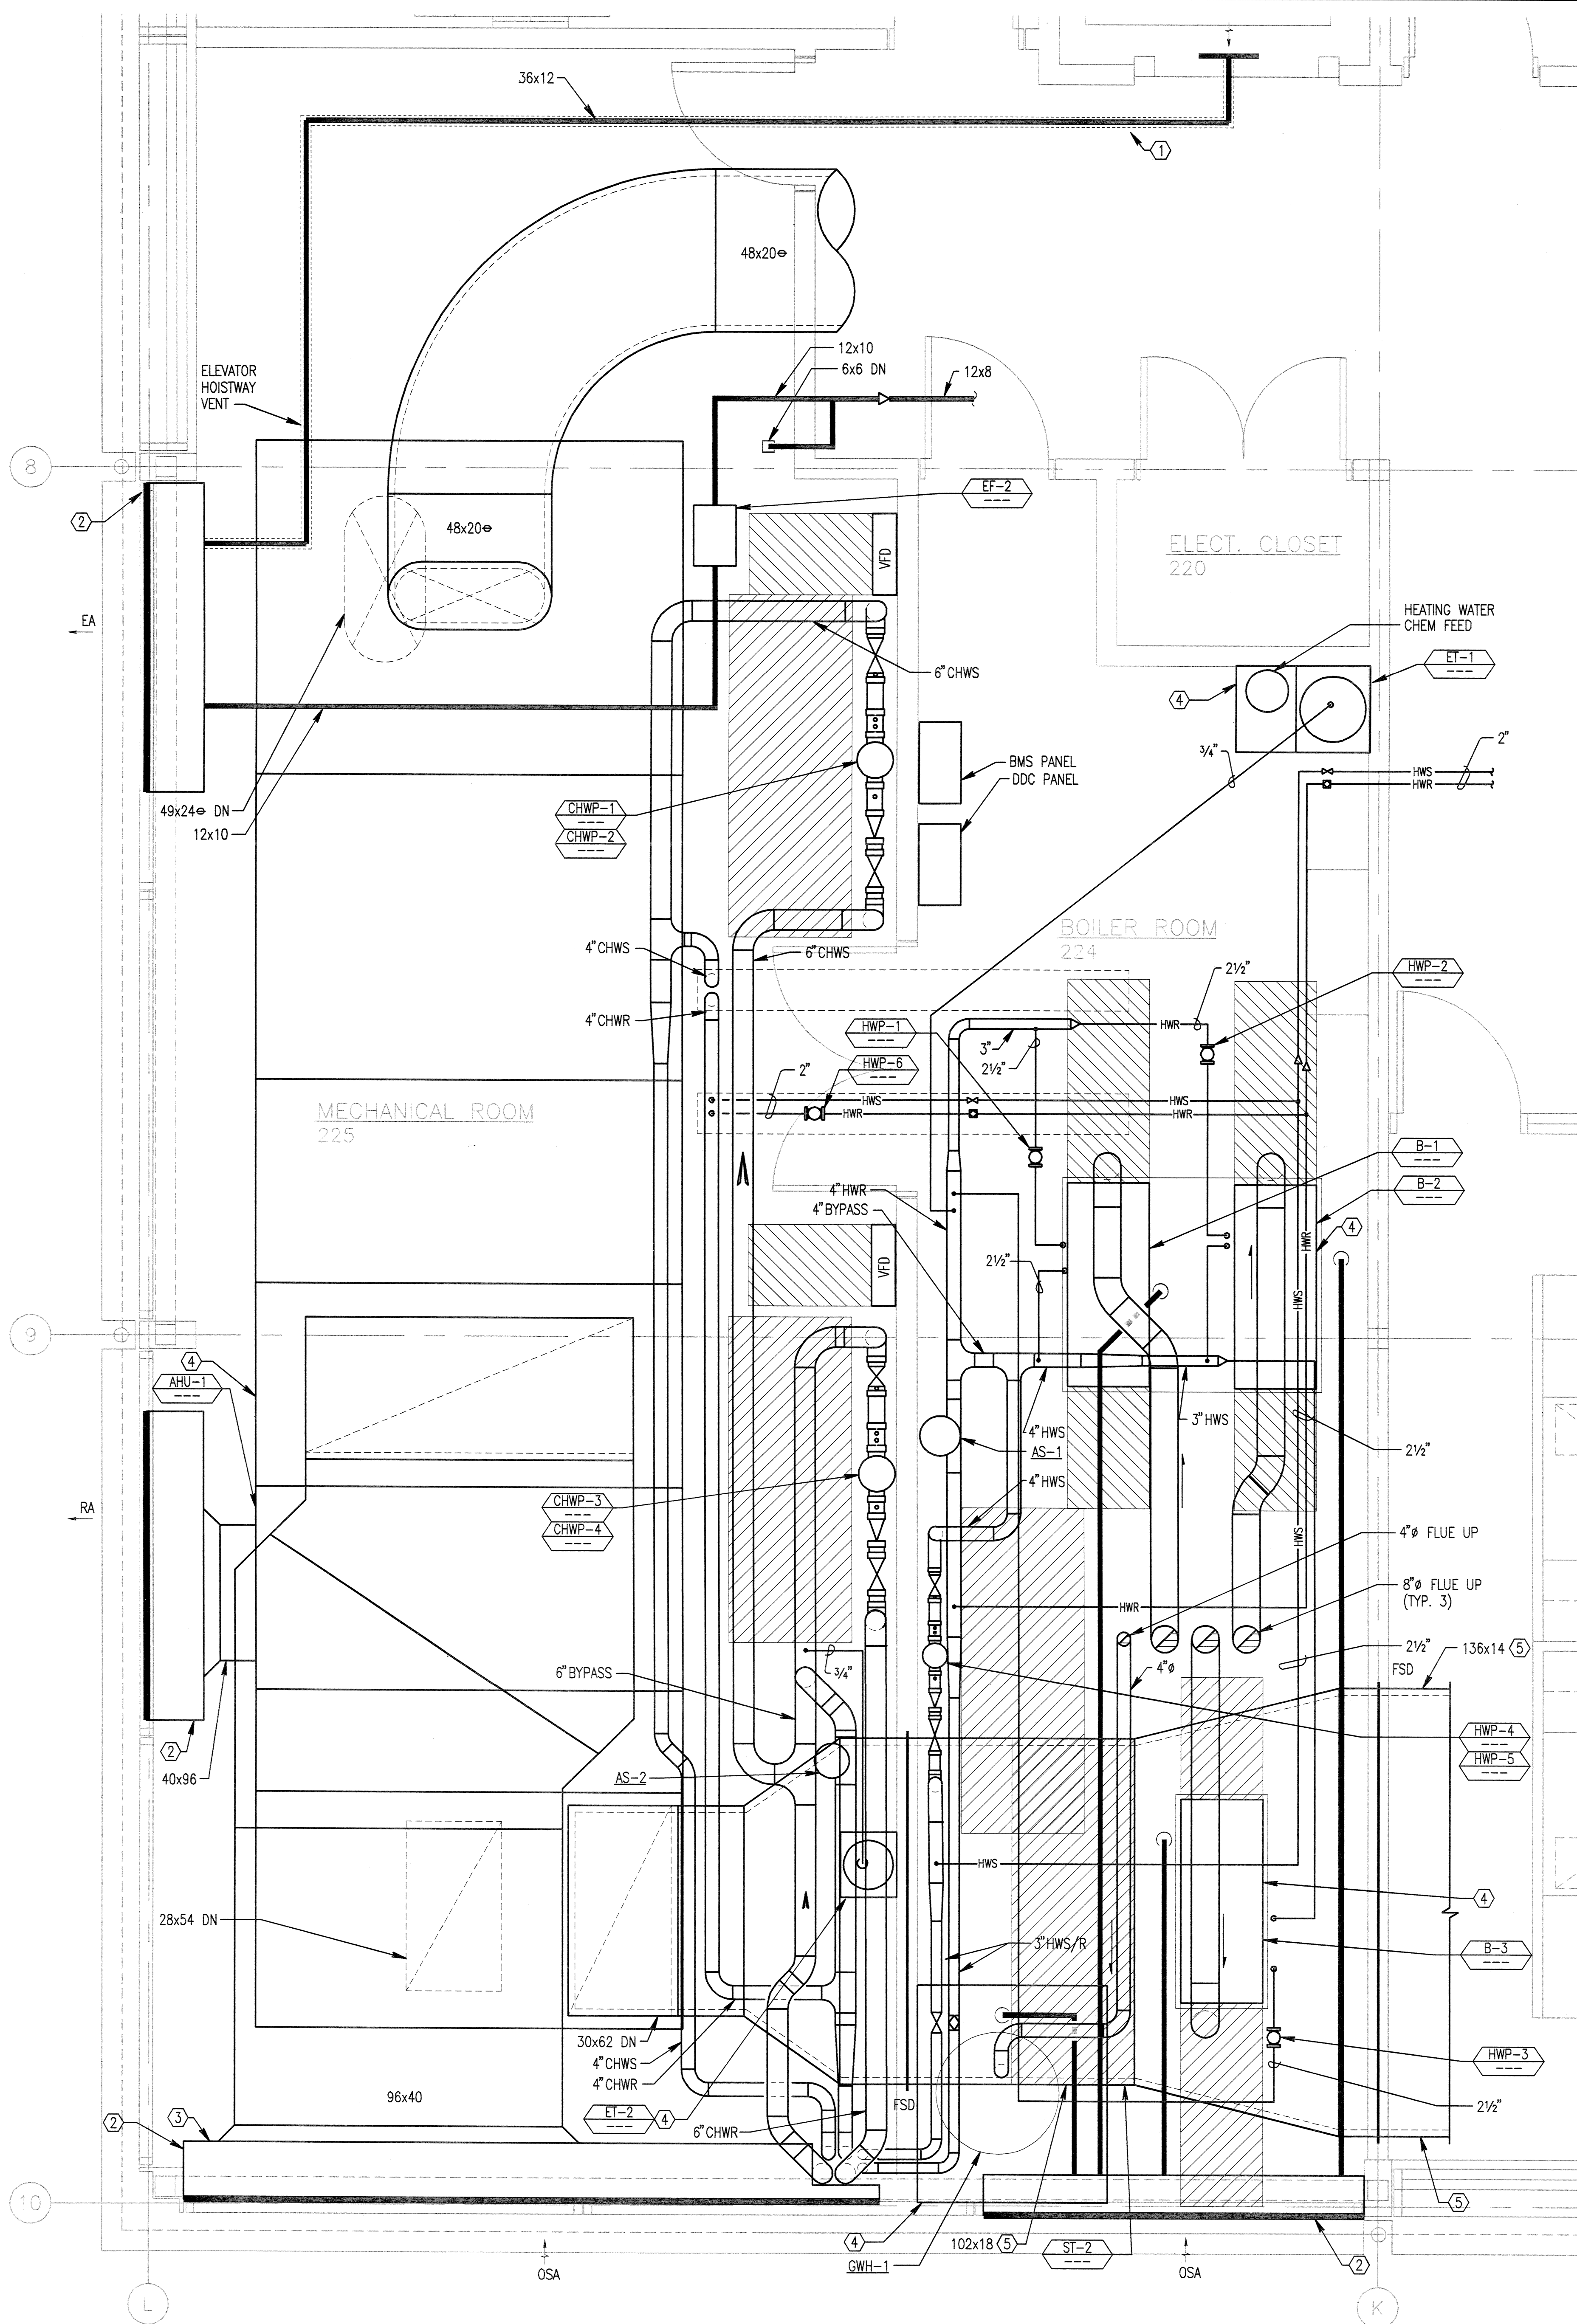

1 SECOND FLOOR MECHANICAL ROOM - HVAC
SCALE: 1/2" = 1'-0"

- NOTES:
- 1 WRAP HOISTWAY DUCT WITH 2-HR FIRE WRAP
 - 2 PROVIDE 18" DEEP PLENUM AT BACK OF LOUVER. SLOPE TO LOUVER DRAIN POINT. COORDINATE PLENUM LOCATION WITH FINISHED WALL.
 - 3 CONNECT DUCT TO BACK OF PLENUM.
 - 4 HOUSEKEEPING PAD
 - 5 RUN DUCT ABOVE ALL PIPING & EQUIPMENT

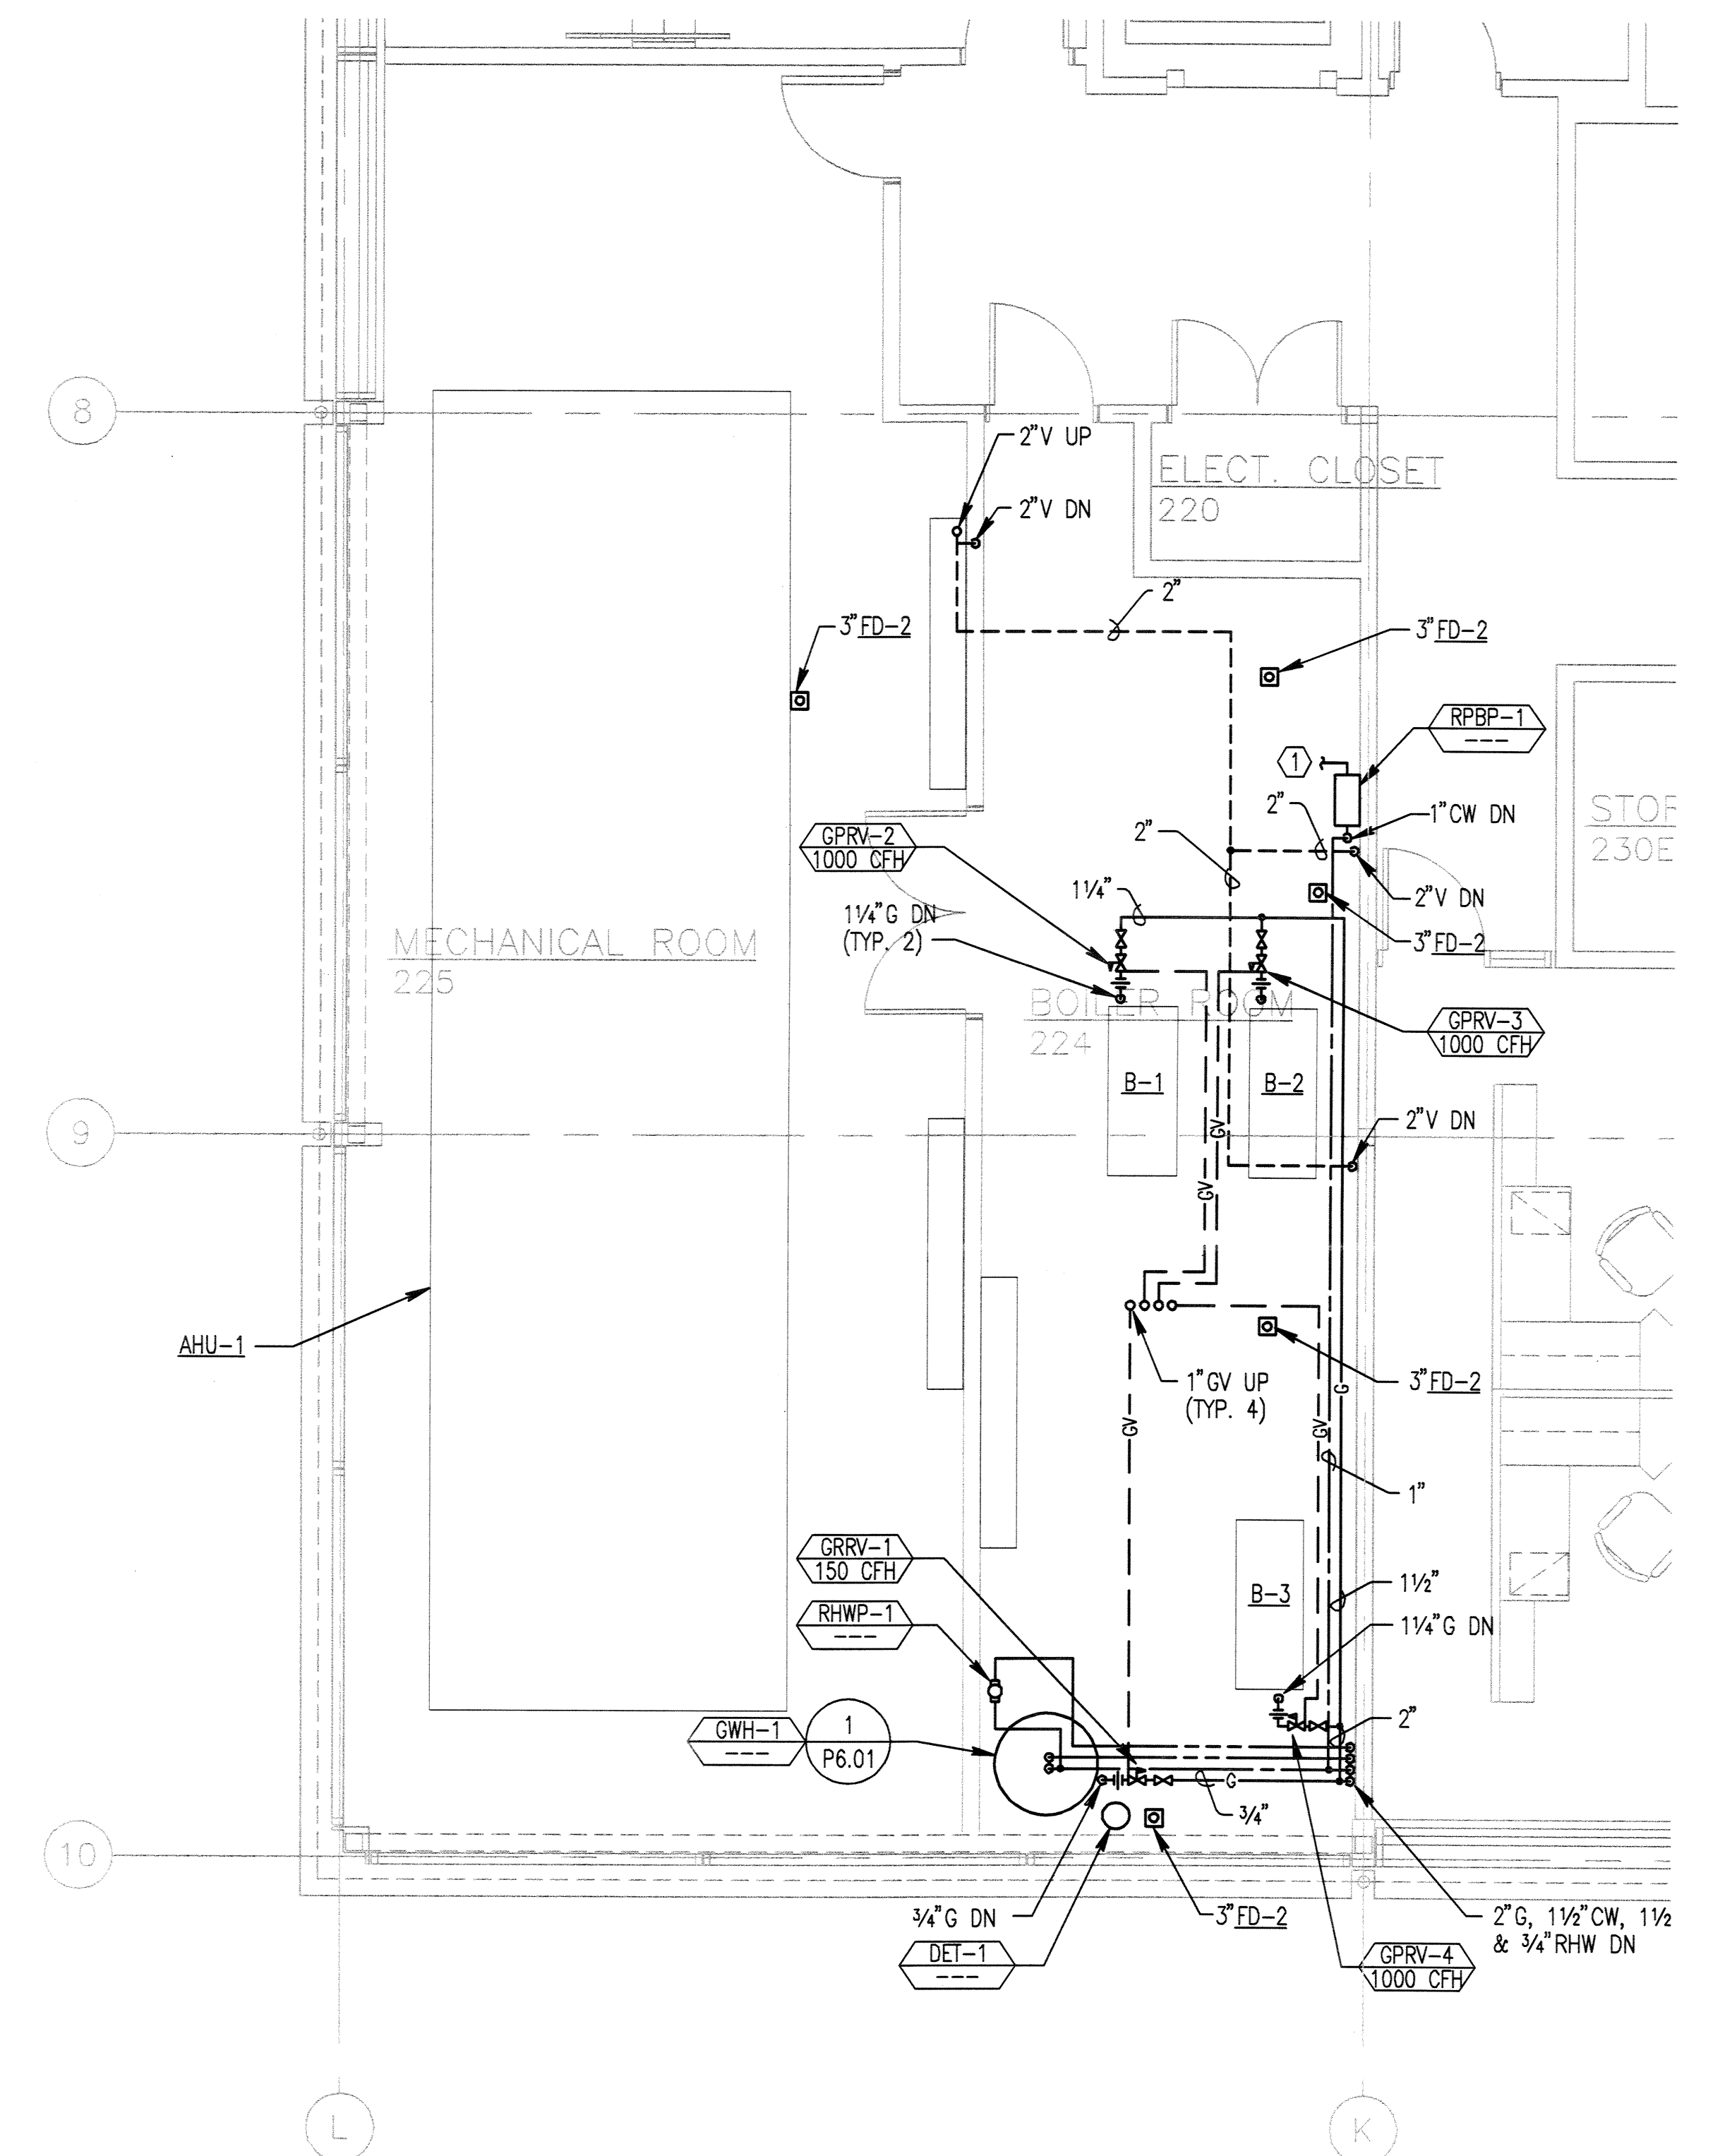

- NOTES:
- 1 SEE DETAIL 2/M6.02 FOR CONNECTION TO HEATING WATER AND CHILLED WATER MAKE-UP.

2 SECOND FLOOR MECHANICAL ROOM - PLUMBING
SCALE: 1/4" = 1'-0"

PARTIAL PLANS
HVAC
PCC ROCK CREEK CAMPUS
NEW BUILDING
PORTLAND COMMUNITY COLLEGE
ROCK CREEK CAMPUS
1700 NW Springville Road
PORTLAND, OREGON 97229

THOMAS HACKER ARCHITECTS INC.
733 SW OAK STREET
PORTLAND, OREGON 97205
(503) 227-1254
PAE CONSULTING ENGINEERS
808 SW THIRD AVENUE
PORTLAND, OREGON 97204
(503) 226-2921



REVISIONS : 03/21/03

DATE : 02/14/03
SCALE : N/A


EXPRES 12-31-04
DRAWN BY : TM
JOB NO. : 0115

DWG. NO.

M3.01

THOMAS HACKER
ARCHITECTS INC.




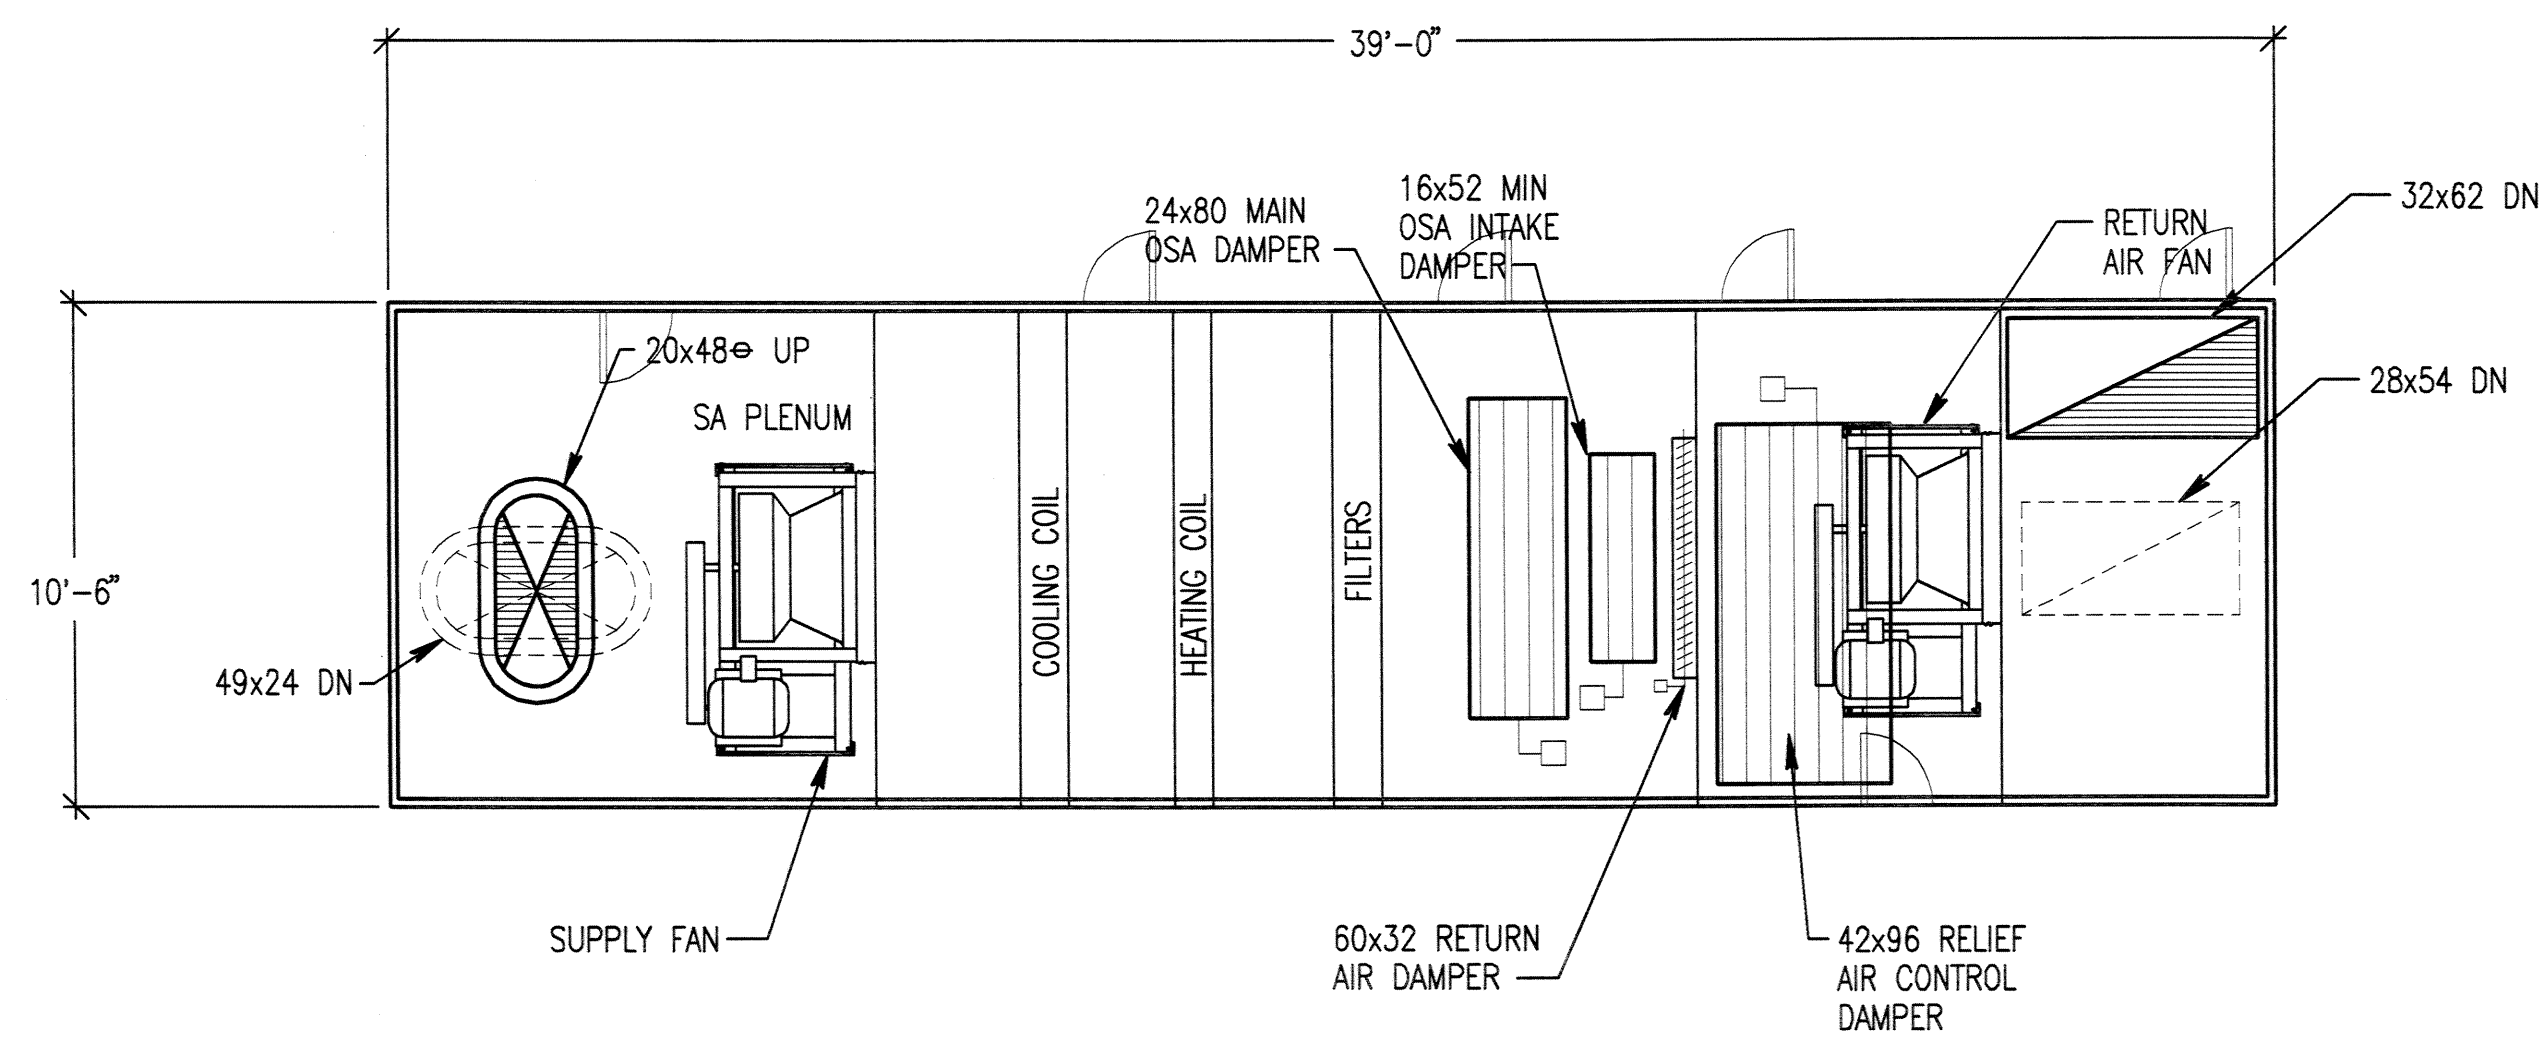

GENERAL NOTES:

1. UNIT TO BE MINIMUM 7' TALL, FROM UNIT FLOOR TO INSIDE OF UNIT ROOF
2. RETURN AIR DAMPER AND OSA DAMPER TO BE PARRALLEL BLADE. ANGLE OSA DAMPER BLADES TOWARDS RETURN AIR DAMPER. ANGLE RETURN AIR DAMPER TOWARDS OSA DAMPE.
3. RELIEF AIR DAMPER TO BE OPPOSED BLADE.
4. COORDINATE DUCT OPENING LOCATIONS IN UNIT WITH STRUCTURAL FLOOR PENETRATIONS.


1 AHU-1 PLAN - 2ND FLOOR MECHANICAL ROOM # 225
SCALE: 1/4" = 1'-0"

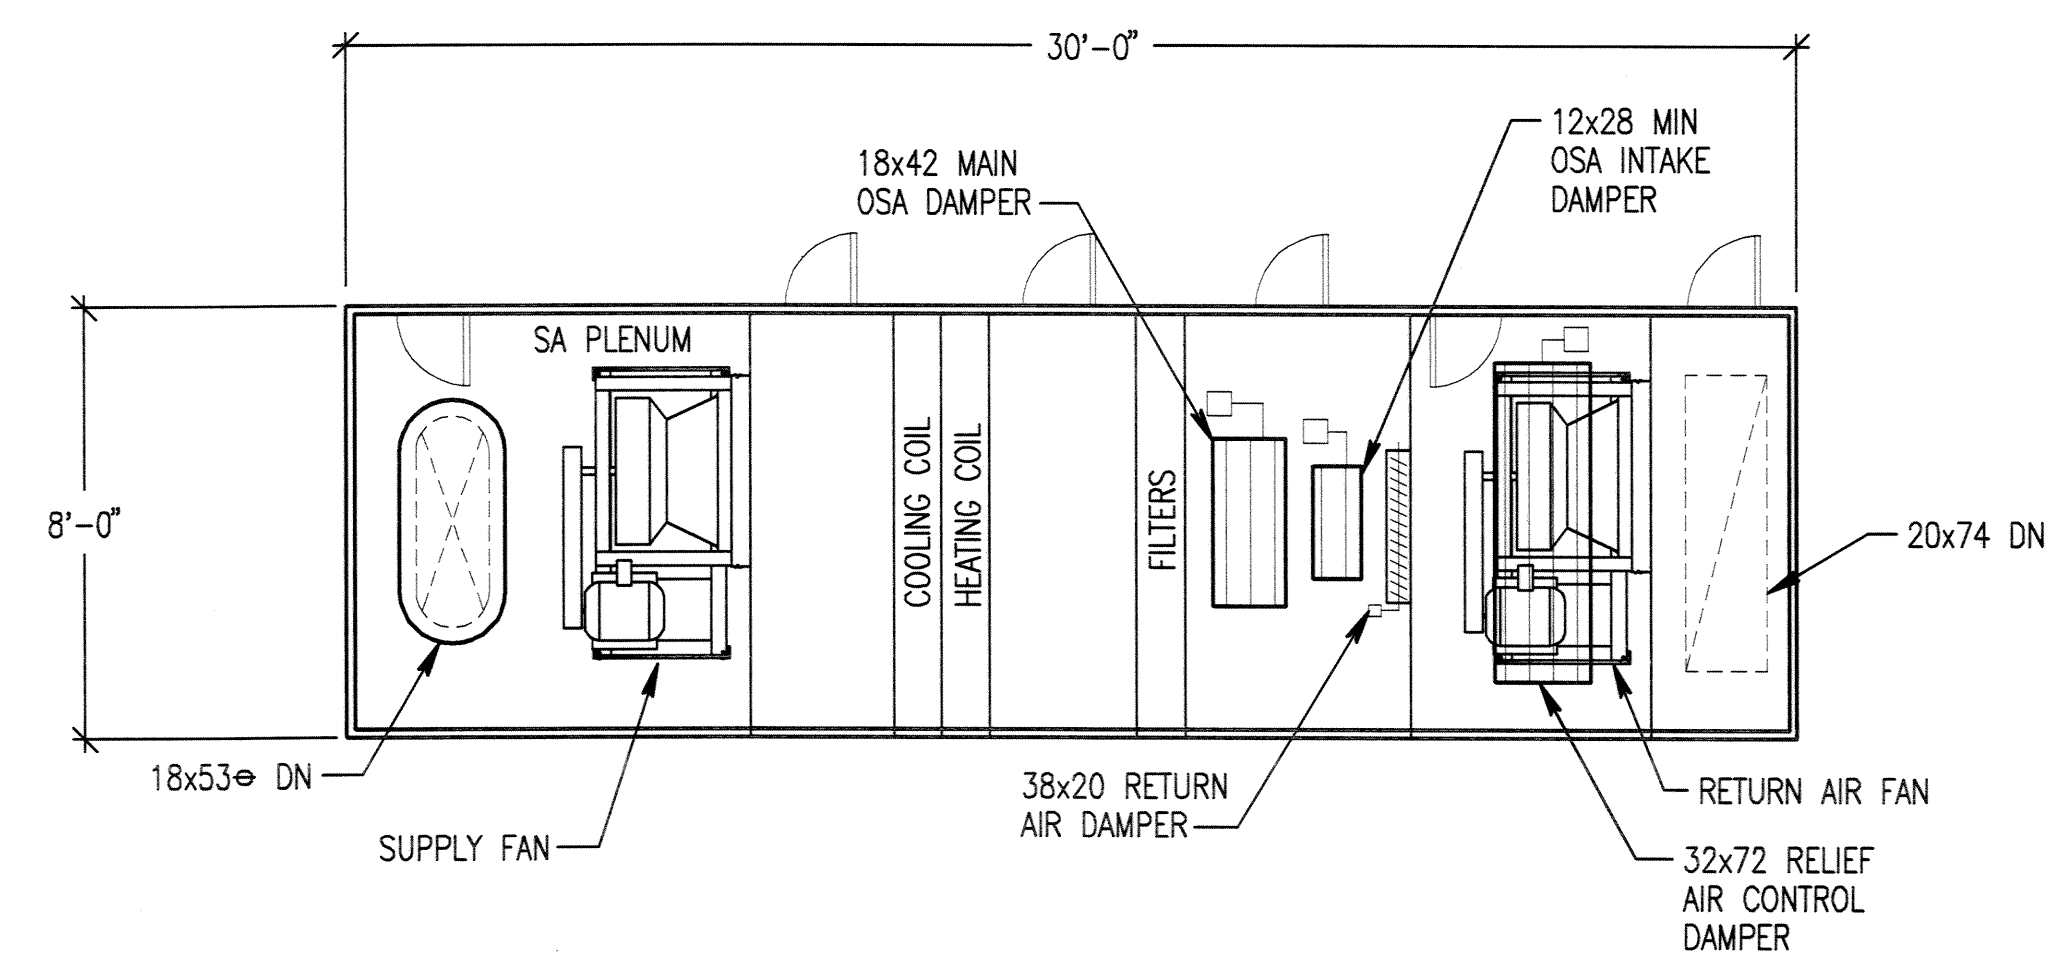

GENERAL NOTES:

1. UNIT TO BE MINIMUM 7' TALL, FROM UNIT FINISHED FLOOR TO INSIDE OF UNIT ROOF
2. RETURN AIR DAMPER AND OSA DAMPER TO BE PARRALLEL BLADE. ANGLE OSA DAMPER BLADES TOWARDS RETURN AIR DAMPER. ANGLE RETURN AIR DAMPER TOWARDS OSA DAMPE.
3. RELIEF AIR DAMPER TO BE OPPOSED BLADE.
4. COORDINATE DUCT OPENING LOCATIONS IN UNIT WITH STRUCTURAL FLOOR PENETRATIONS.

2 AHU-2 PLAN - 2ND FLOOR MECHANICAL ROOM # 234
SCALE: 1/4" = 1'-0"

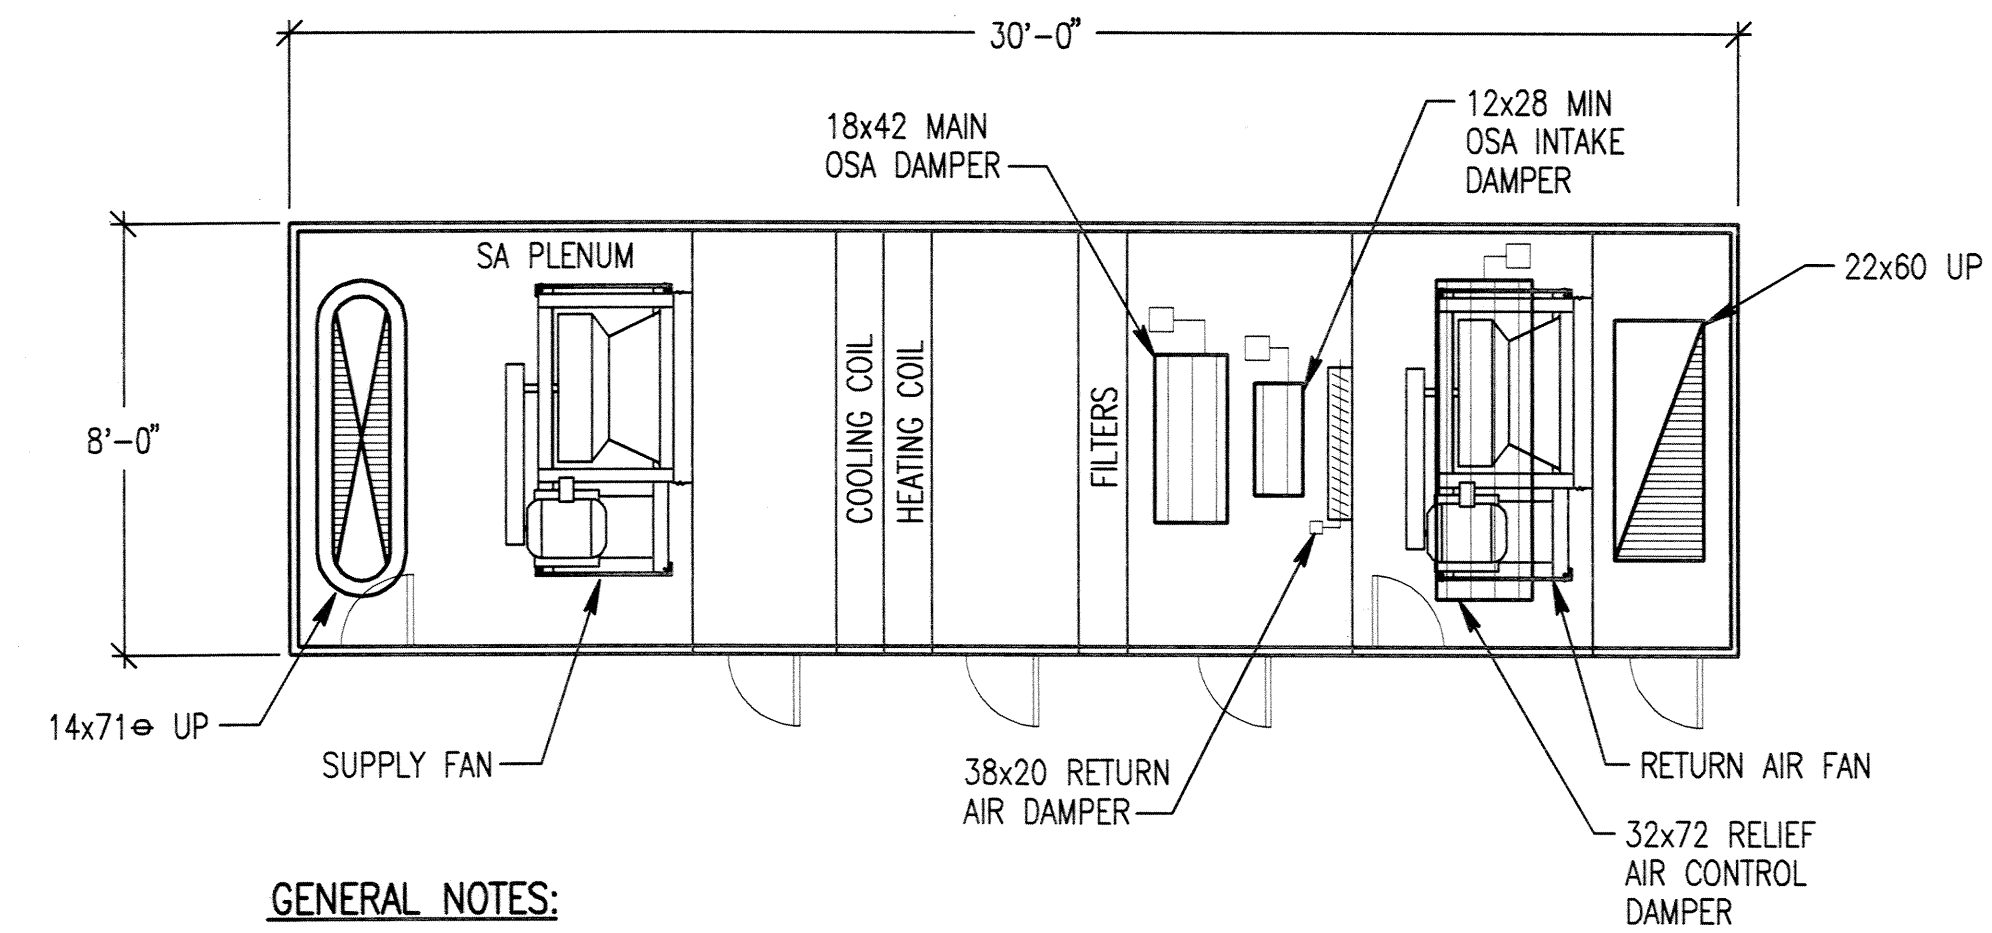

GENERAL NOTES:

1. UNIT TO BE MINIMUM 7' TALL, FROM UNIT FINISHED FLOOR TO INSIDE OF UNIT ROOF
2. RETURN AIR DAMPER AND OSA DAMPER TO BE PARRALLEL BLADE. ANGLE OSA DAMPER BLADES TOWARDS RETURN AIR DAMPER. ANGLE RETURN AIR DAMPER TOWARDS OSA DAMPE.
3. RELIEF AIR DAMPER TO BE OPPOSED BLADE.
4. COORDINATE DUCT OPENING LOCATIONS IN UNIT WITH STRUCTURAL FLOOR PENETRATIONS.

3 AHU-3 PLAN - 2ND FLOOR MECHANICAL ROOM # 234
SCALE: 1/4" = 1'-0"

DETAILS - MECHANICAL

**PCC ROCK CREEK CAMPUS
NEW BUILDING**

PORTLAND COMMUNITY COLLEGE
ROCK CREEK CAMPUS
9700 NW Spring-RE Road
PORTLAND, OREGON 97229

THOMAS HACKER ARCHITECTS INC.
733 SW OAK STREET
PORTLAND, OREGON 97205
(503) 233-1534
PAE CONSULTING ENGINEERS
808 SW THIRD AVENUE
PORTLAND, OREGON 97204
(503) 226-2921



REVISIONS :

DATE : 02/14/03
SCALE : NONE


EXPIRES 12-31-04
DRAWN BY : RRK
JOB NO. : 0115

DWG. NO.


M3.02

**THOMAS HACKER
ARCHITECTS INC.**



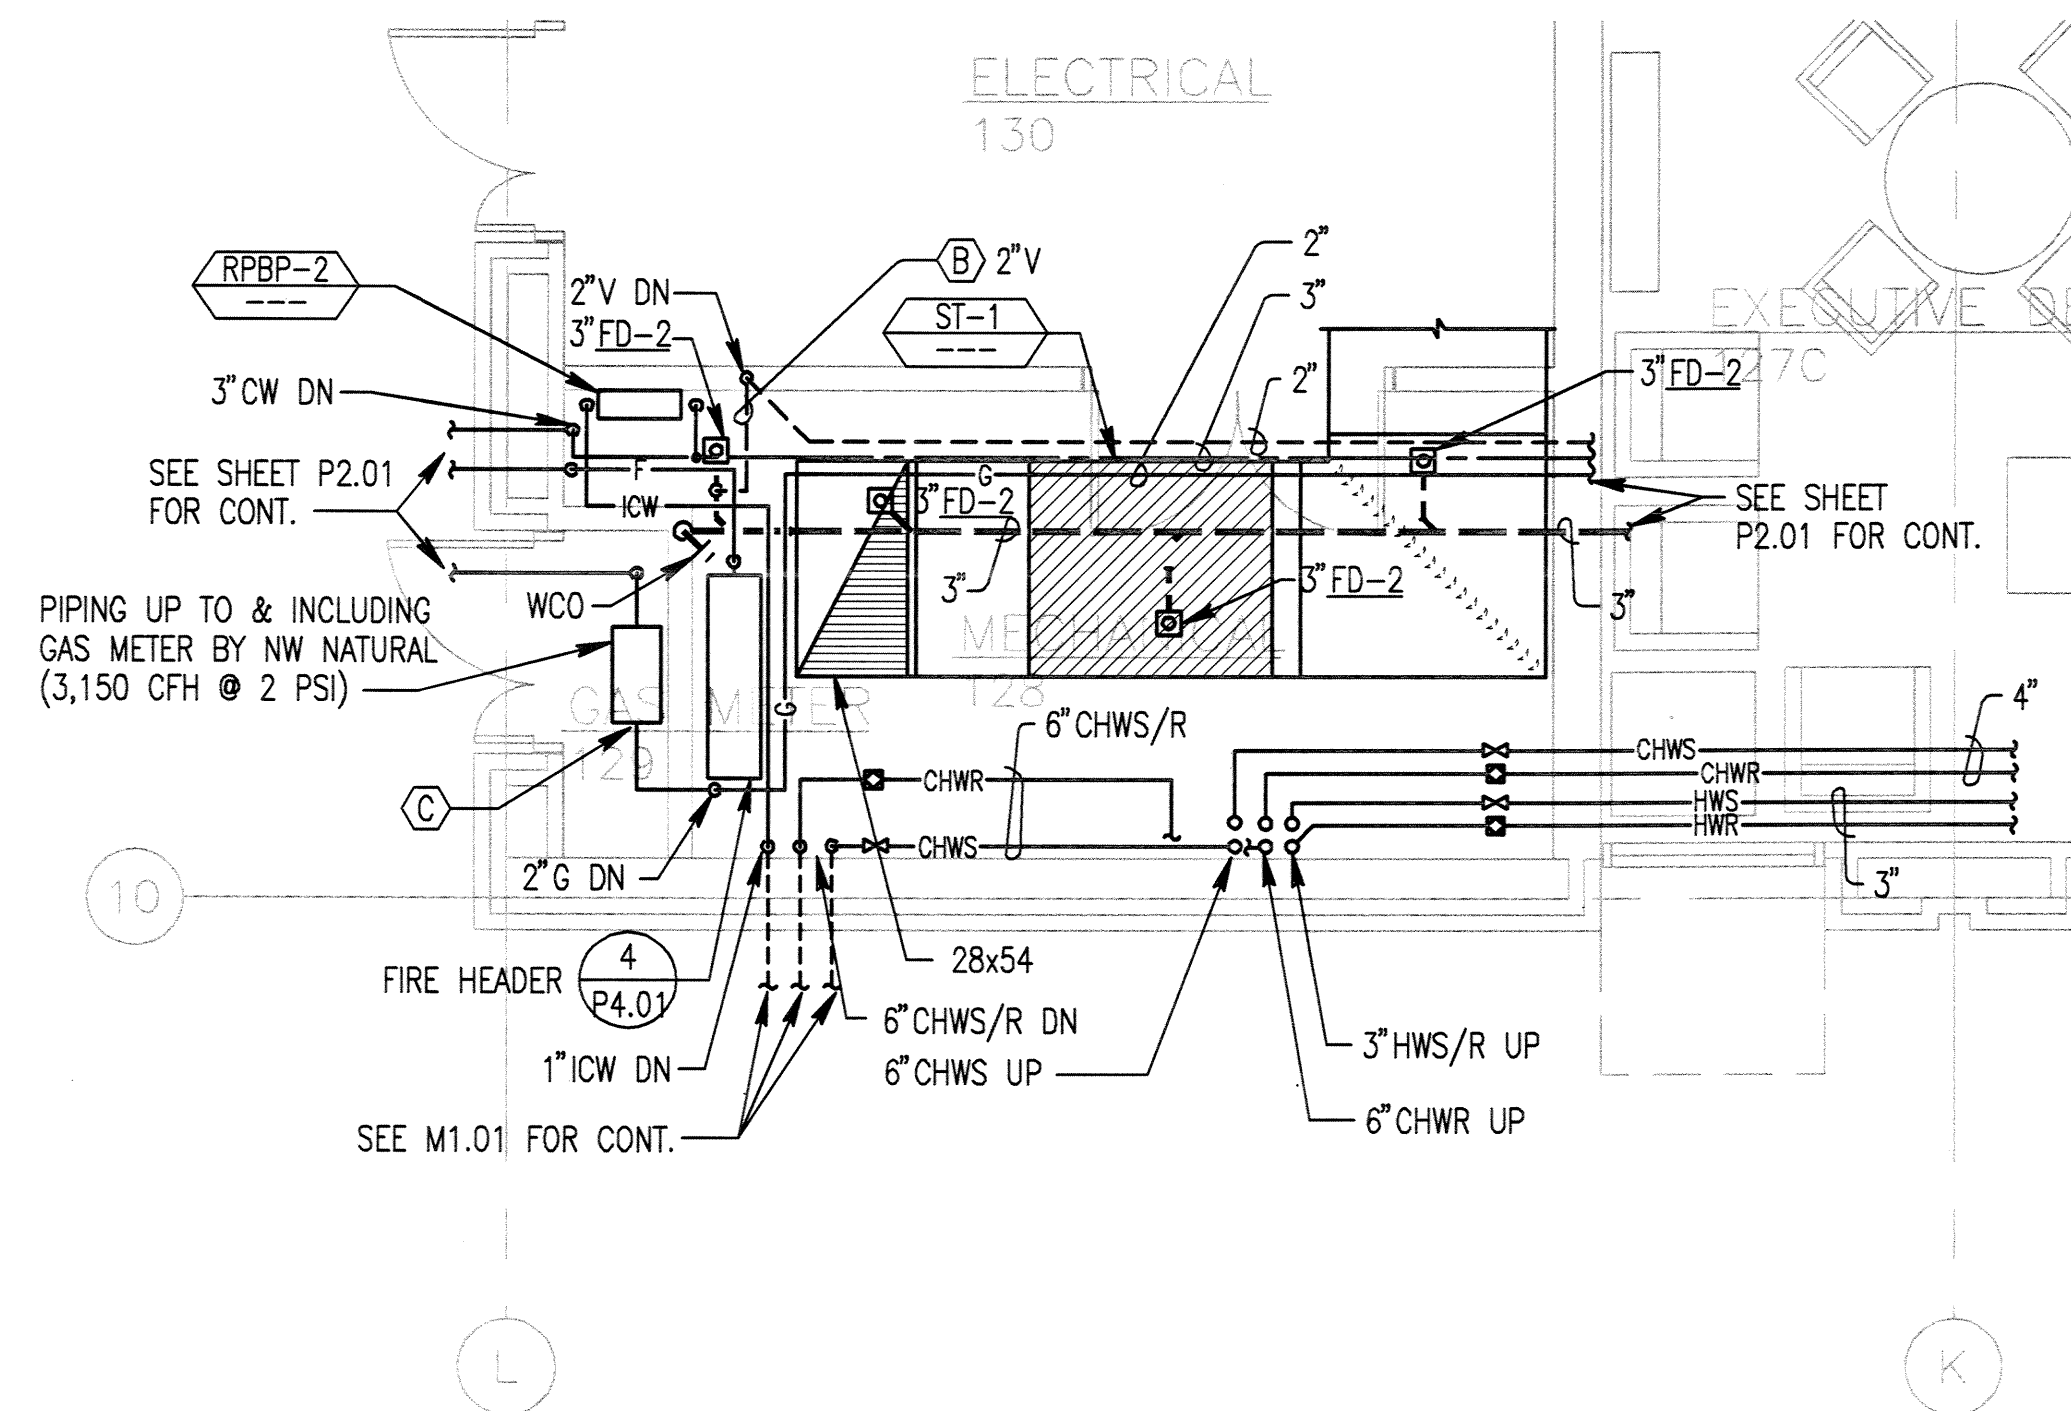

1 FIRST FLOOR — MECHANICAL ROOM
SCALE: 1/4" = 1'-0"

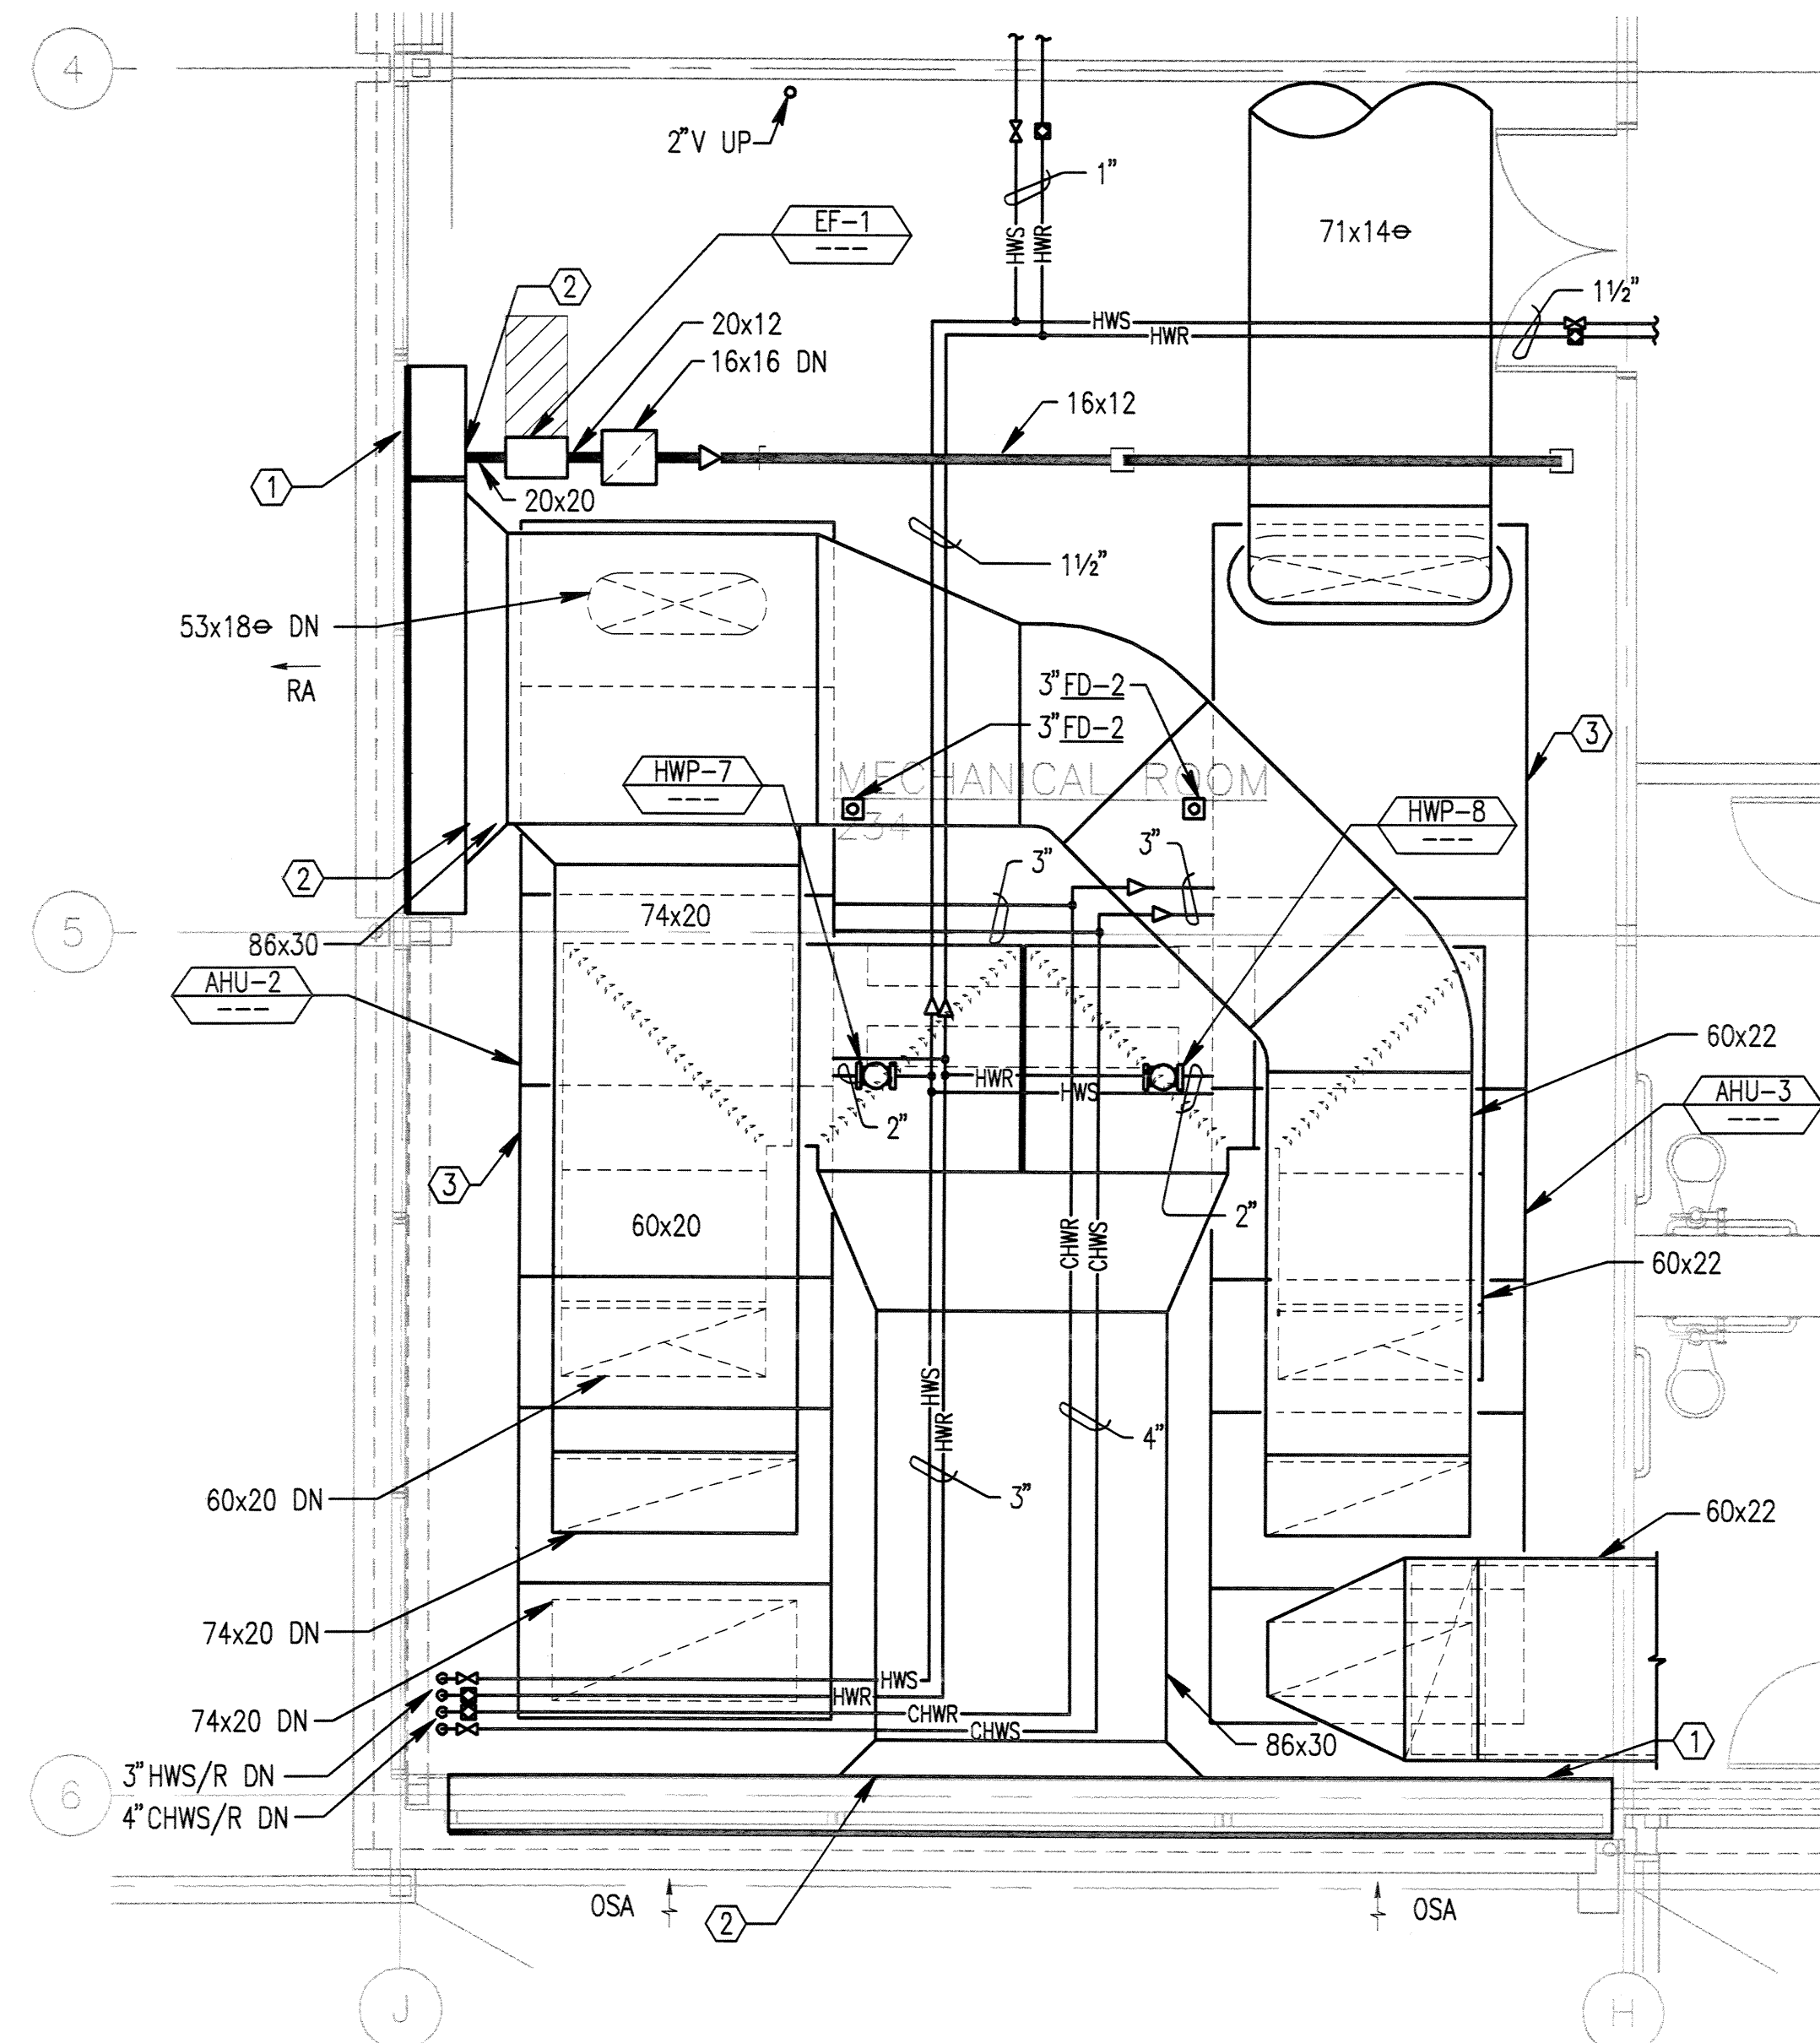

- NOTES:**
- ① PROVIDE 18" DEEP PLENUM AT BACK OF LOUVER. SLOPE TO LOUVER DRAIN POINT. COORDINATE PLENUM LOCATION WITH EXTERIOR WALL.
 - ② CONNECT DUCT TO BACK OF PLENUM.
 - ③ HOUSEKEEPING PAD.

2 SECOND FLOOR MECHANICAL ROOM — NORTH
SCALE: 1/4" = 1'-0"

PARTIAL PLANS
HVAC
PCC ROCK CREEK CAMPUS
NEW BUILDING
PORTLAND COMMUNITY COLLEGE
ROCK CREEK CAMPUS
8700 NW Springville Road
PORTLAND, OREGON 97229

THOMAS HACKER ARCHITECTS INC.
733 SW OAK STREET
PORTLAND, OREGON 97205
(503) 227-0254

PAE CONSULTING ENGINEERS
808 SW THIRD AVENUE
PORTLAND, OREGON 97204
(503) 226-2921

REVISIONS : 03/21/03

DATE : 02/14/03
SCALE : NOTED





EXPIRES 12-31-04
DRAWN BY : TM
JOB NO. : 0115

DWG. NO.


THOMAS HACKER
ARCHITECTS INC.



M3.03

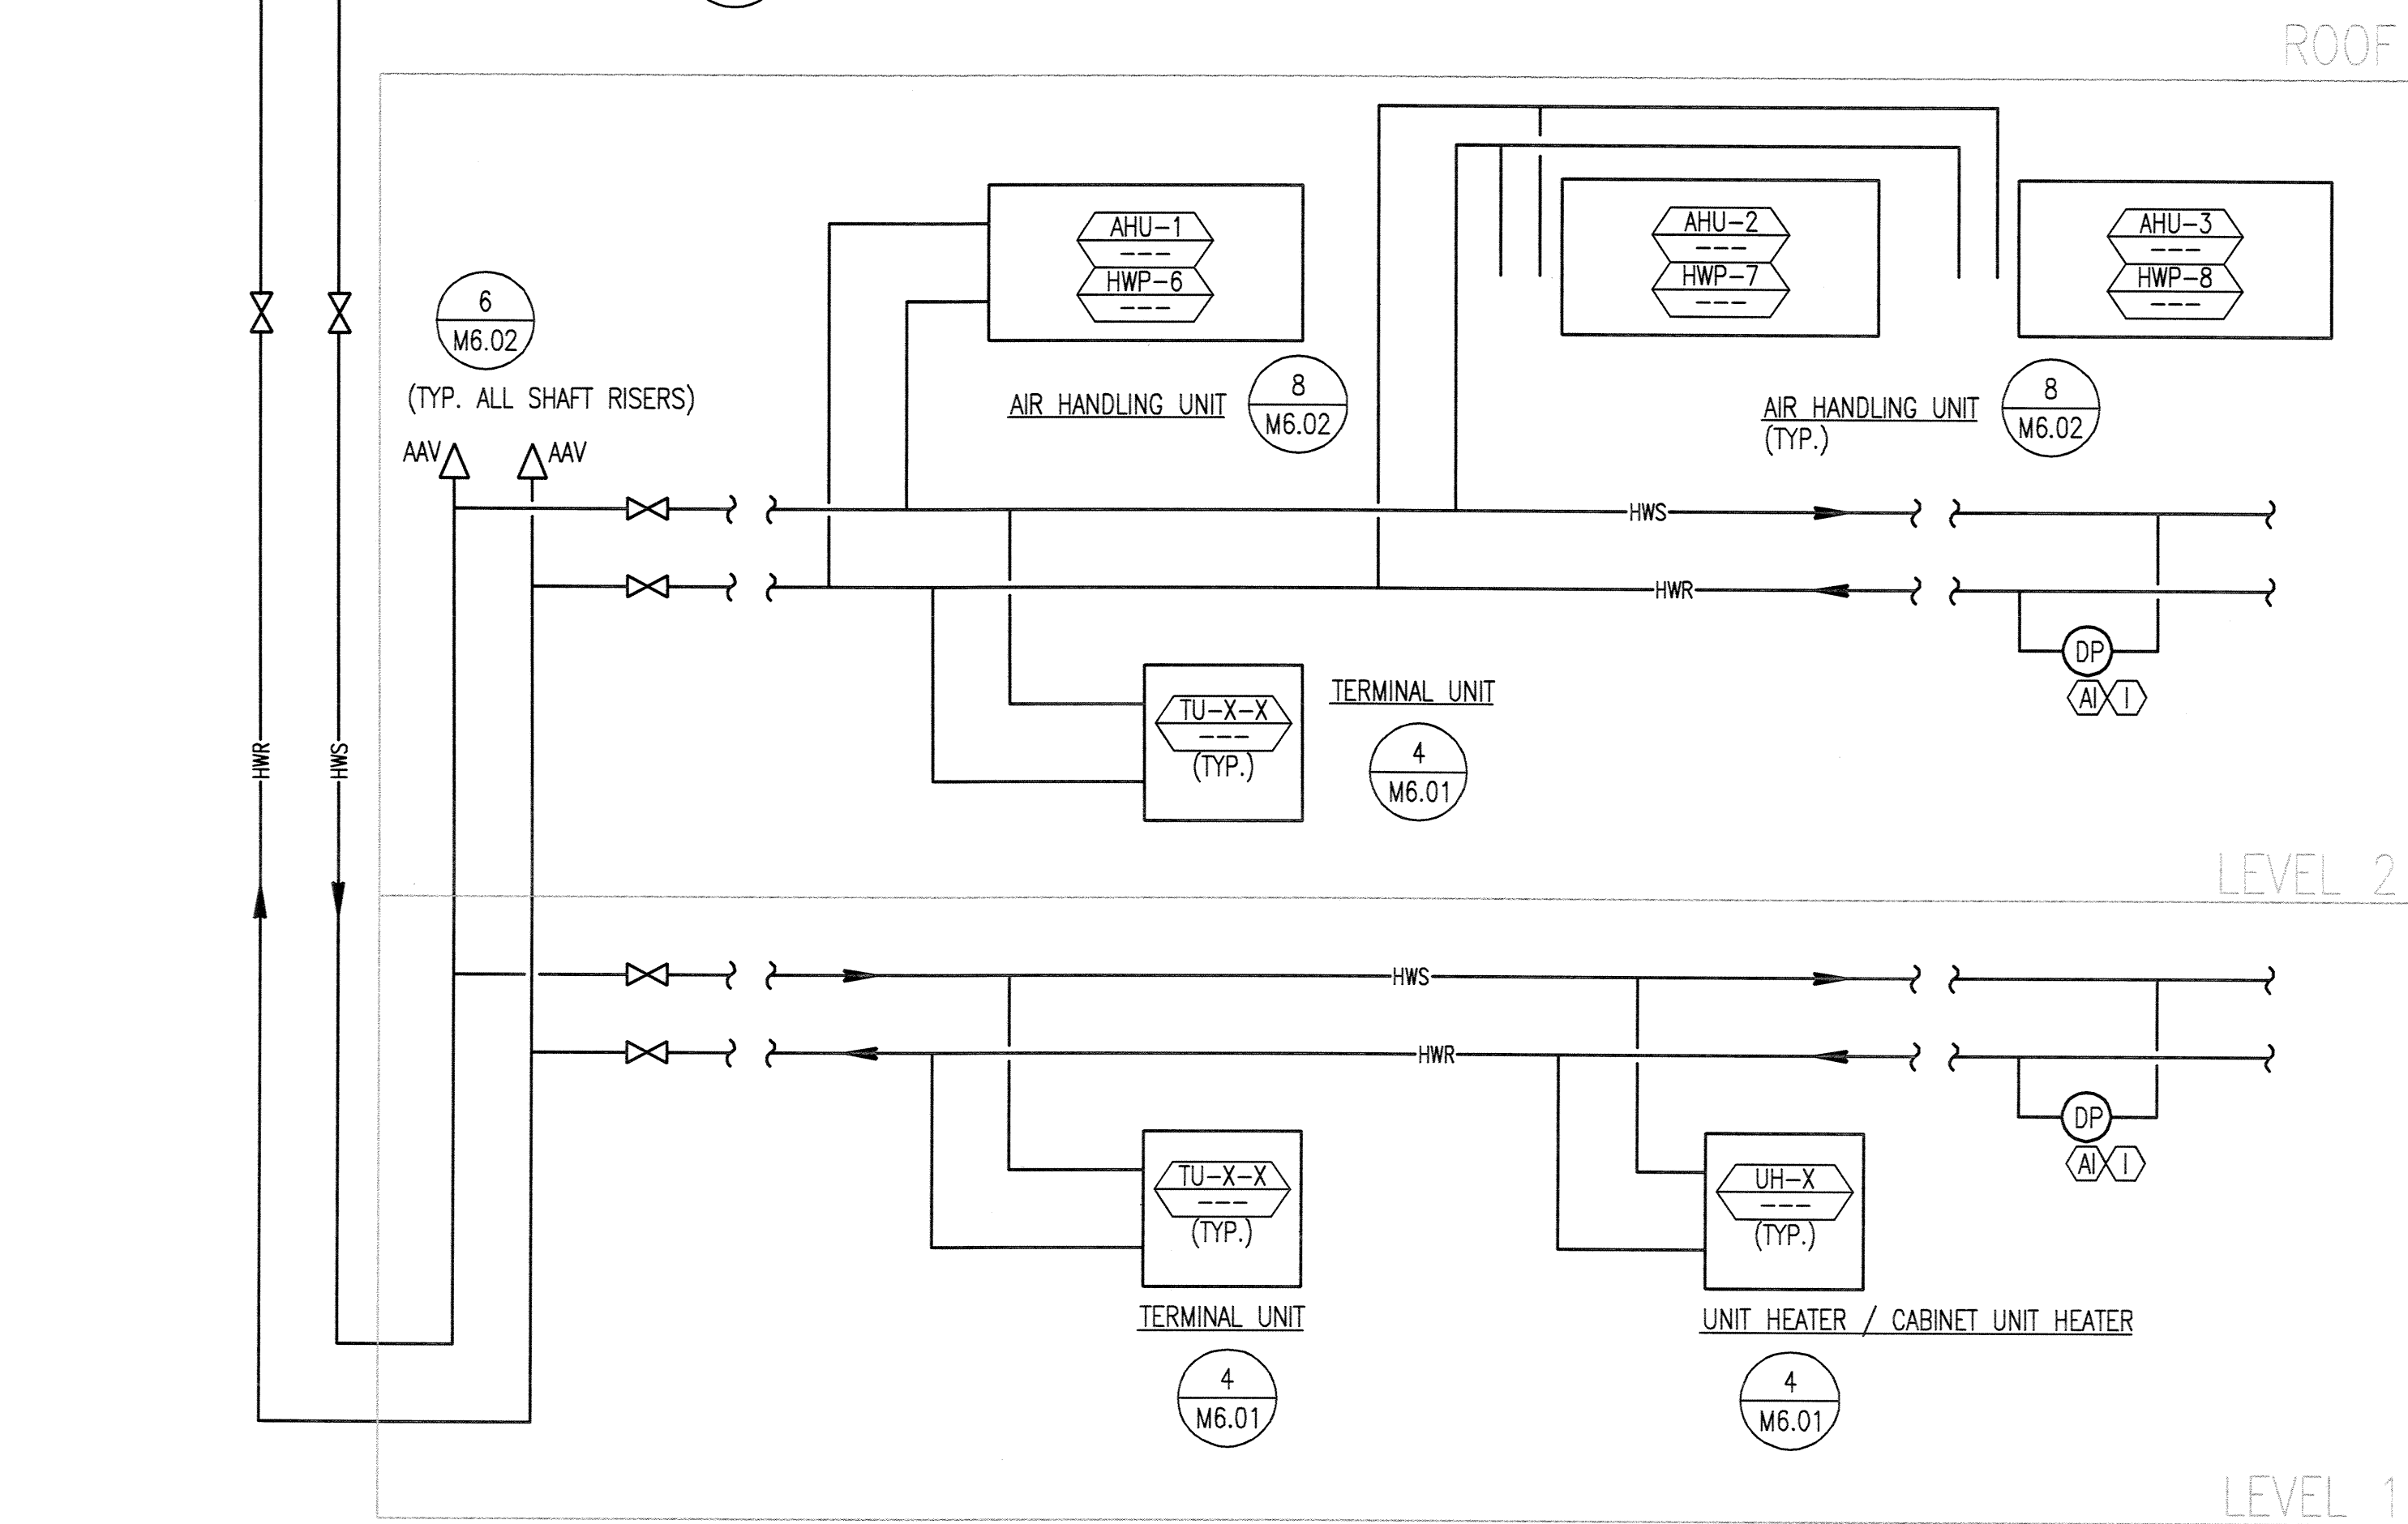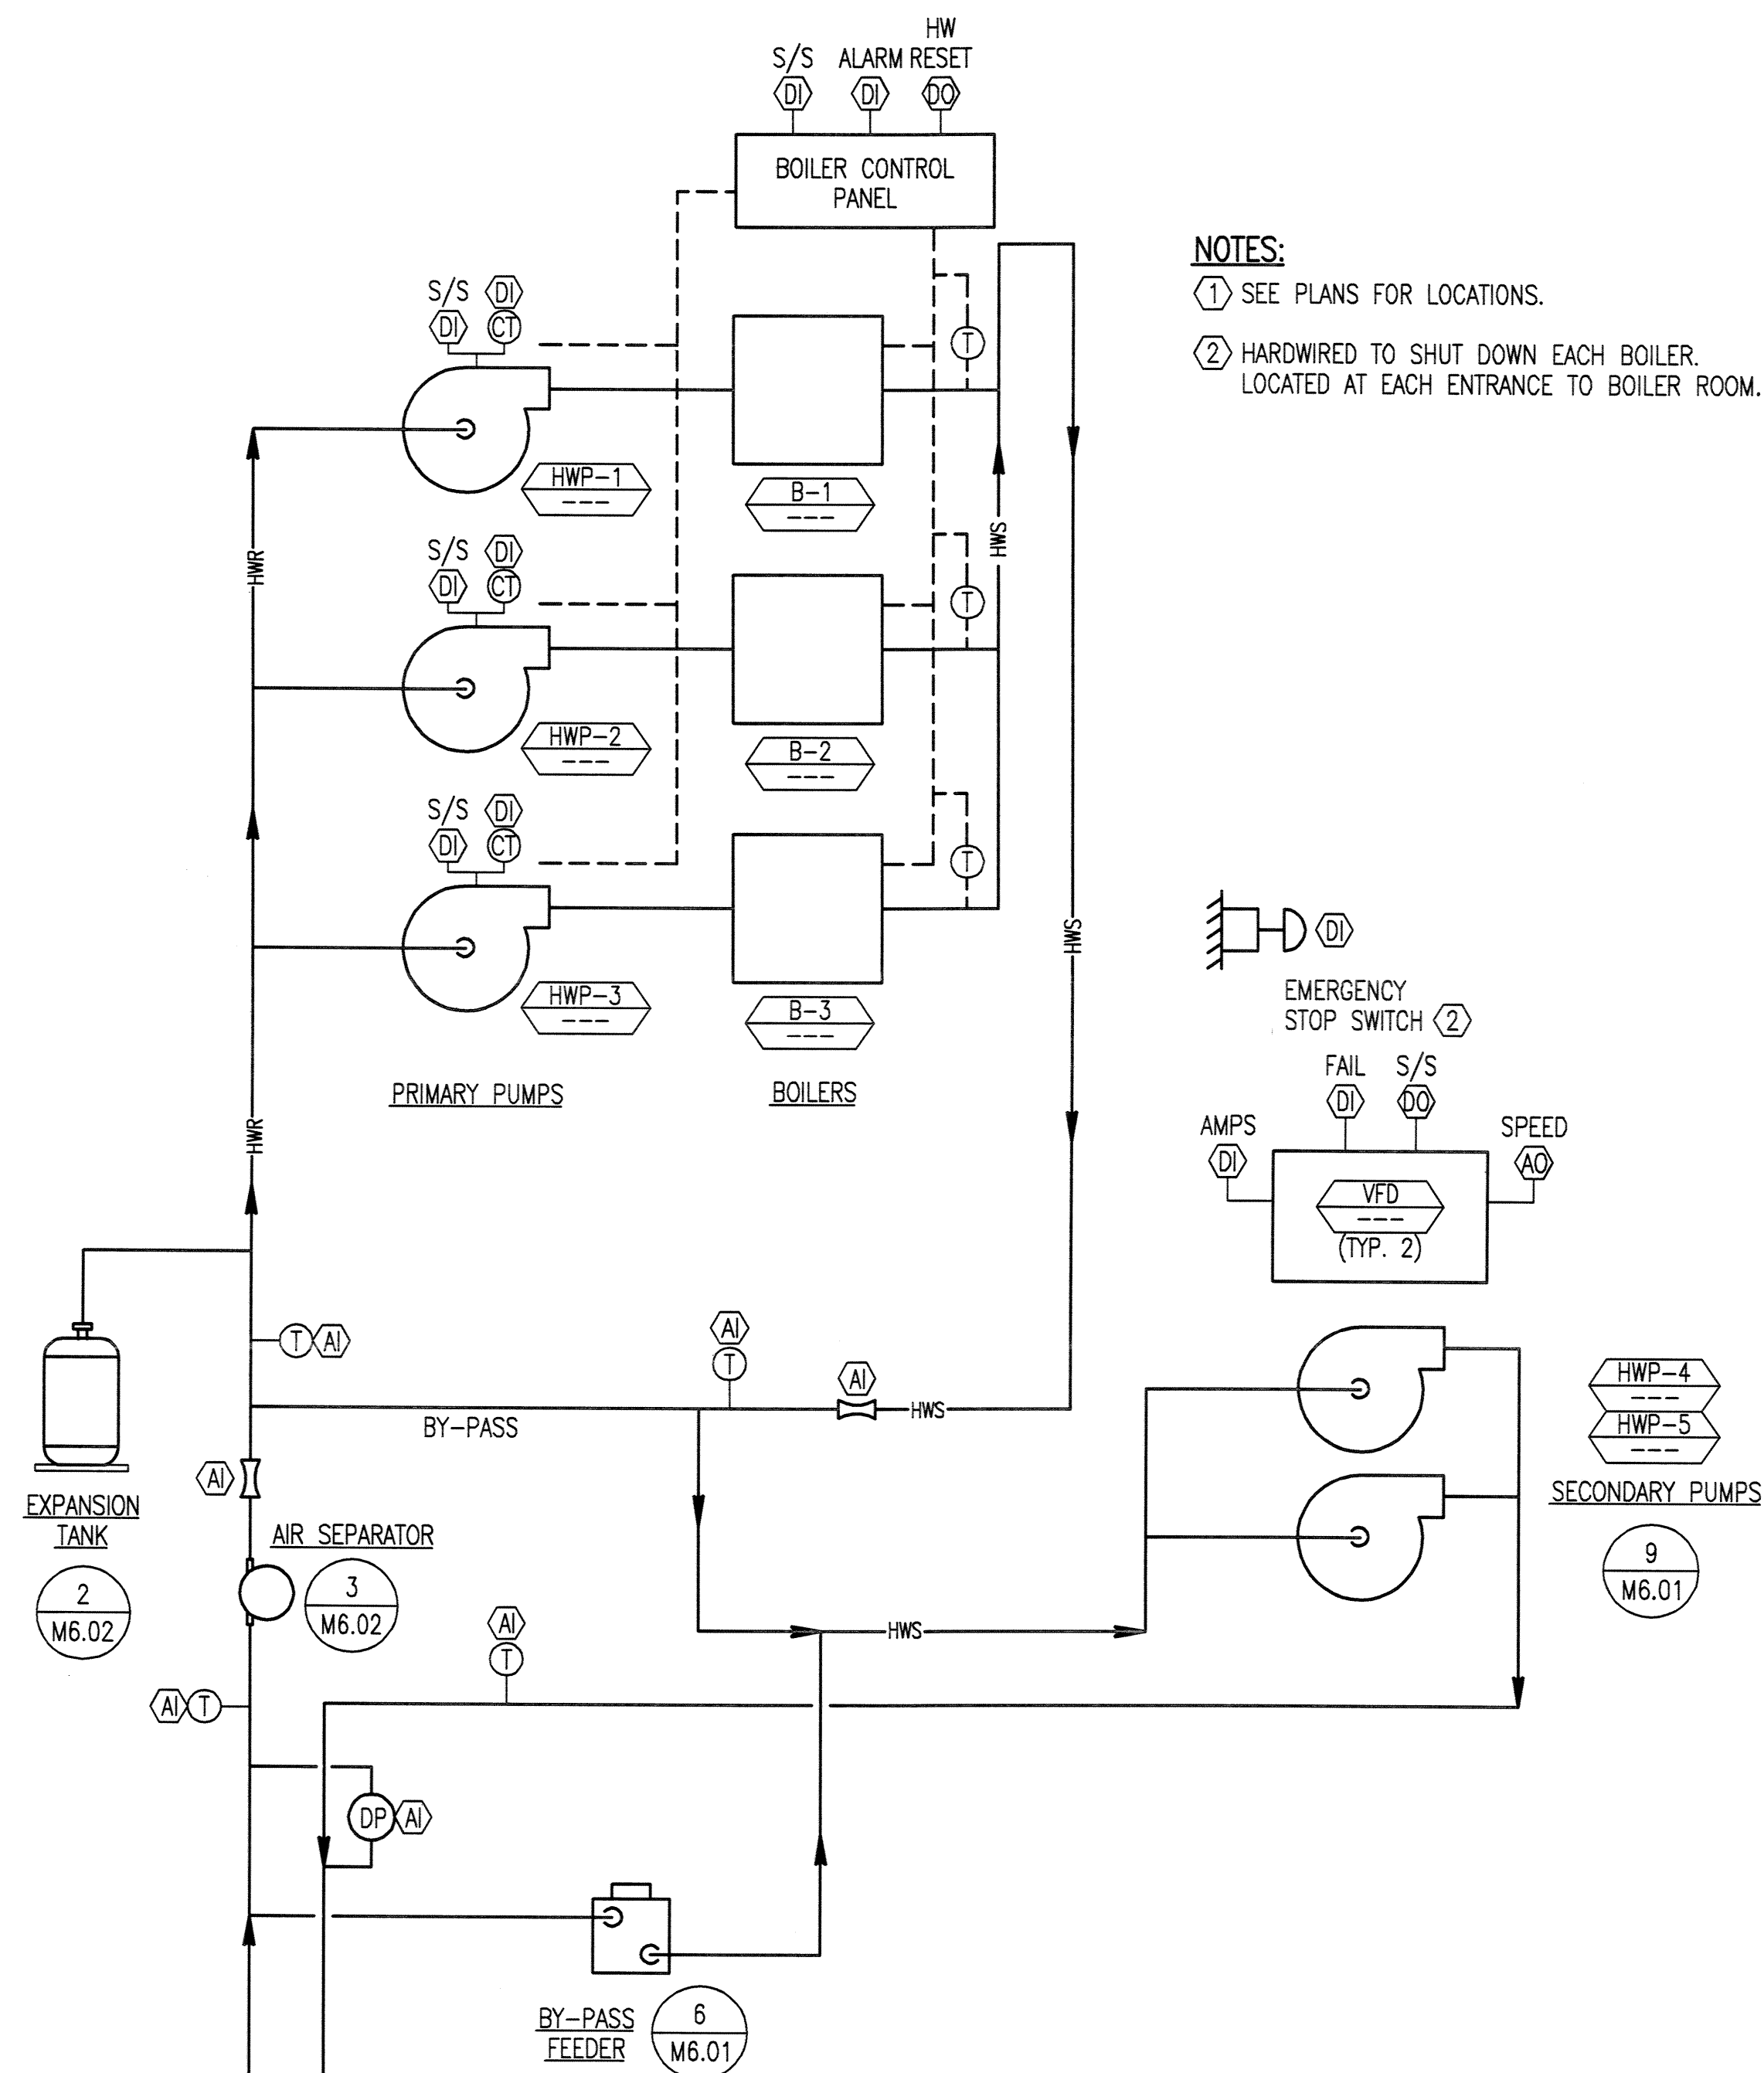

1 HEATING WATER DIAGRAM (B-1,2,3, HWP-1,2,3,4,5)
 M4.01 SCALE: NONE

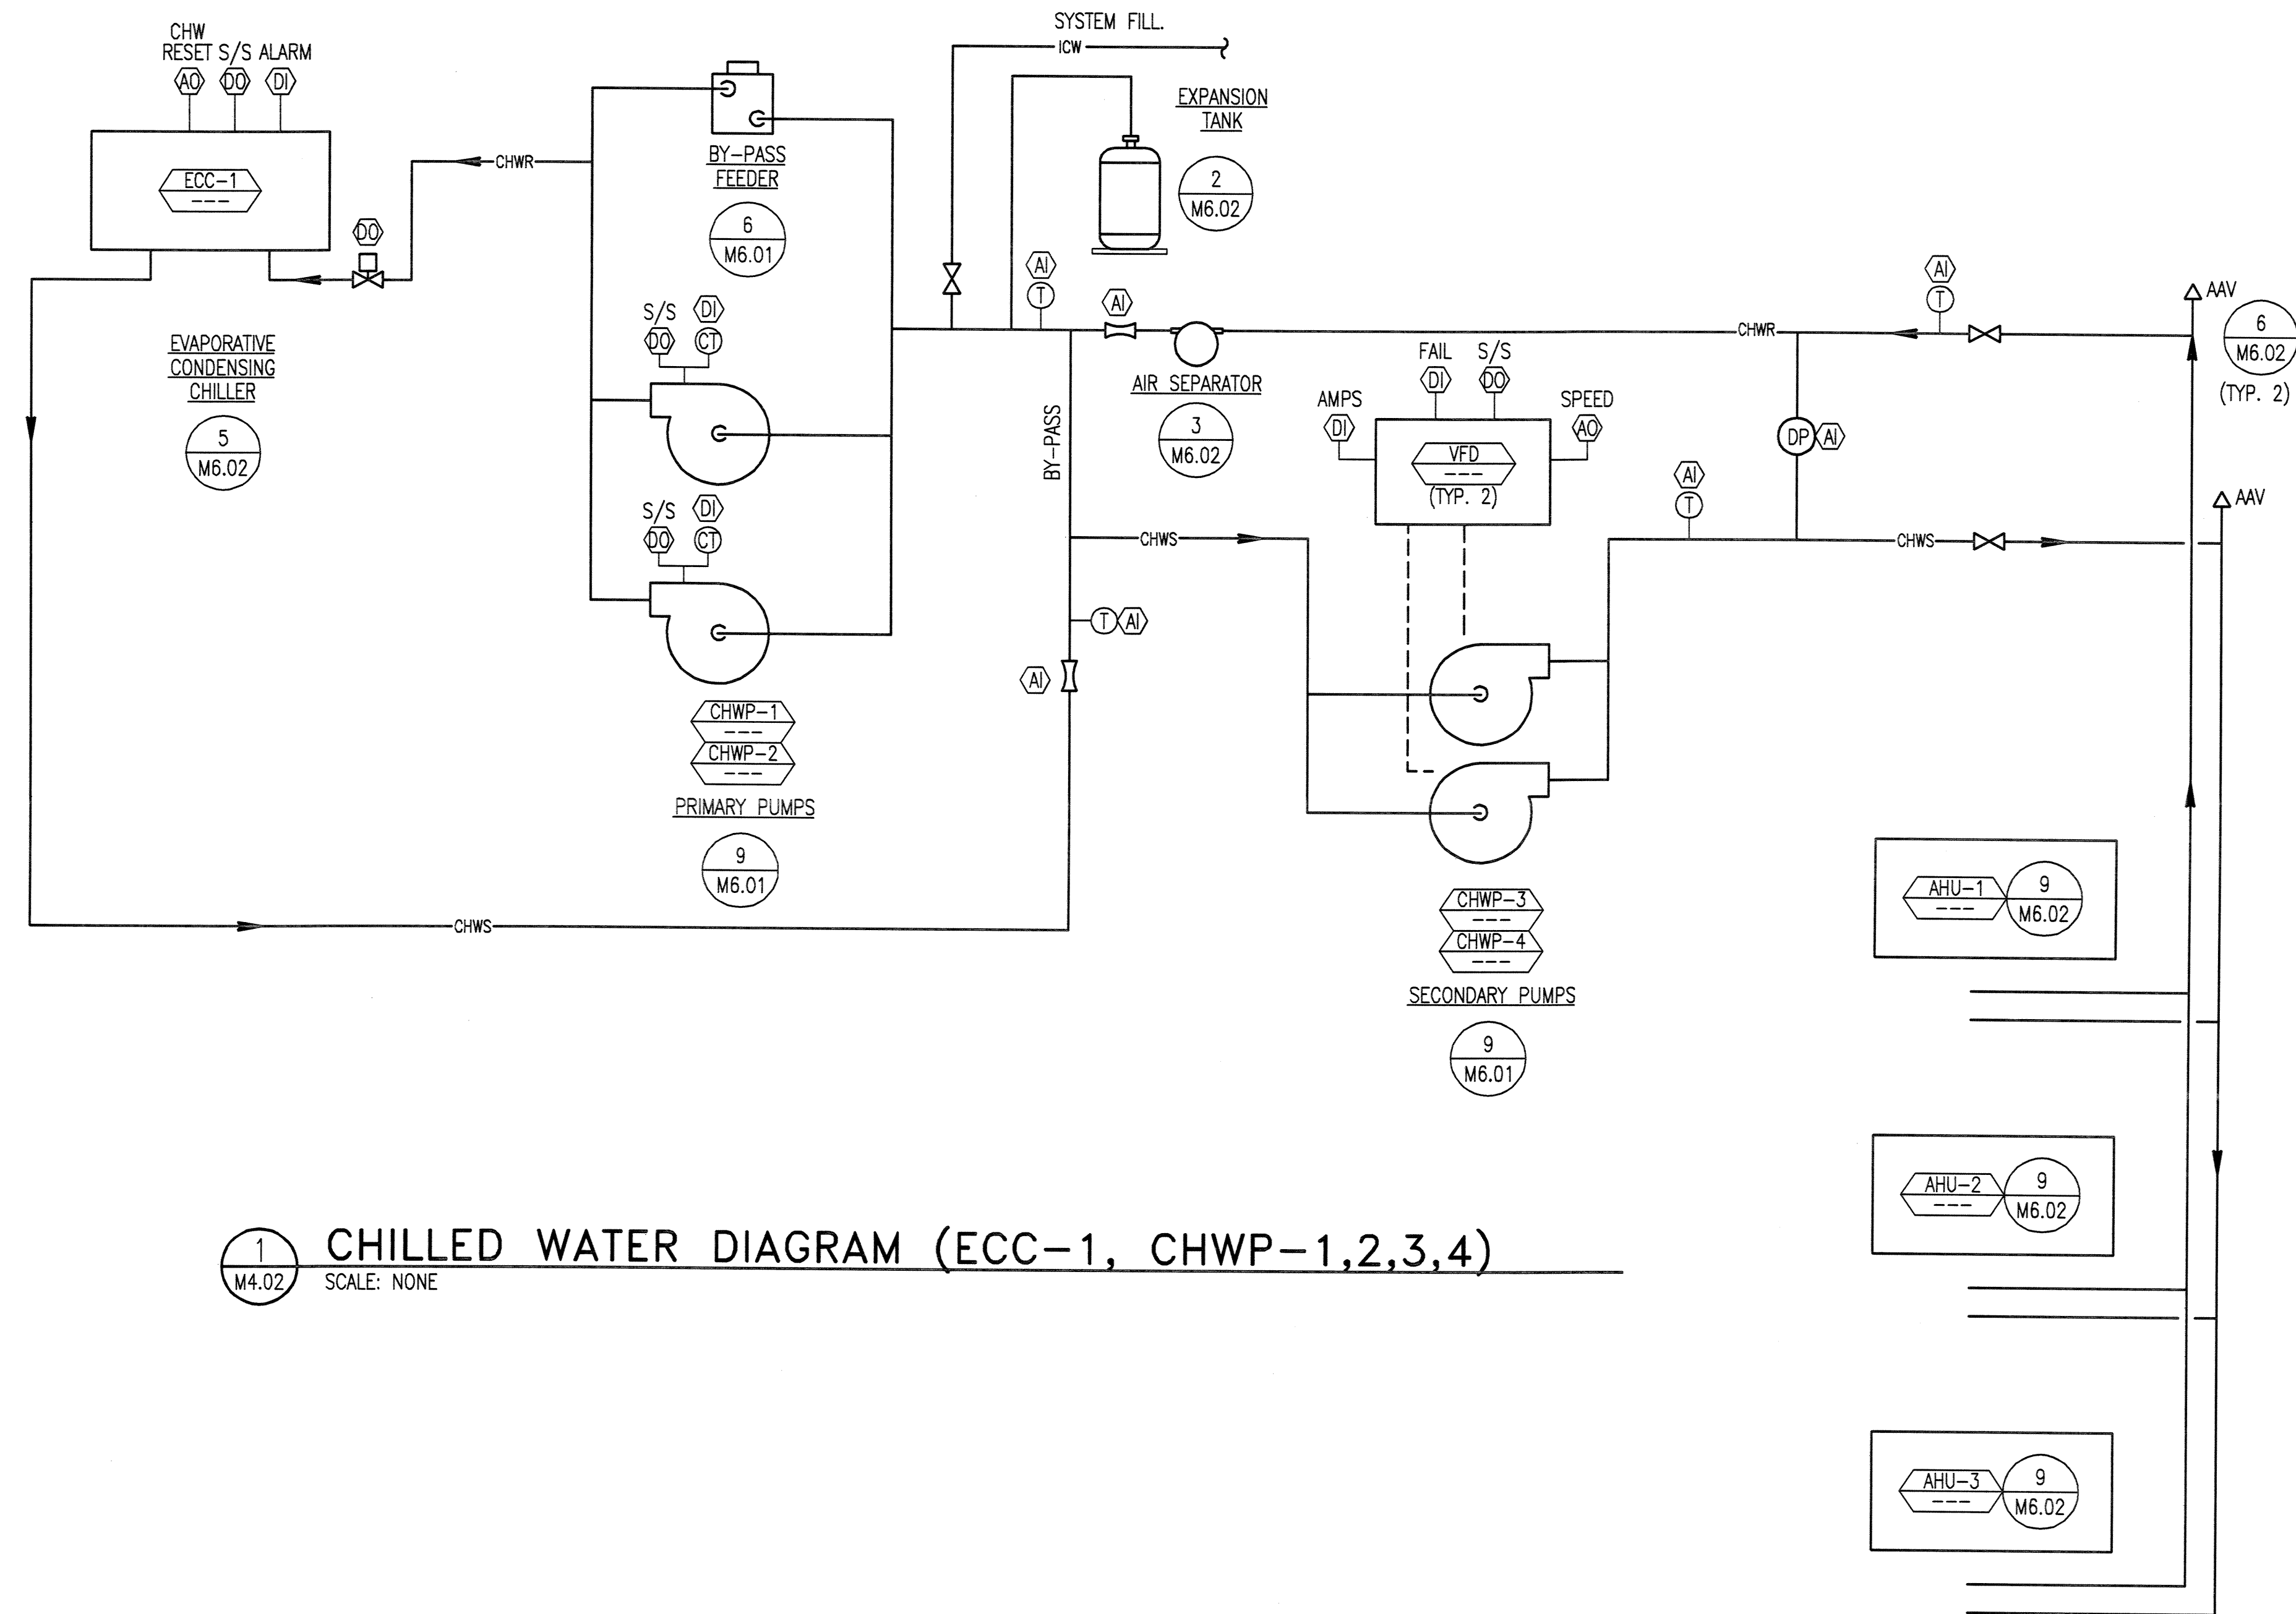

1 CHILLED WATER DIAGRAM (ECC-1, CHWP-1,2,3,4)
 M4.02 SCALE: NONE

WATER CONTROL DIAGRAMS
 MECHANICAL
 PCC ROCK CREEK CAMPUS
 NEW BUILDING

PORTLAND COMMUNITY COLLEGE
 ROCK CREEK CAMPUS
 9705 NW Springville Road
 PORTLAND, OREGON 97229

THOMAS HACKER ARCHITECTS INC.
 733 SW OAK STREET
 PORTLAND, OREGON 97205
 503.227.1254

PAE CONSULTING ENGINEERS
 808 SW THIRD AVENUE
 PORTLAND, OREGON 97204
 503.226.2921

REVISIONS :

DATE : 02/14/03
 SCALE : NONE




EXPIRES 12-31-04
 DRAWN BY : RRR
 JOB NO. : 0115

DWG. NO.


THOMAS HACKER
 ARCHITECTS INC.




M4.01

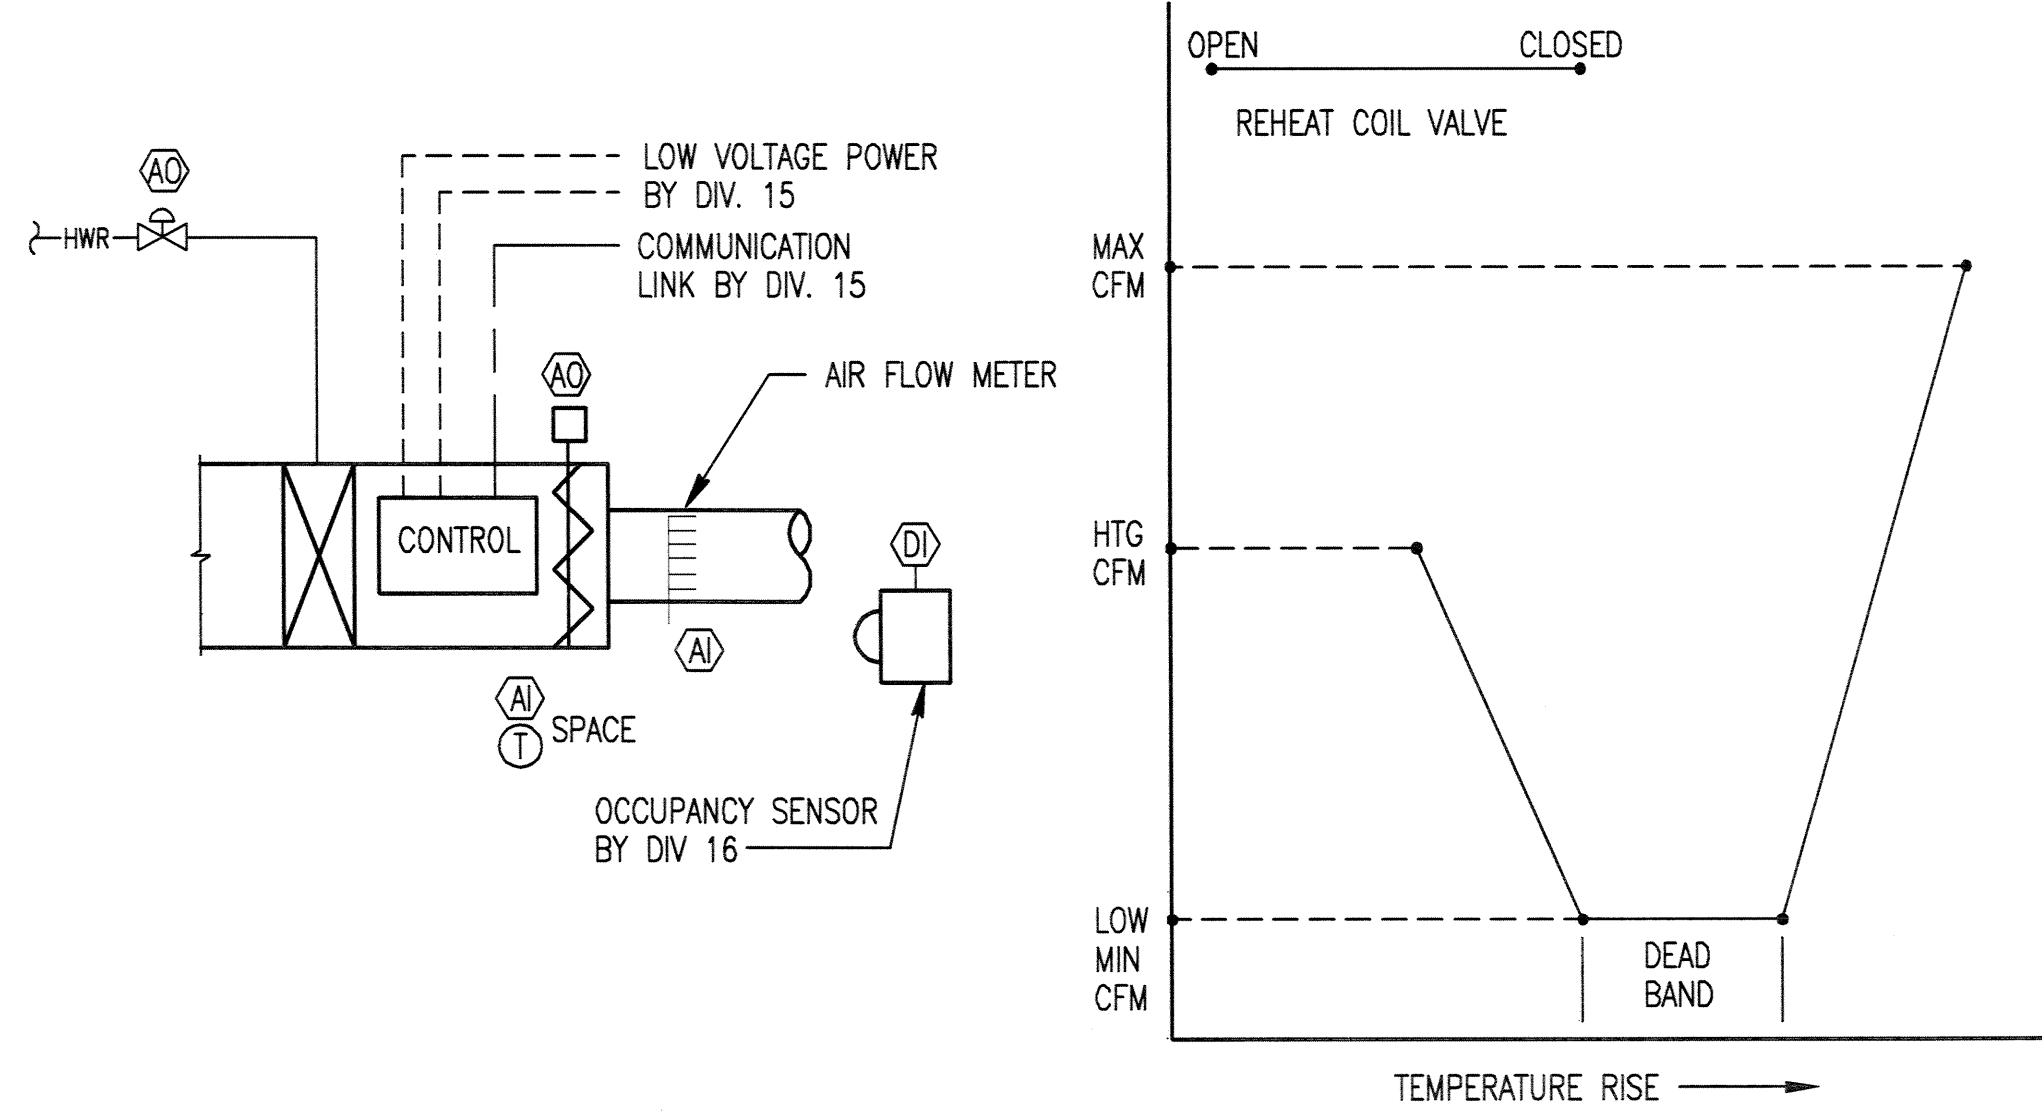


1 TYPICAL GROUP STUDY ROOM, CONFERENCE ROOM & CLASSROOM VAV REHEAT TERMINAL CONTROL DIAGRAM (TU-X-XX)
M5.01 SCALE: NONE

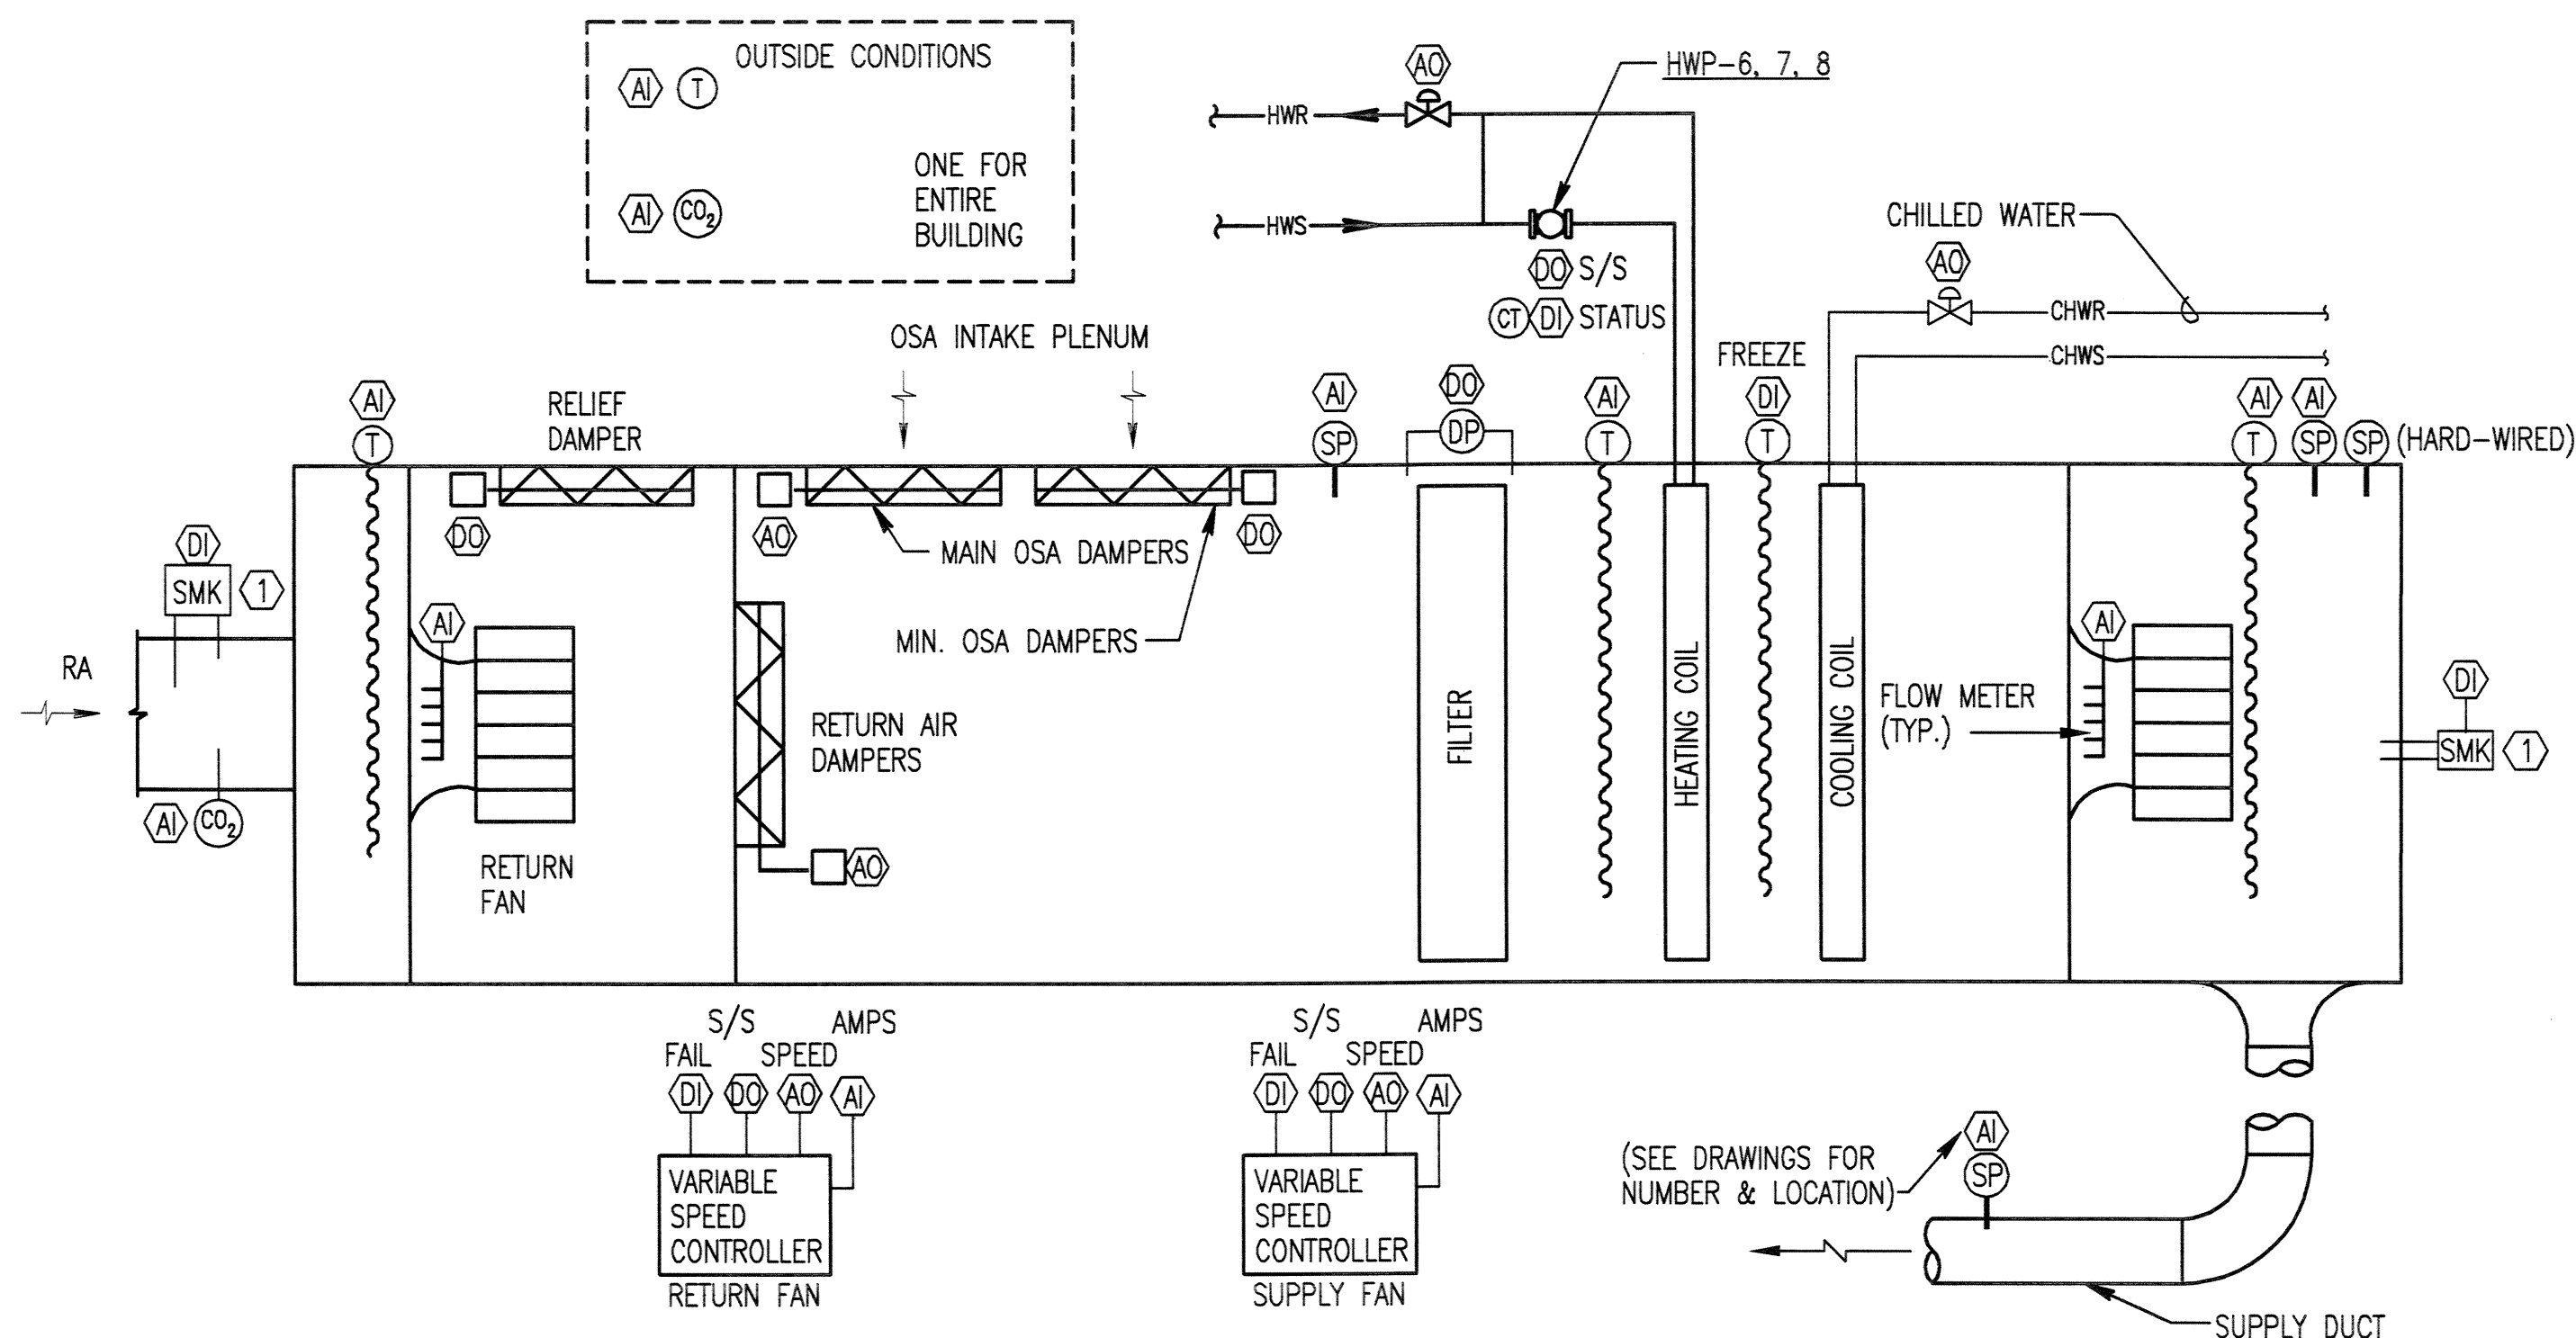

2 AIR HANDLING UNIT CONTROL DIAGRAM (AHU-1,2,3)
M5.01 SCALE: NONE

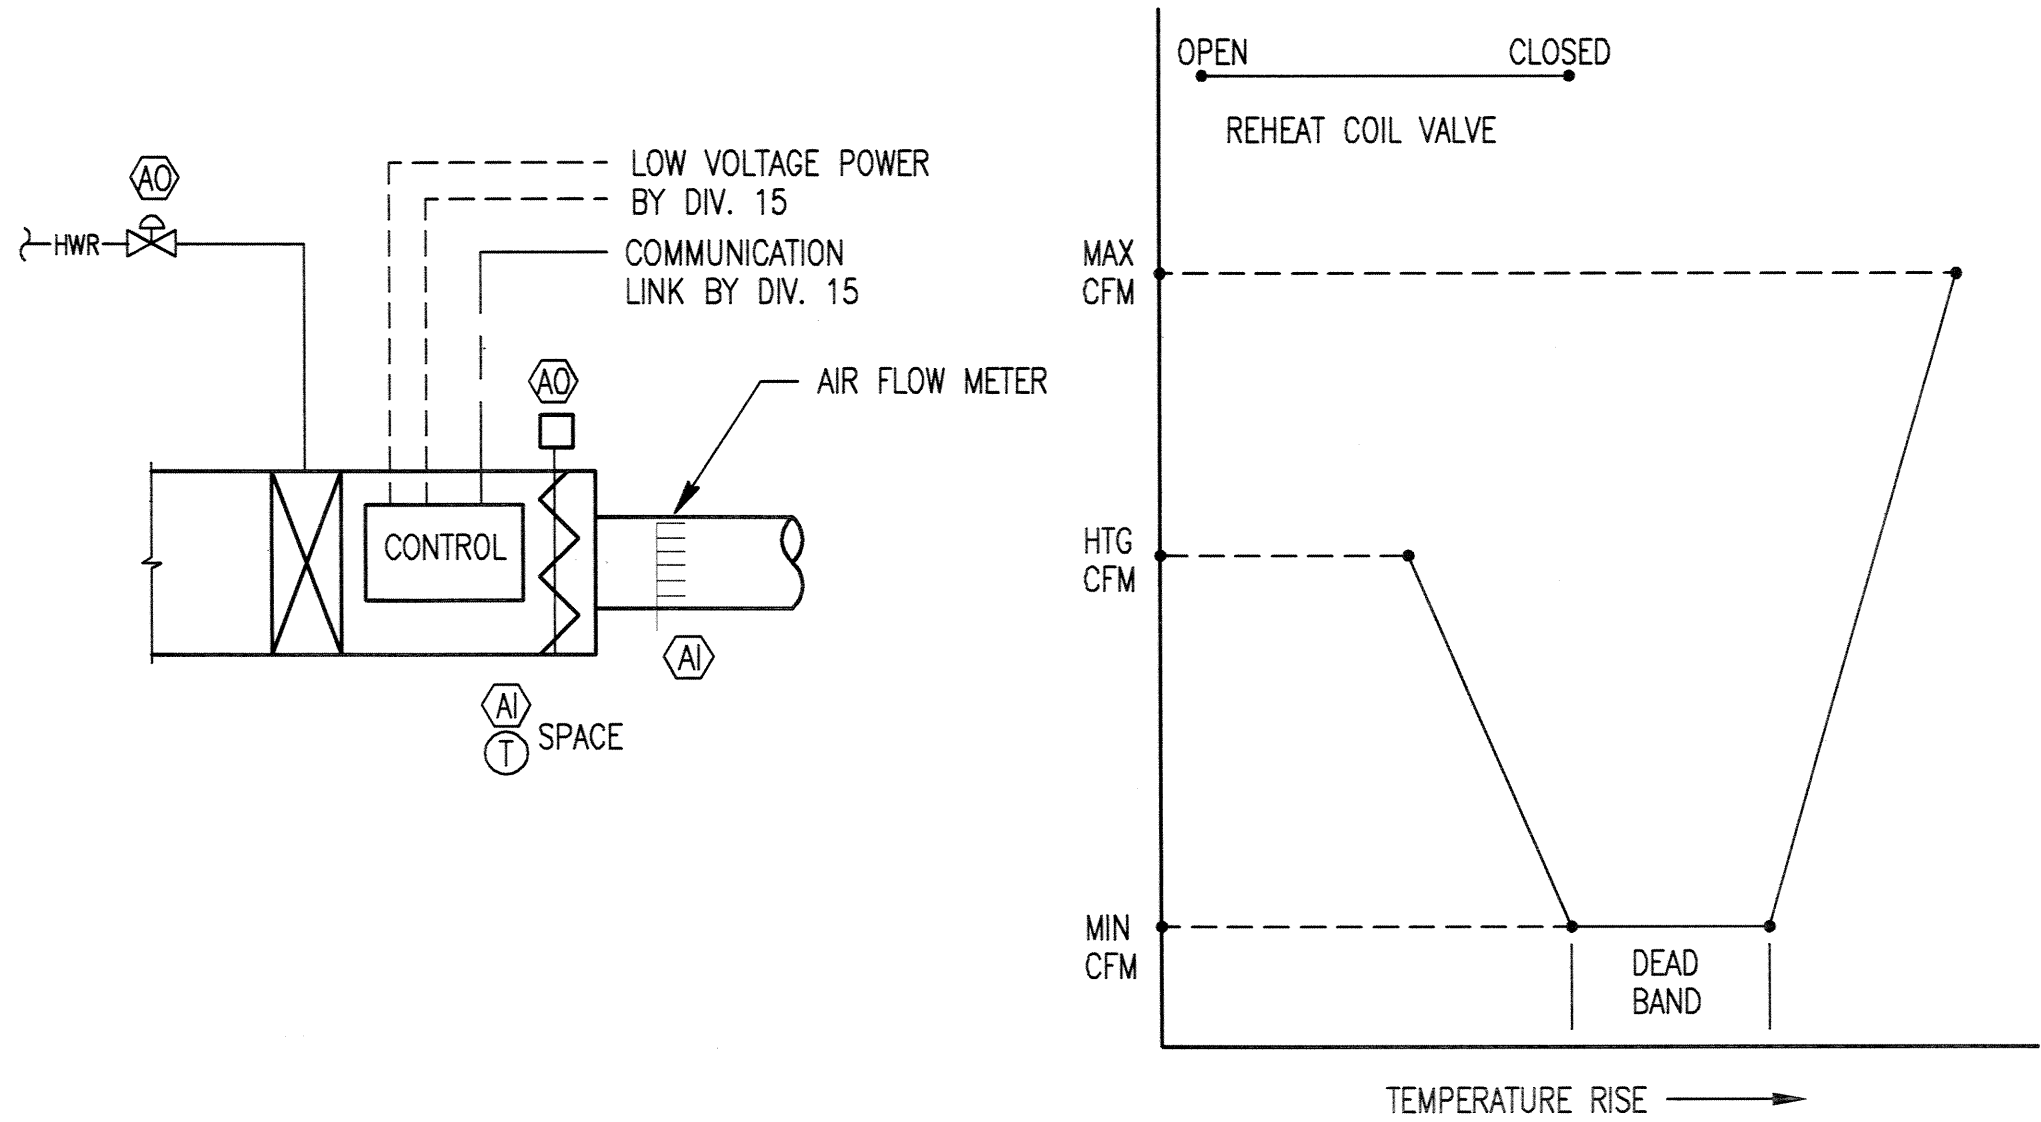


3 TYPICAL VAV REHEAT TERMINAL CONTROL DIAGRAM (TU-X-XX)
M5.01 SCALE: NONE

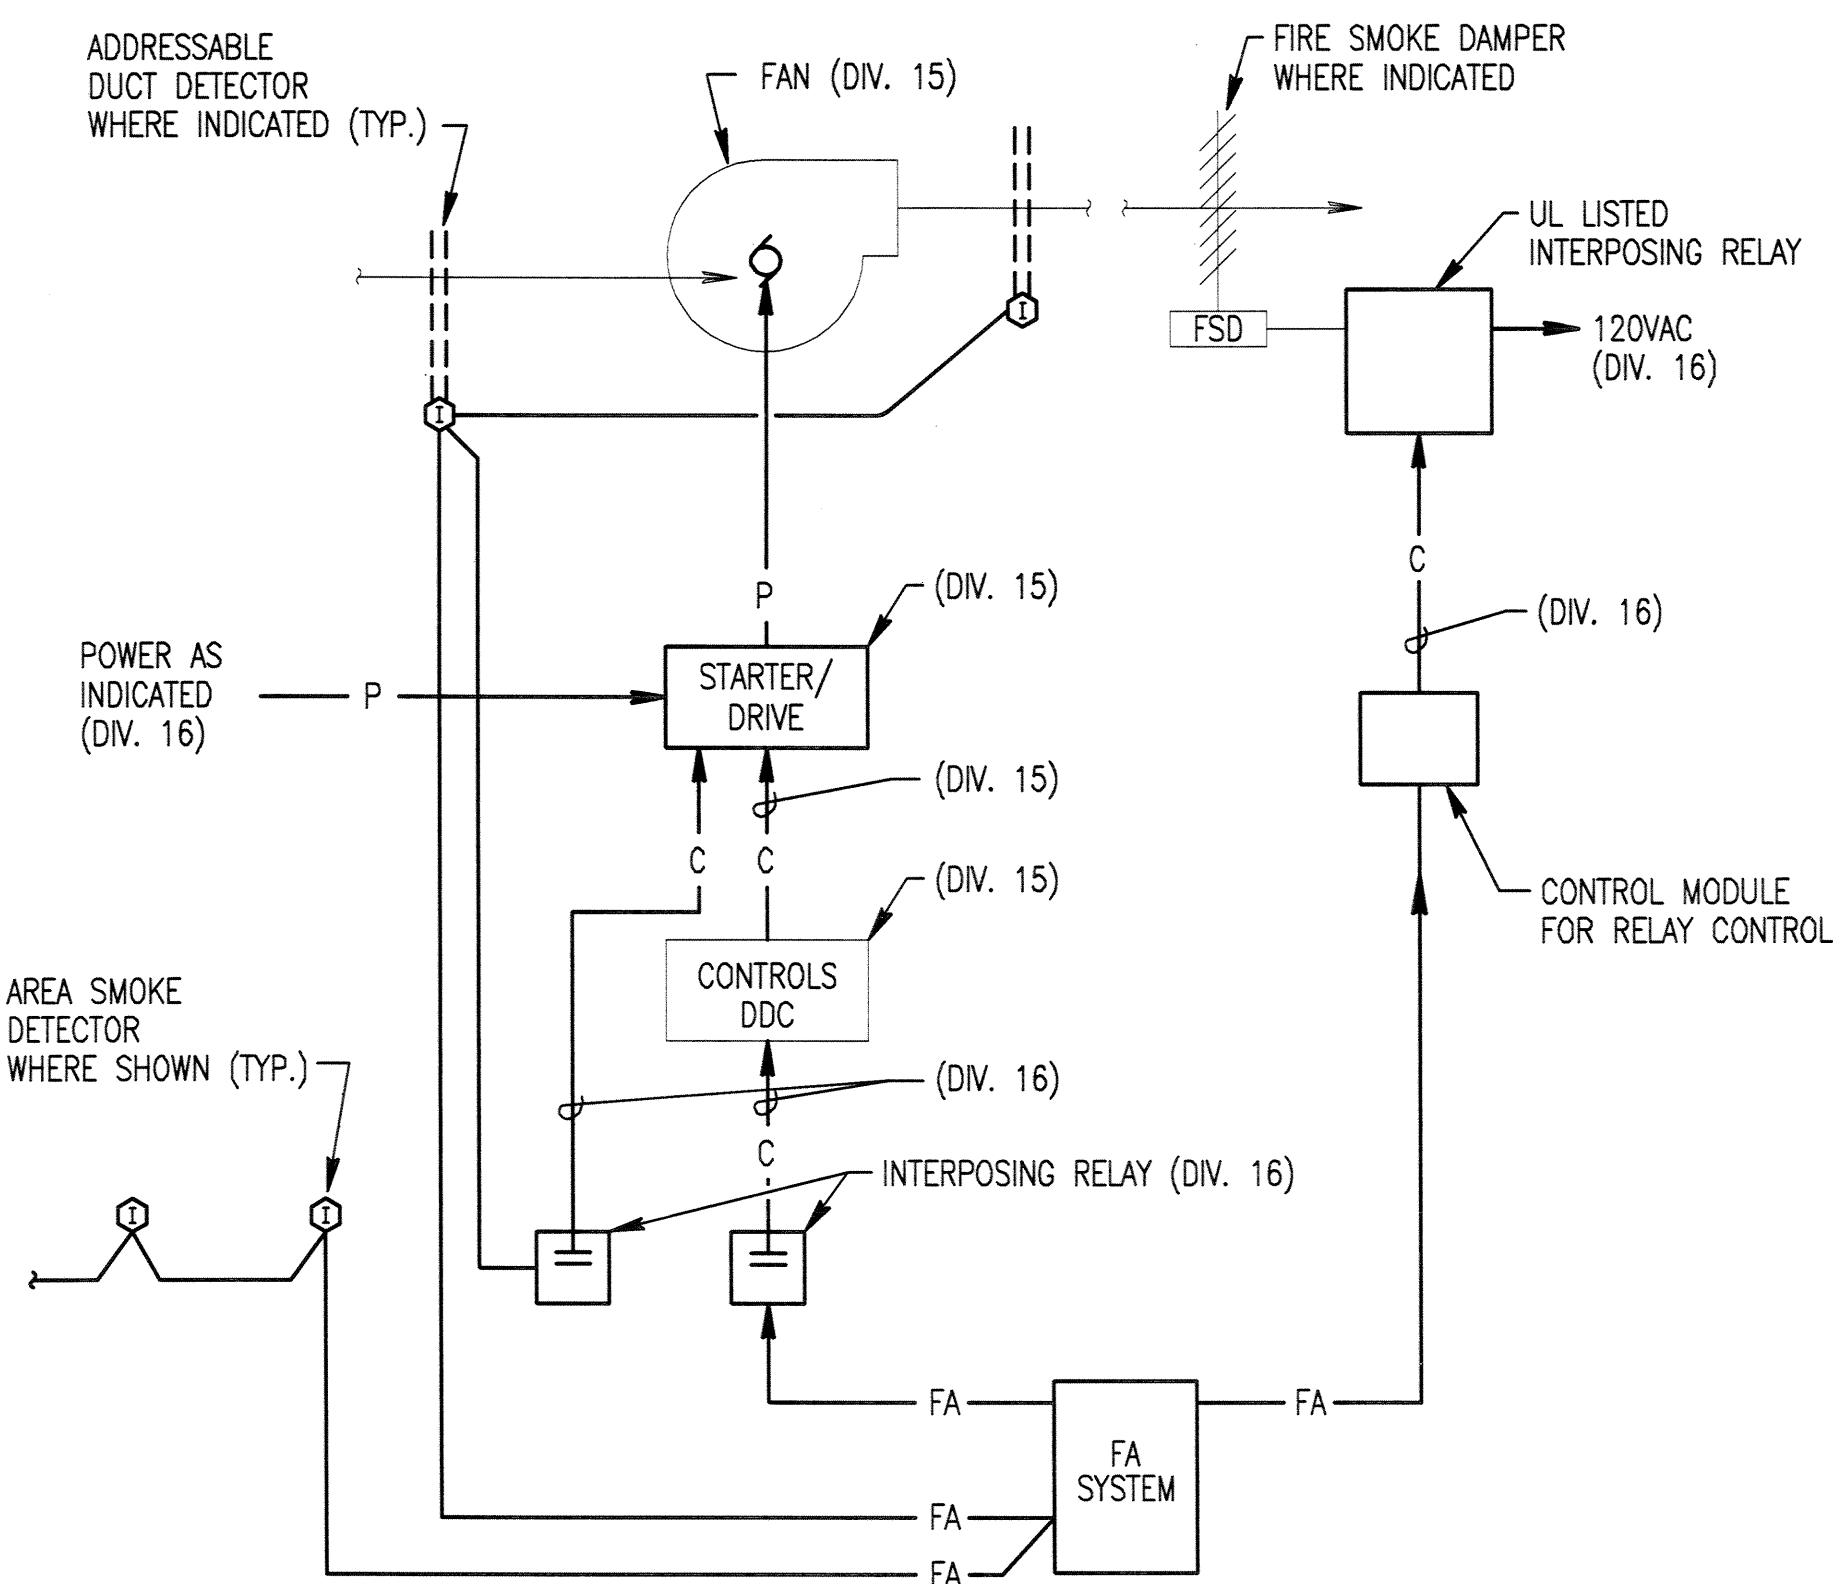


GENERAL NOTES:
1. SEE SEQUENCE OF OPERATION FOR RELAYS 1, 2 & 3 OPERATION.

LEGEND
FA - SUPERVISED FA CIRCUIT
C - CONTROL WIRING
P - POWER WIRING

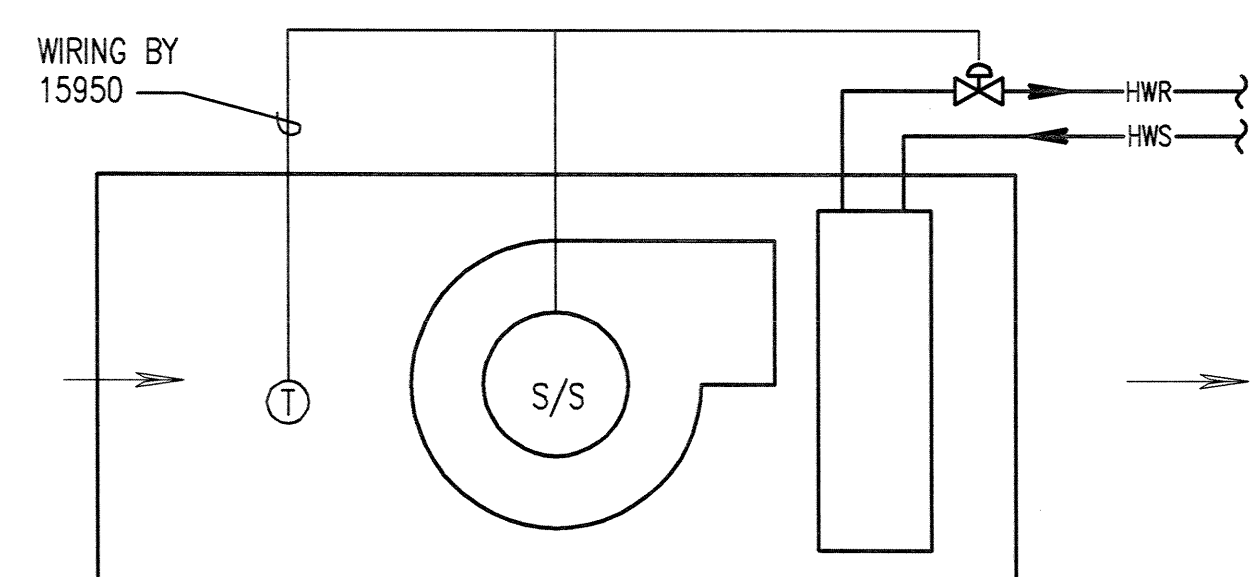


NOTES:
1 REFER TO DRAWINGS FOR UNITS WITH WALL MOUNTED THERMOSTATS


5 UNIT HEATERS & CABINET UNIT HEATERS (LINE VOLTAGE CONTROLS) (CUH-1,2)
M5.01 SCALE: NONE

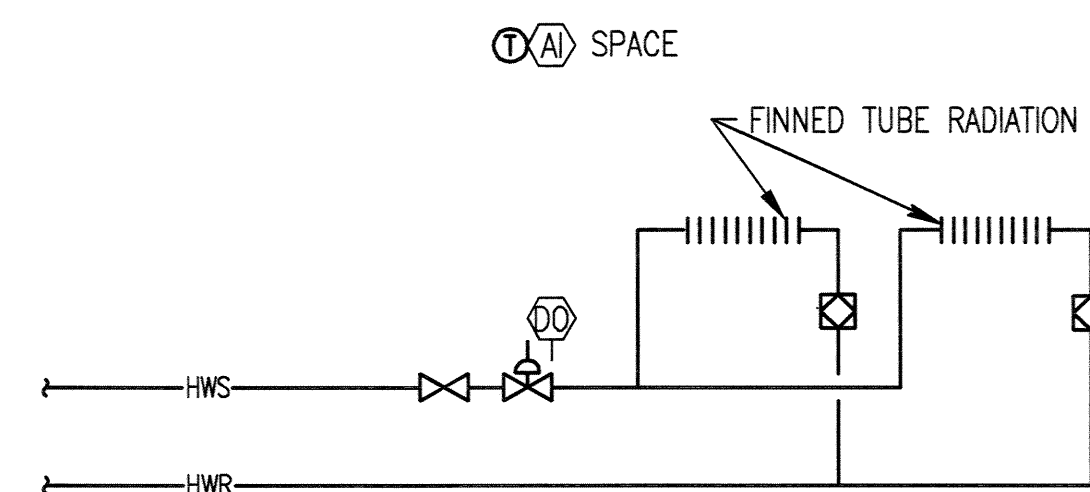

6 FINNED TUBE RADIATION (FTR-X)
M5.01 SCALE: NONE

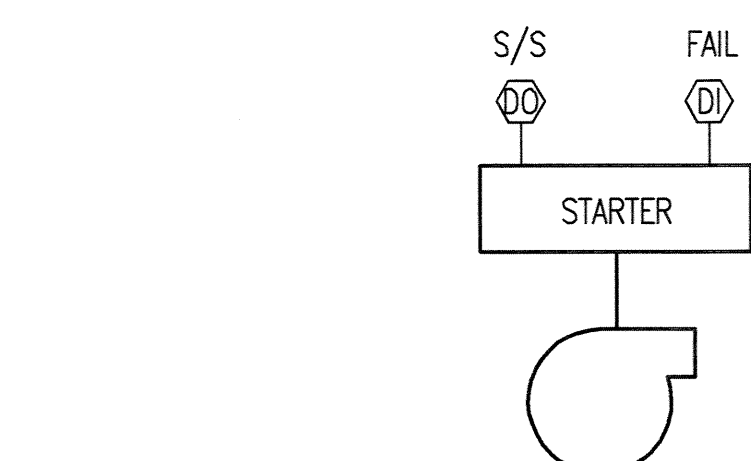


7 DOMESTIC HOT WATER RECIRCULATING PUMP
M5.1.1 SCALE: NONE

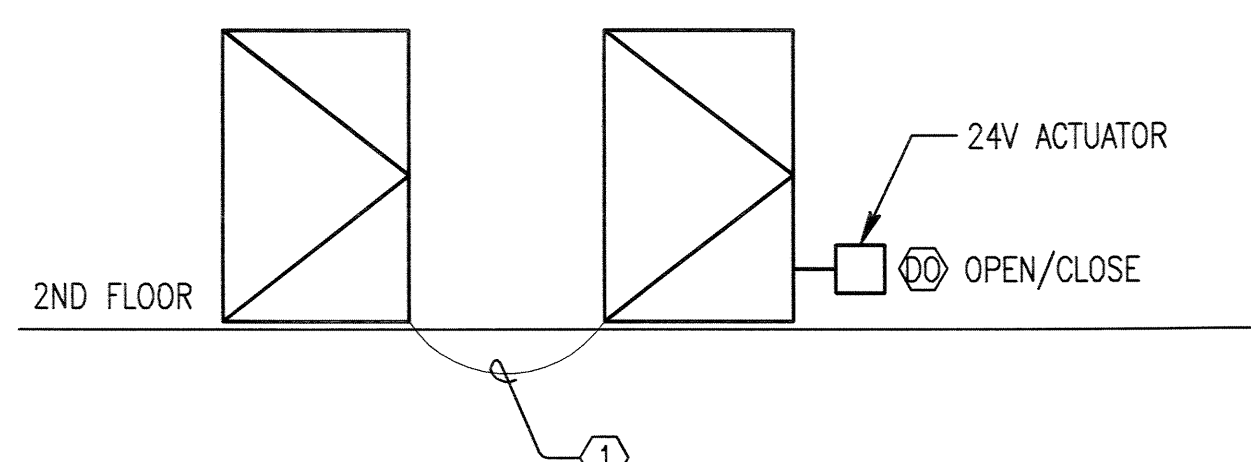

NOTES:
1 PROVIDE CONTROL WIRING TO EACH OPERABLE WINDOW ACTUATOR IN SECOND FLOOR READING AREA (TYP. 4).

8 NATURAL VENTILATION CONTROL
M5.01 SCALE: NONE

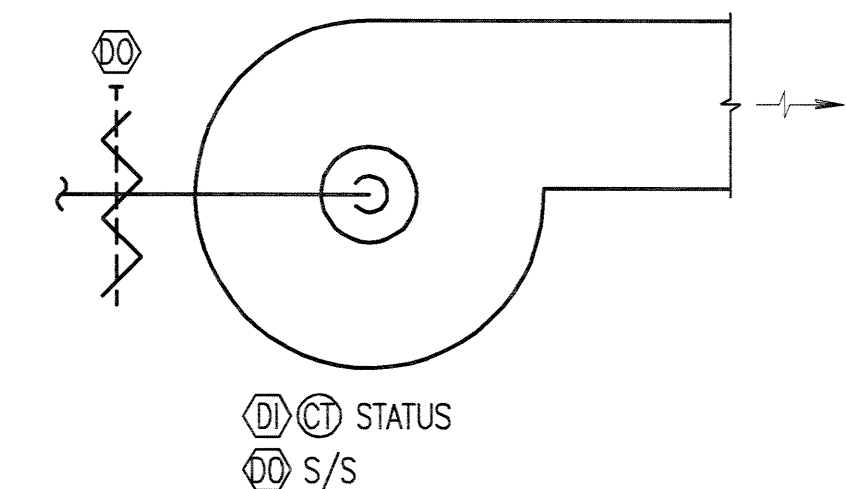

9 EXHAUST FAN CONTROL (EF-1, EF-2)
M5.01 SCALE: NONE

CONTROL DIAGRAMS - MECHANICAL

PCC ROCK CREEK CAMPUS
NEW BUILDING
PORTLAND COMMUNITY COLLEGE
ROCK CREEK CAMPUS
1703 NW Springdale Road
PORTLAND, OREGON 97229
THOMAS HACKER ARCHITECTS INC.
733 SW OAK STREET
PORTLAND, OREGON 97205
(503) 227-0254
PAE CONSULTING ENGINEERS
808 SW THIRD AVENUE
PORTLAND, OREGON 97204
(503) 226-2921

REVISIONS : 12-31-04

DATE : 02/14/03
SCALE : NONE


THOMAS HACKER
ARCHITECTS INC.



DRAWN BY : RRR
JOB NO. : 0115


DWG. NO.

M5.01

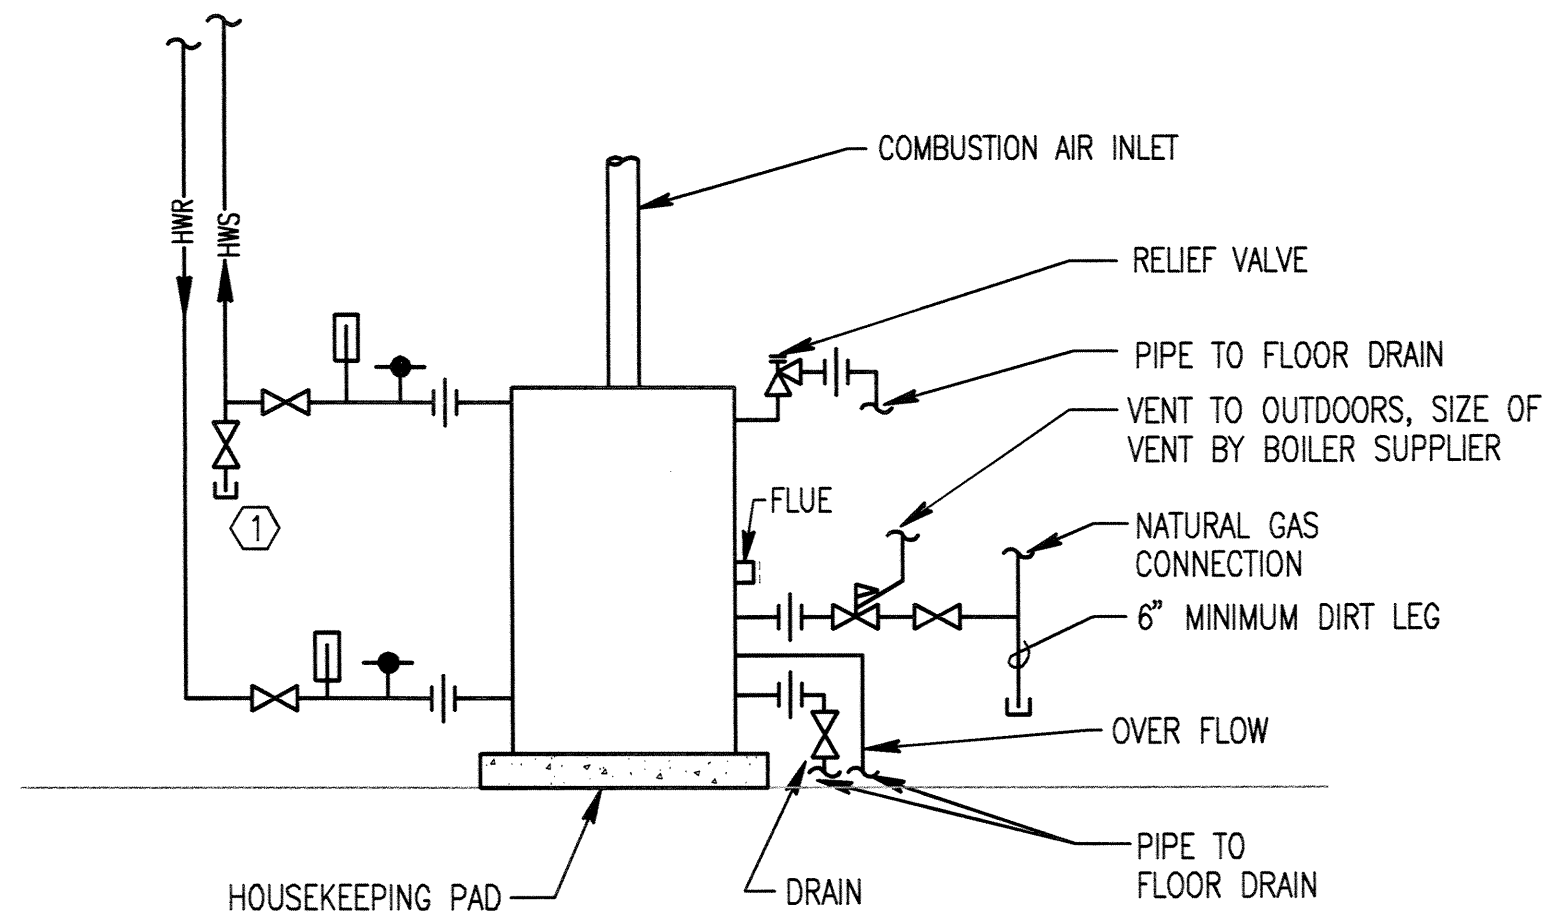


- NOTES:**
- ① HOSE CONNECTION FOR INITIAL BOILER HEATER CALIBRATION DURING START-UP.
 - ② PROVIDE BOILER AND VENT CONDENSATE DRAINS PER MFRS RECOMMENDATION.


1 BOILER PIPING
SCALE: NONE

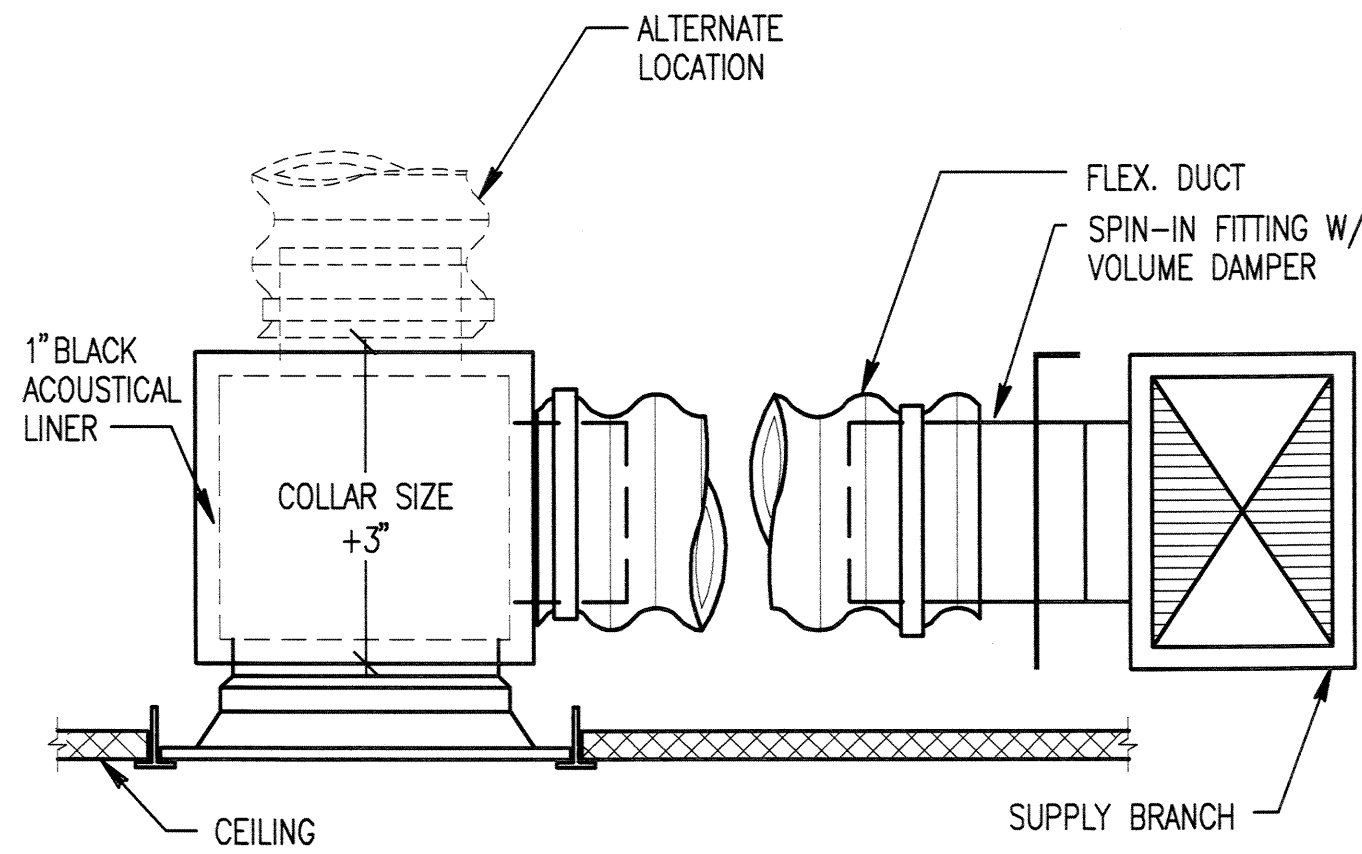

2 TYPICAL SQUARE NECK T-BAR DIFFUSER
SCALE: NONE

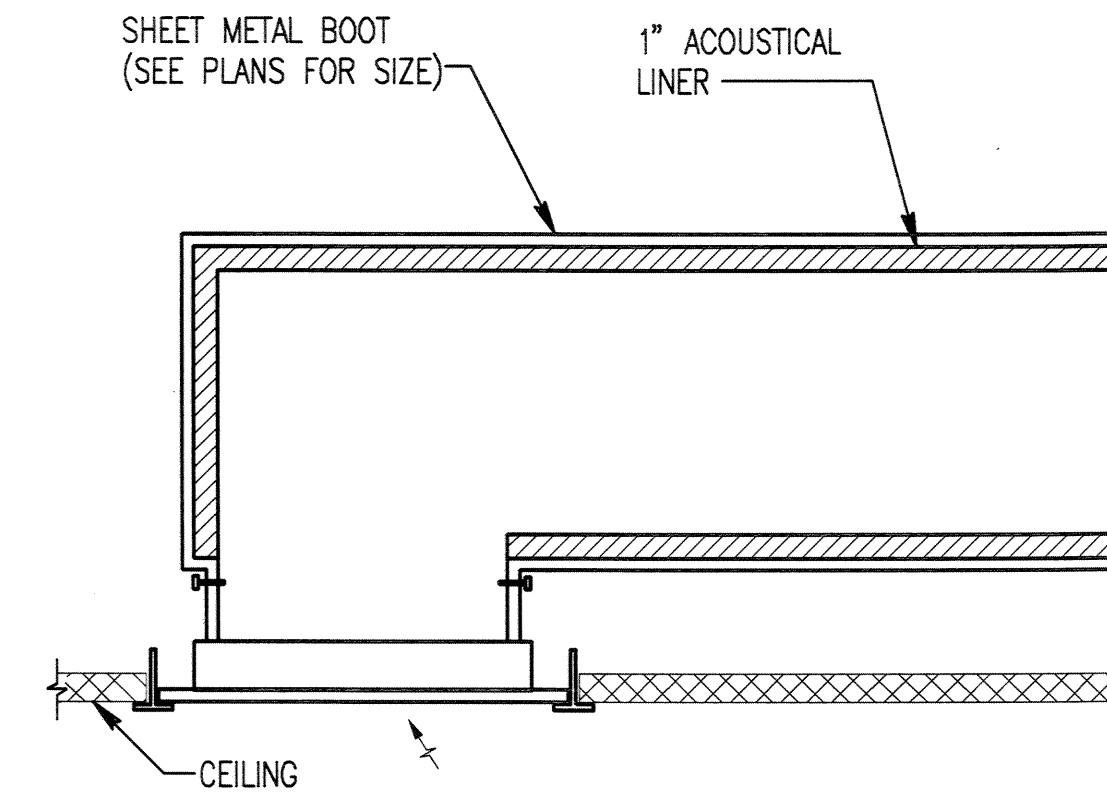

3 RETURN AIR BOOT
SCALE: NONE

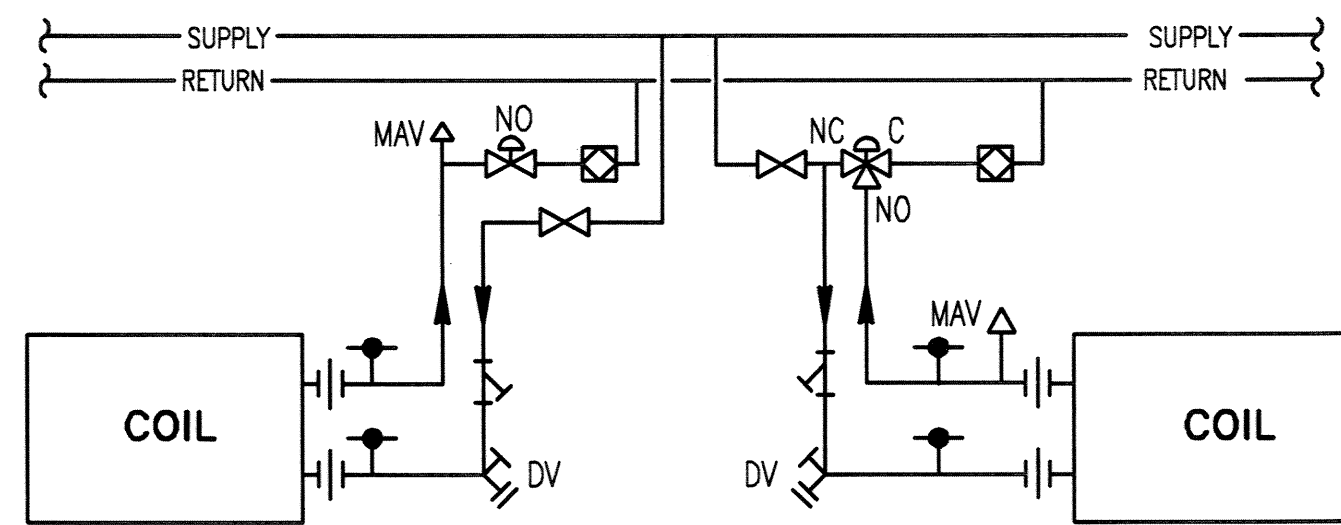


2-WAY VALVE
TYPICAL EXCEPT WHERE NOTED


3-WAY VALVE
USE ONLY WHERE NOTED

- NOTES:**
1. TYPICAL OF REHEAT COILS, UNIT HEATERS AND CABINET UNIT HEATERS.

4 HEATING COIL PIPING DETAIL
SCALE: NONE

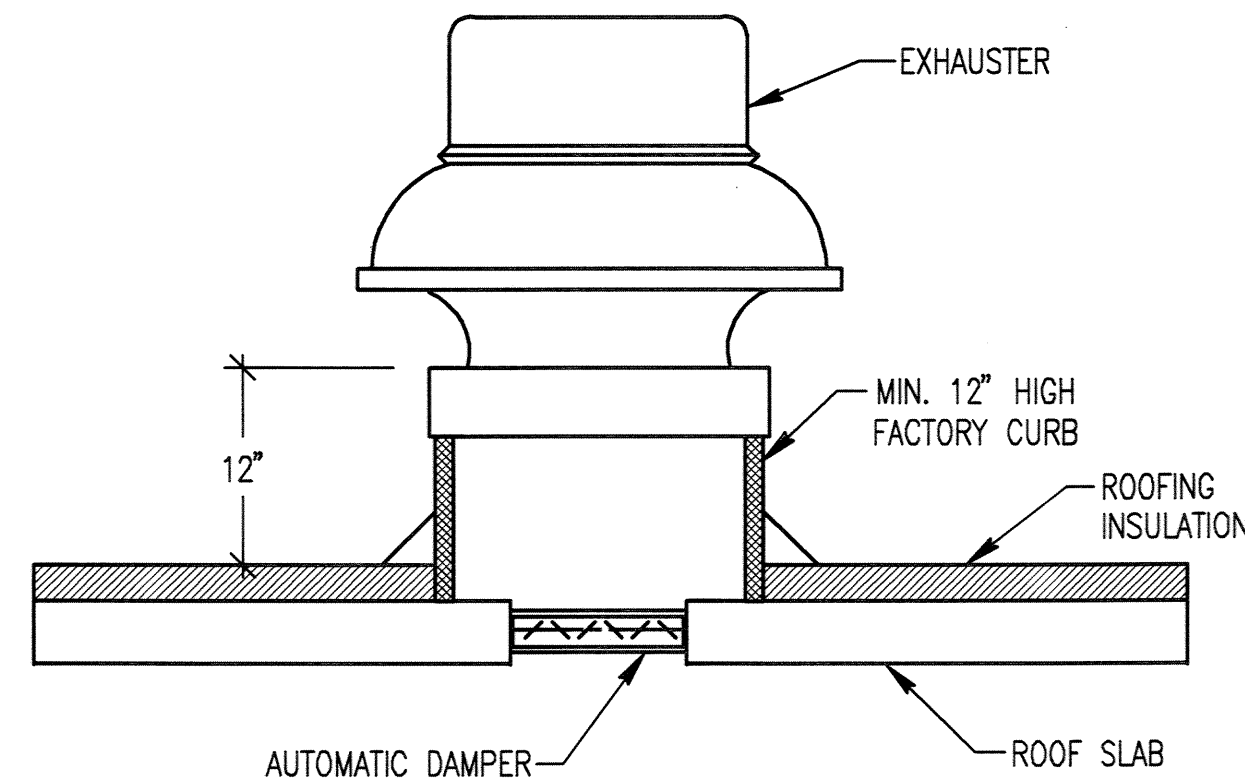


5 ROOF EXHAUSTER
SCALE: NONE

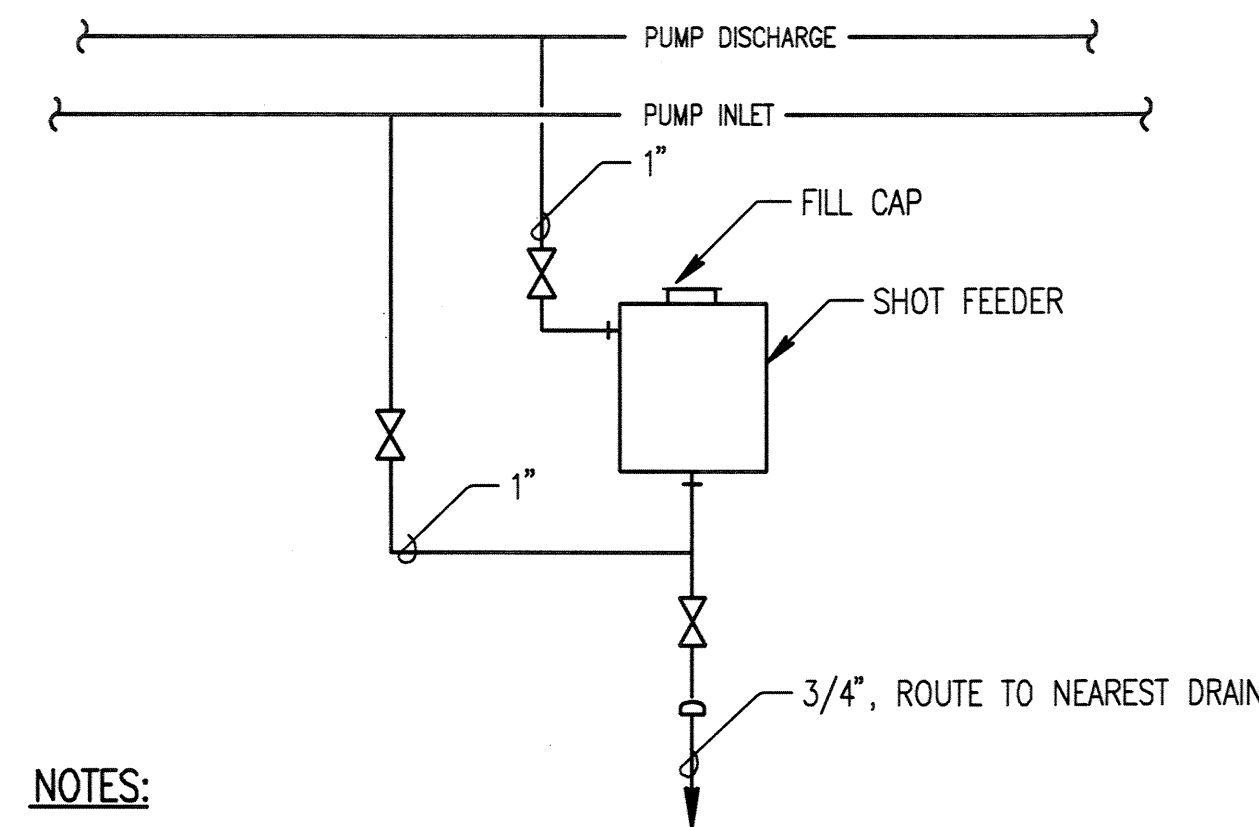


- NOTES:**
1. INSULATE PIPING AND CHEMICAL FEEDER.

6 BY-PASS/CHEMICAL FEEDER
SCALE: NONE

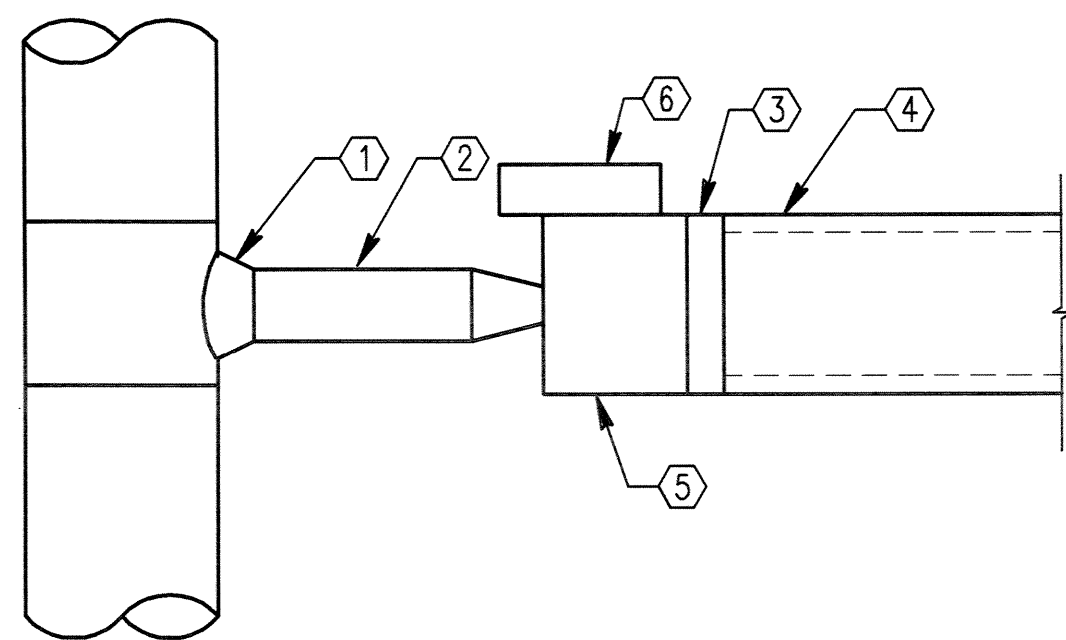


- NOTES:**
- ① CONICAL TEE
 - ② INLET DUCT. MINIMUM LENGTH = 3'-0". IF UNDER 10'-0" IN LENGTH, DUCT SIZE TO BE SAME SIZE AS TERMINAL UNIT. INLET, IF LENGTH IS 10'-0" OR OVER, DUCT SIZE TO BE AS SHOWN ON PLAN.
 - ③ HEATING COIL WHERE INDICATED
 - ④ DISCHARGE DUCT MINIMUM 5'-0" LONG BEFORE FIRST BRANCH TAKEOFF. SAME SIZE AS TERMINAL UNIT OUTLET, OR AS SHOWN ON PLAN, WHICHEVER IS LARGER. PROVIDE SOUND TRAP IF INDICATED. REFERENCE SECTION 15250 FOR DUCTLINER REQUIREMENTS.
 - ⑤ TERMINAL UNIT
 - ⑥ CONTROL ENCLOSURE. PROVIDE 36" CLEARANCE DIRECTLY IN FRONT OF ENCLOSURE. MOUNT CONTROLS AND PIPING CONNECTIONS ON SAME SIDE OF UNIT.

7 TYPICAL TERMINAL UNIT
SCALE: NONE

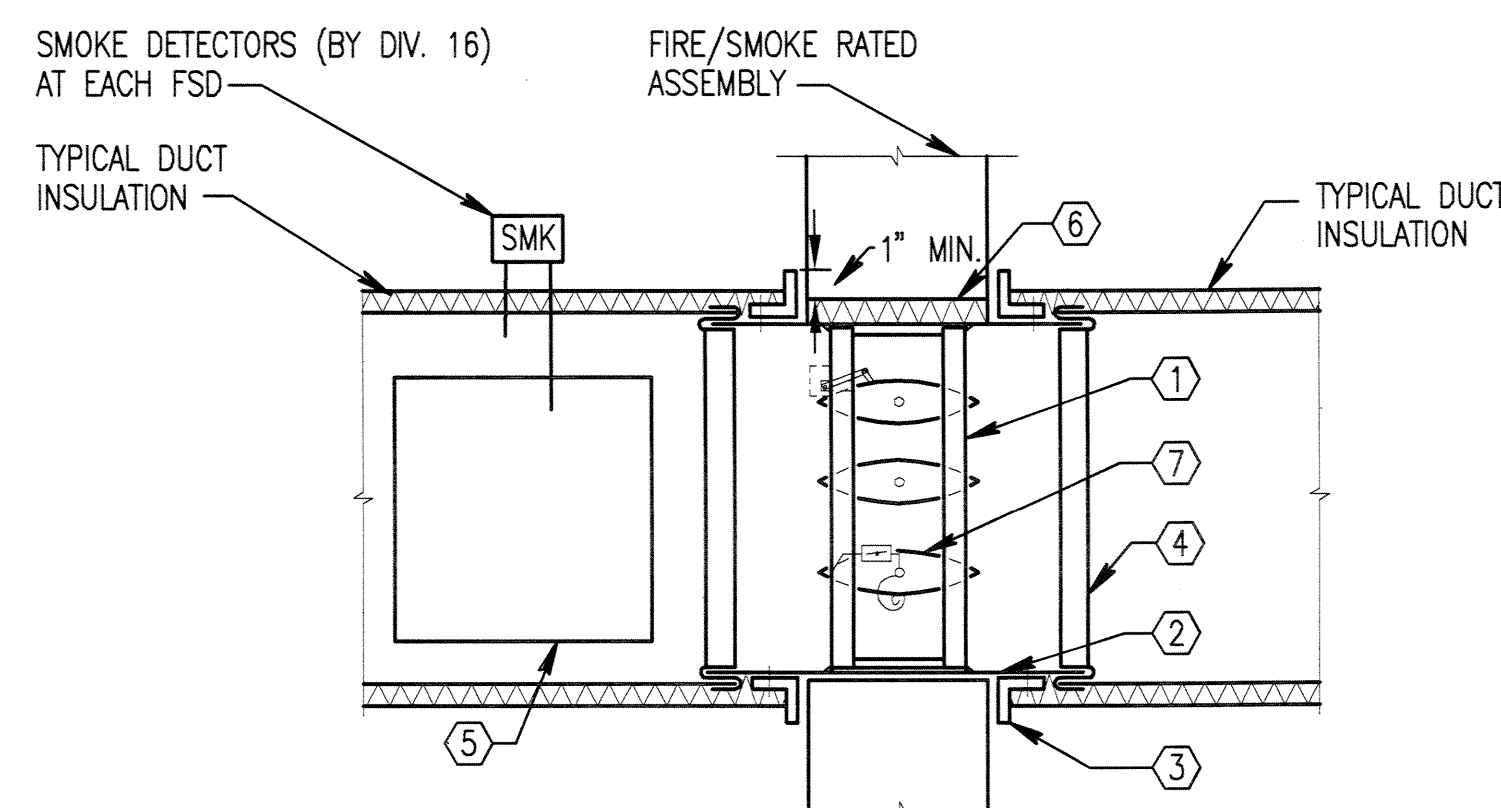

- NOTES:**
- ① COMBINATION FIRE AND SMOKE DAMPER (VERTICAL RETURN/EXHAUST TYPE SHOWN, HORIZONTAL & SUPPLY SIMILAR).
 - ② GALVANIZED STEEL SLEEVE-GUAGE NOT LESS THAN CONNECTION DUCT. FASTEN TO DAMPER FRAME AND PERIMETER ANGLES. CAULK BETWEEN DAMPER FRAME & SLEEVE.
 - ③ PERIMETER ANGLES-14 GA. GALVANIZED STEEL, 1-1/2" x 1-1/2" MIN. TO PROVIDE 1" MIN. OVERLAP OF OPENING ON ALL 4 SIDES. DO NOT FASTEN TO PARTITION.
 - ④ AIR TIGHT, BREAKAWAY DUCT CONNECTION.
 - ⑤ ACCESS PANEL-SIZE & LOCATION TO PERMIT SERVICING FUSIBLE ROD AND LINK.
 - ⑥ PROVIDE 15/16" TO 1/2" CLEARANCE ON HEIGHT & WIDTH, OR AS SPECIFIED BY DAMPER MANUFACTURER. FILL OPENING WITH FIRESTOP MATERIAL.
 - ⑦ INSTALL TO MANUFACTURER'S RECOMMENDATIONS.

8 COMBINATION FIRE/SMOKE DAMPER
SCALE: NONE

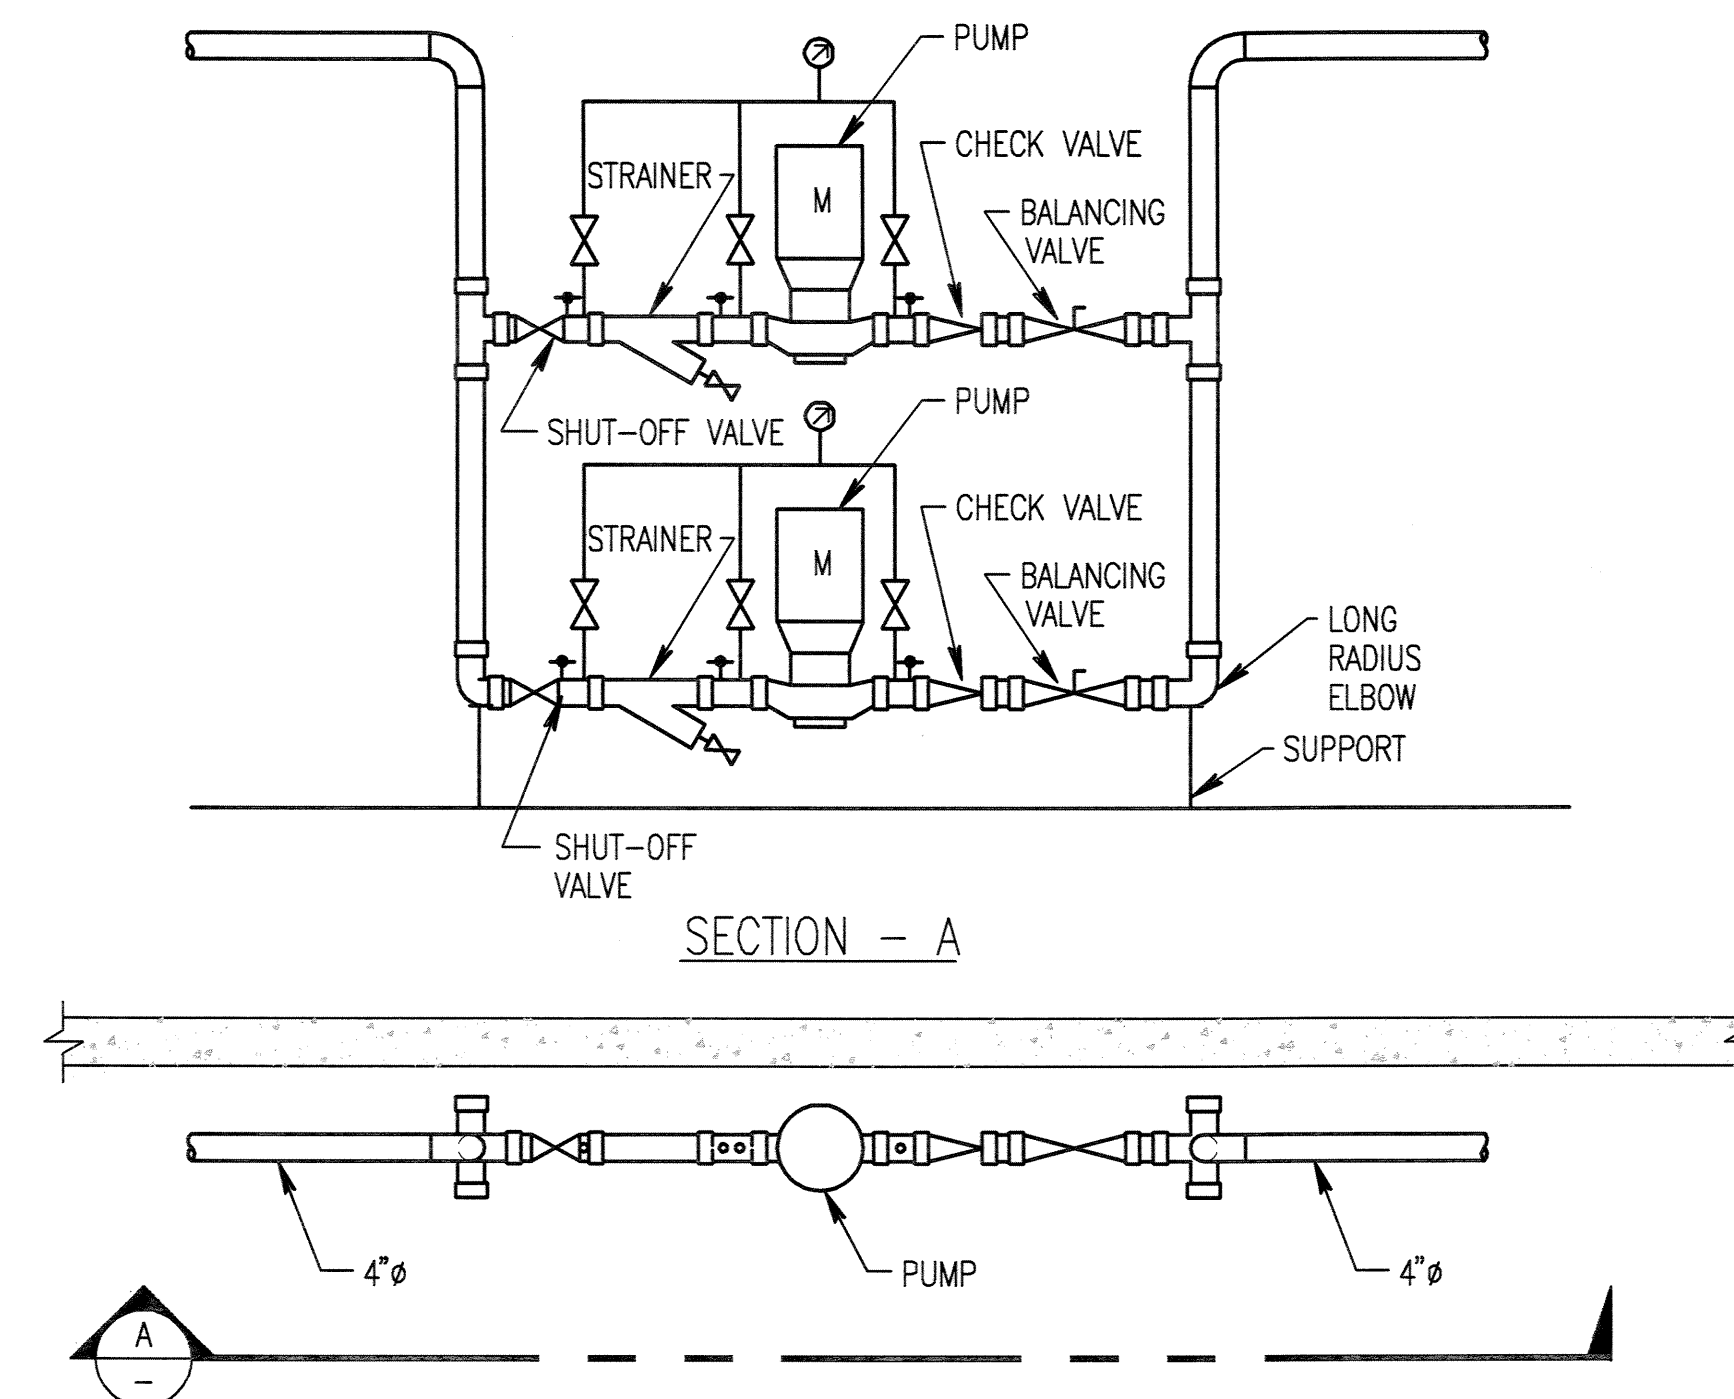

9 HYDRONIC PUMP PIPING
SCALE: NONE

DETAILS — MECHANICAL

PCC ROCK CREEK CAMPUS NEW BUILDING

PORTLAND COMMUNITY COLLEGE
ROCK CREEK CAMPUS
5700 NW Springdale Road
PORTLAND, OREGON 97229

THOMAS HACKER ARCHITECTS INC
733 SW OAK STREET
PORTLAND, OREGON 97205
503.227.1854

PAE CONSULTING ENGINEERS
808 SW THIRD AVENUE
PORTLAND, OREGON 97204
503.226.2921

REVISIONS : 1 03/21/03

DATE : 02/14/03
SCALE : NONE




EXPIRES 12-31-04
DRAWN BY : RRK
JOB NO. : 0115


DWG. NO. M6.01

THOMAS HACKER
ARCHITECTS INC.



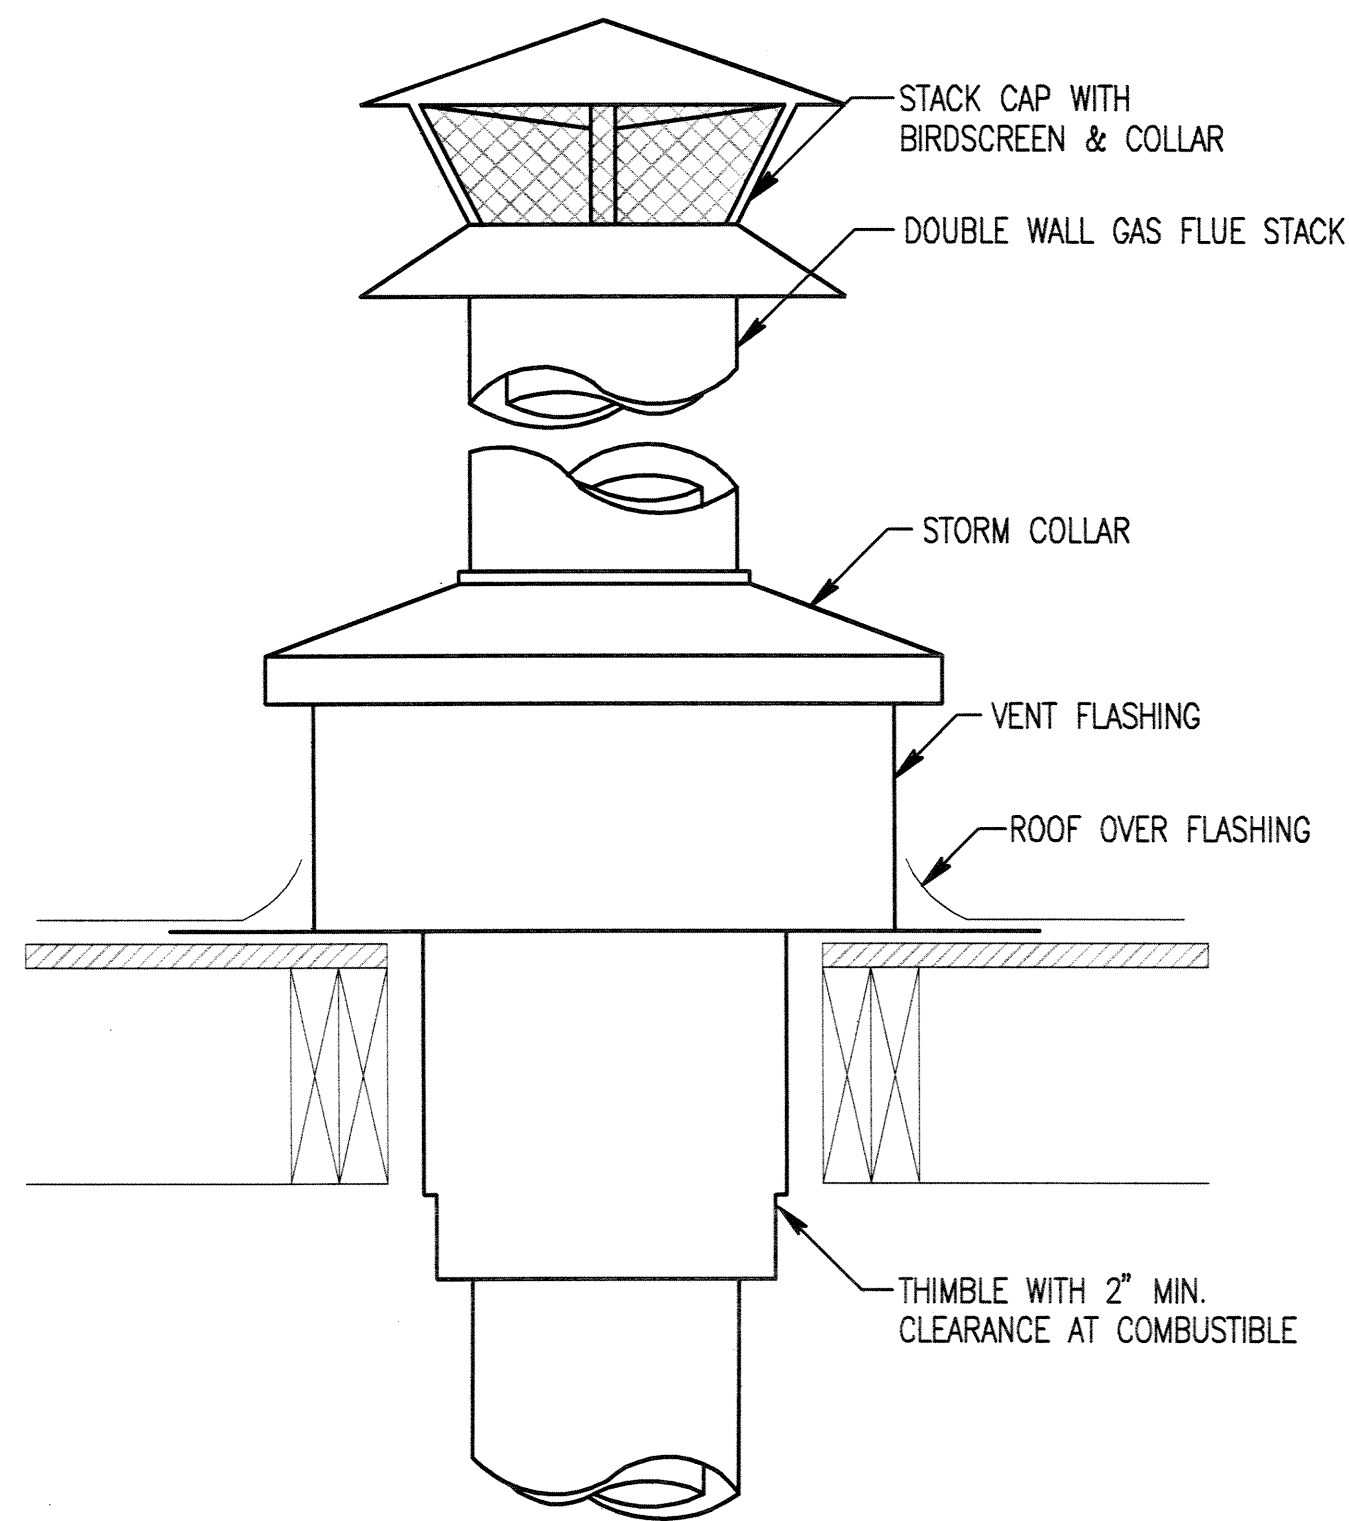


1 BOILER STACK DETAIL
SCALE: NONE

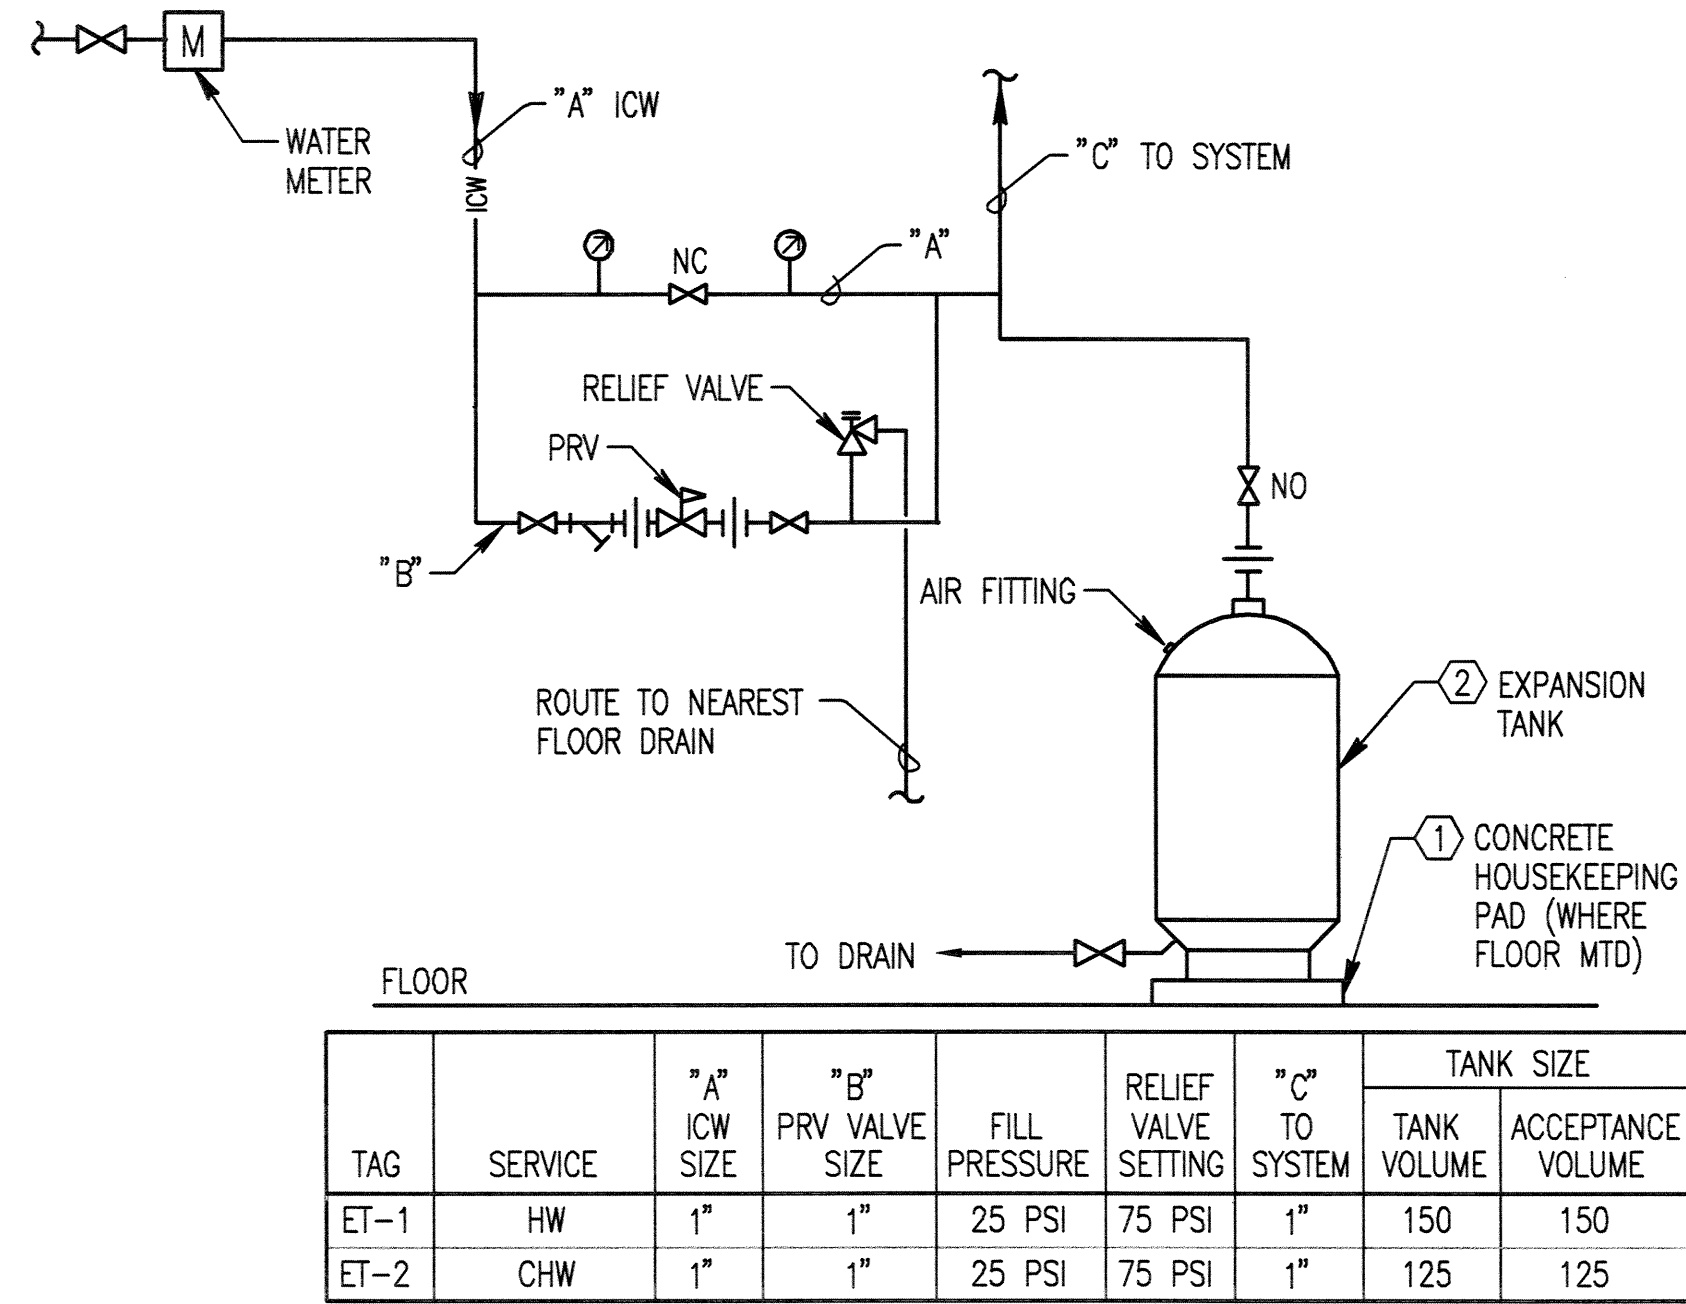


- NOTES:
- SEE SPECIFICATIONS FOR SEISMIC RESTRAINT REQUIREMENTS.
 - VERTICAL FLOOR MTD OR HORIZONTAL SUSPENDED FROM STRUCTURE AS INDICATED ON THE DRAWING.

2 EXPANSION TANK CONNECTION
SCALE: NONE

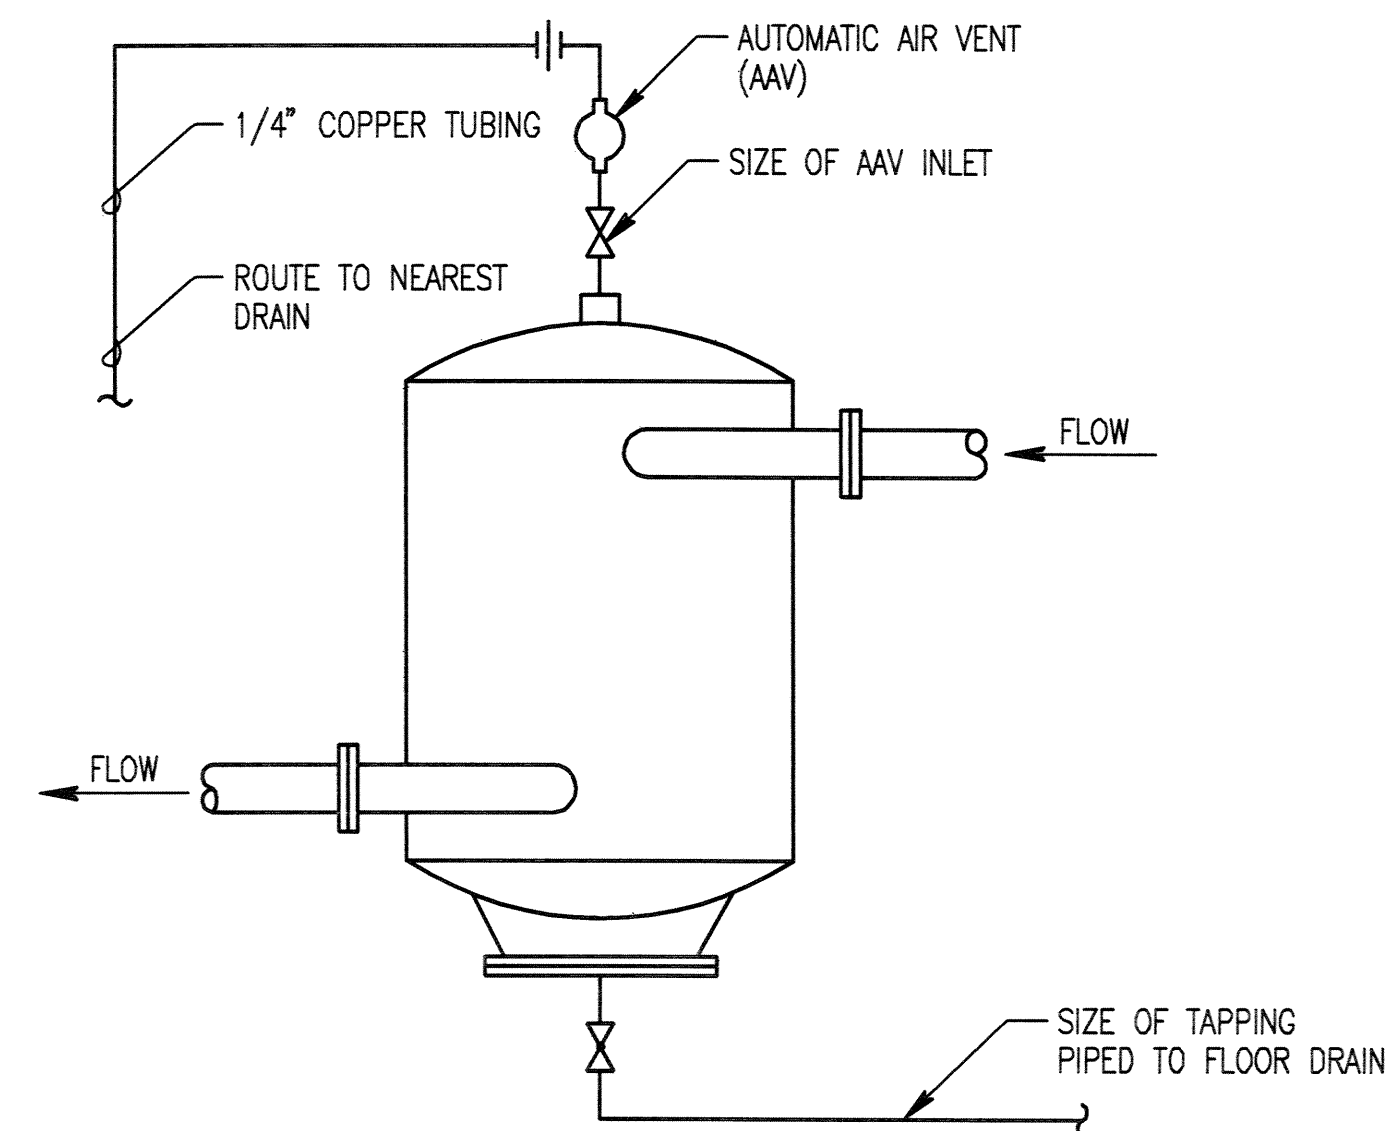


3 AIR SEPARATOR
SCALE: NONE

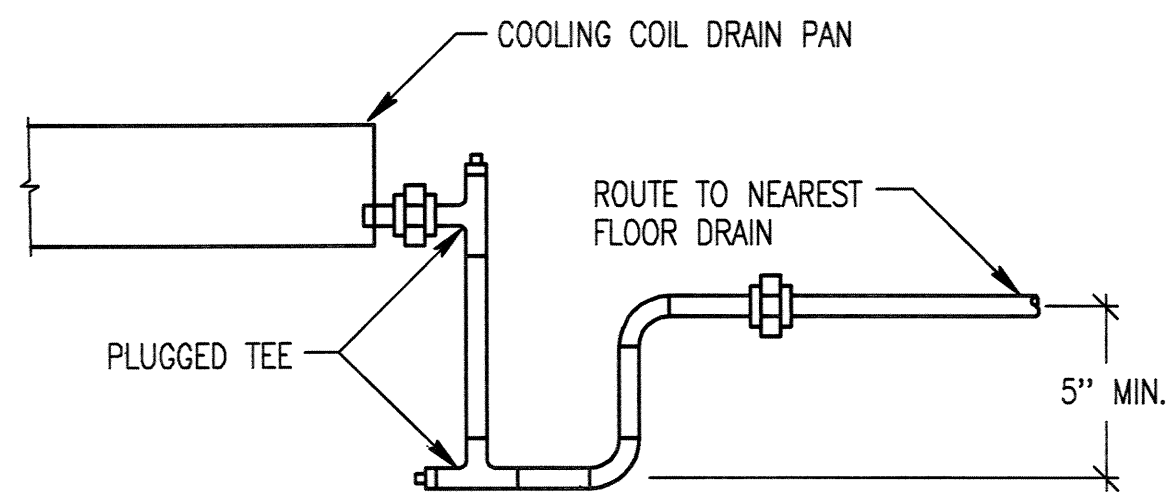


- NOTES:
- DRAIN SIZE IS OUTLET SIZE UNLESS SHOWN LARGER.

4 COIL DRAIN PIPING
SCALE: NONE

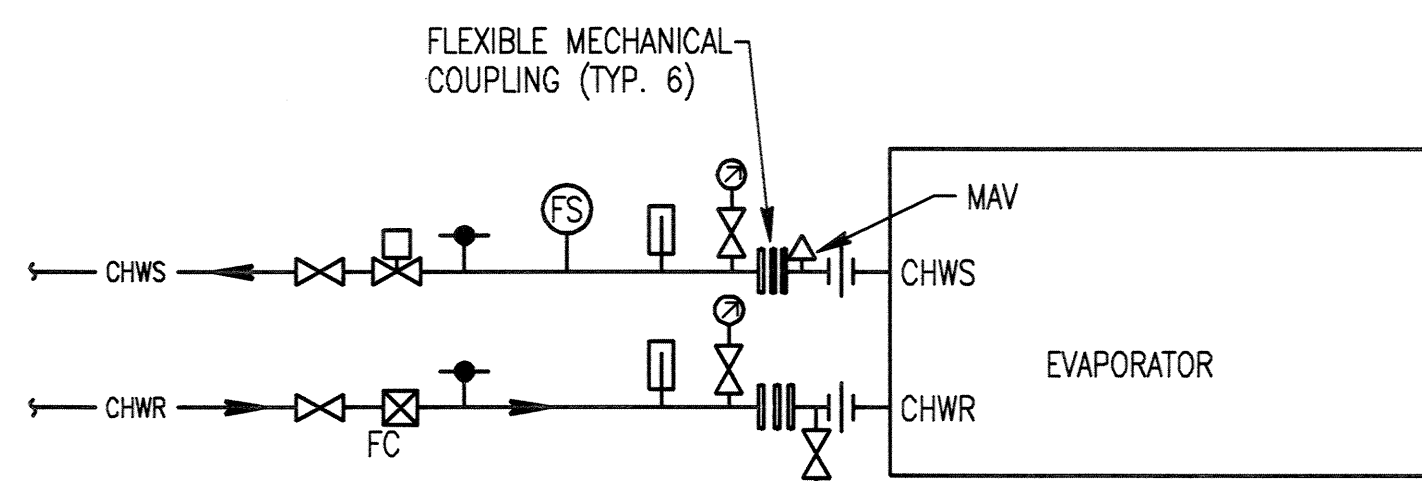


- GENERAL NOTES:
- INSTALL ALL PIPING TO ALLOW SERVICING AND REPAIR ACCESS. INCLUDE A UNION OR VICTAULIC TYPE COUPLING IN PIPING AT A LOCATION IN EACH PIPE THAT ALLOWS PIPES TO BE EASILY REMOVED FOR TUBE BUNDLE MAINTENANCE.
 - VIBRATION ISOLATION AND SEISMIC RESTRAINT PER SECTION 15240.

5 CHILLER PIPING CONNECTIONS
SCALE: NONE

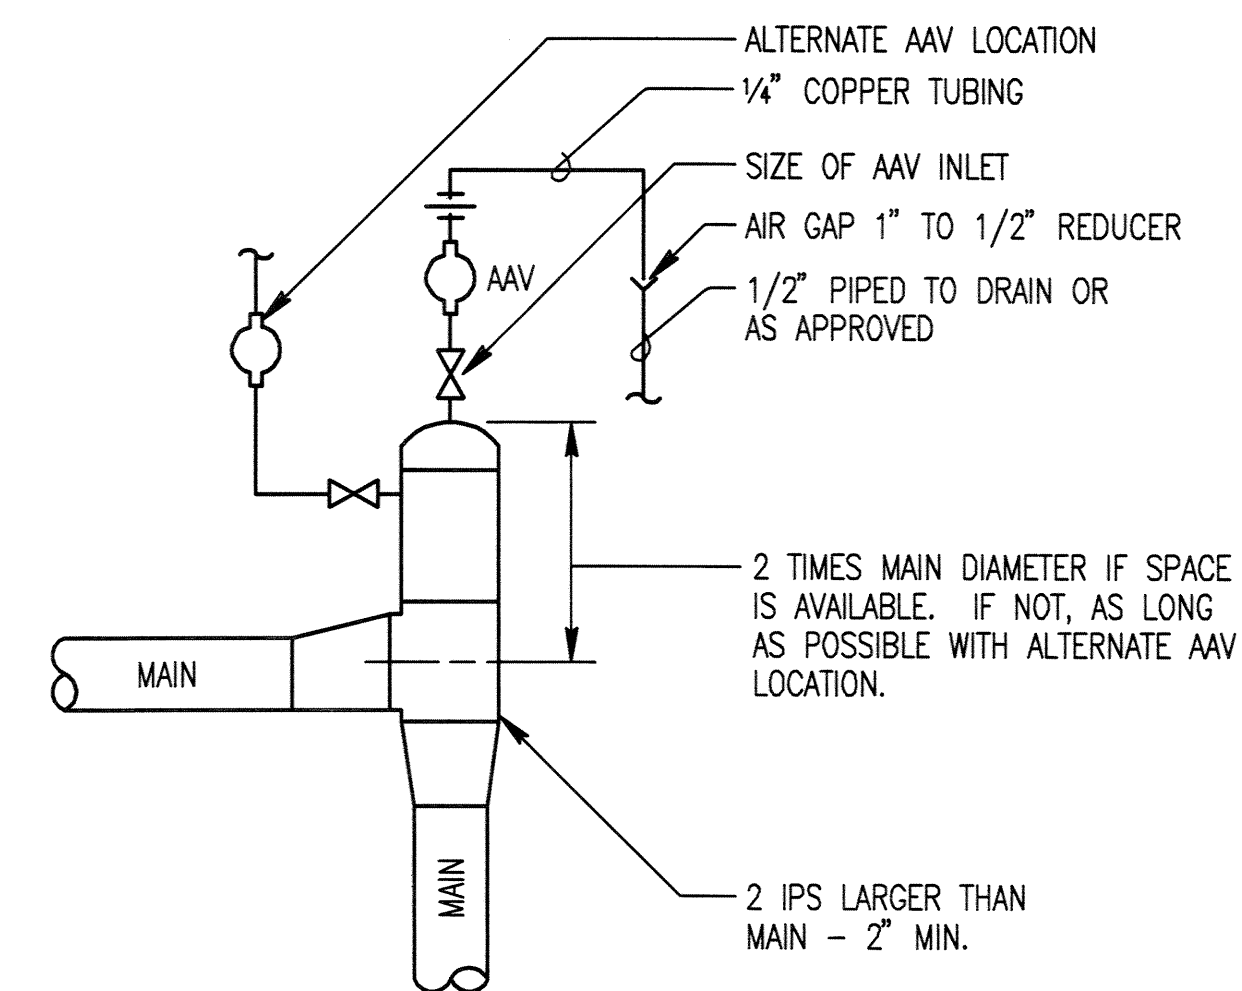


6 AUTOMATIC AIR VENT
SCALE: NONE

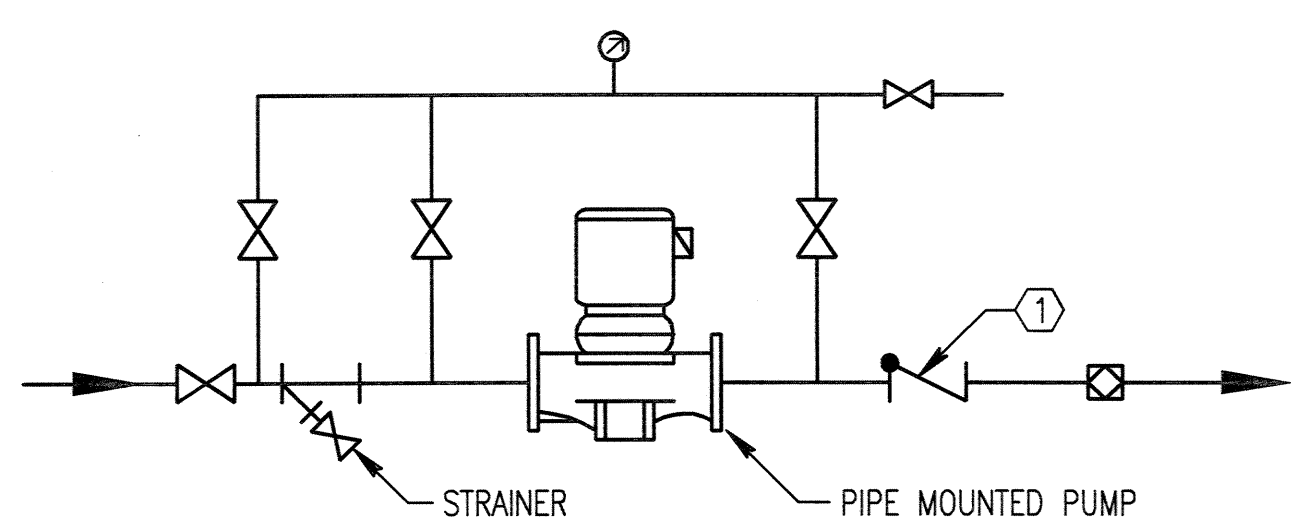


- NOTES:
- PROVIDE CHECK VALVE ONLY FOR PUMPS INSTALLED IN PARALLEL.
 - SUPPORT PUMP FROM PIPING.

7 PIPE MOUNTED PUMP
SCALE: NONE

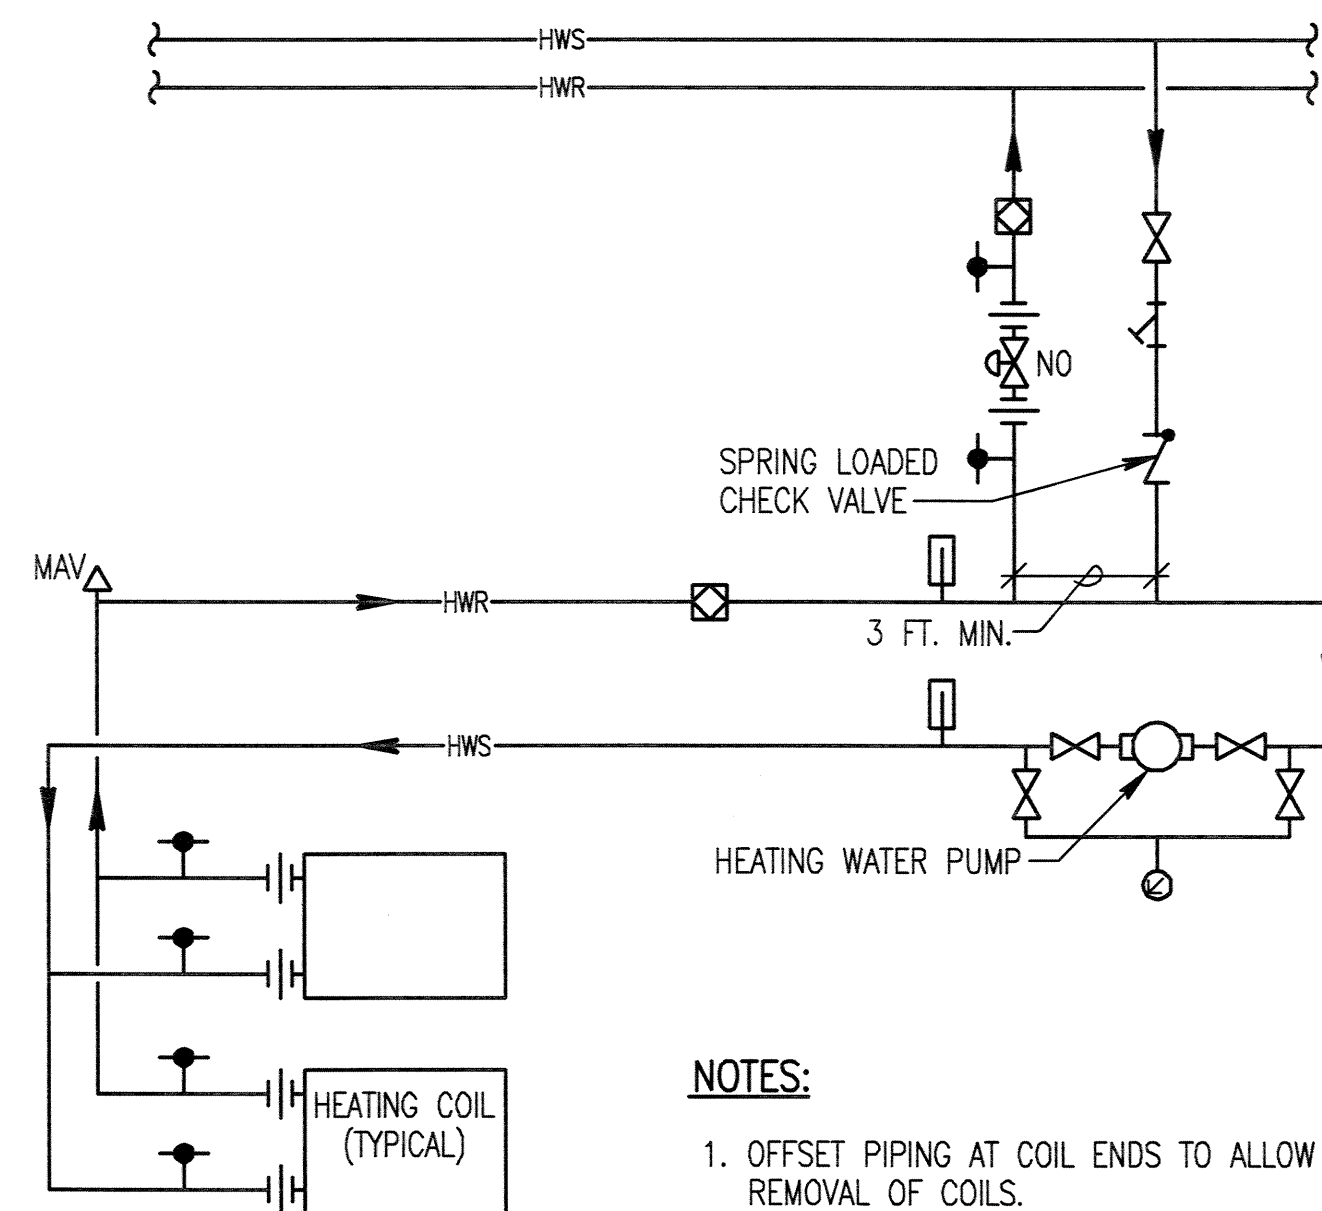

- NOTES:
- OFFSET PIPING AT COIL ENDS TO ALLOW REMOVAL OF COILS.
 - THREE OR MORE COILS PIPED SIMILAR.

8 AHU HEATING COIL PIPING
SCALE: NONE

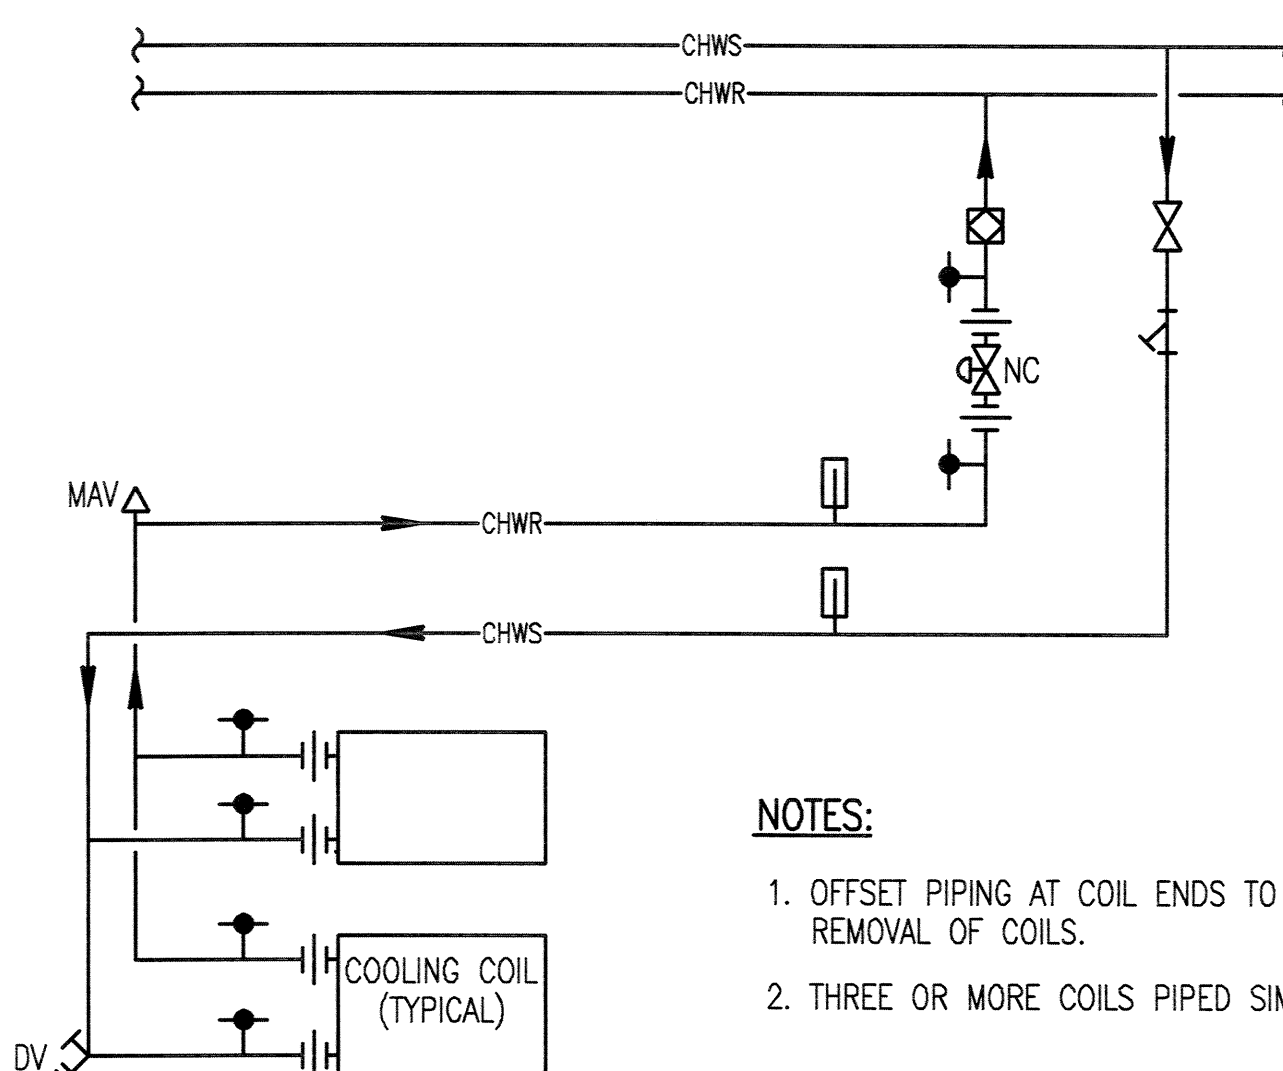

- NOTES:
- OFFSET PIPING AT COIL ENDS TO ALLOW REMOVAL OF COILS.
 - THREE OR MORE COILS PIPED SIMILAR.

9 AHU COOLING COIL PIPING
SCALE: NONE

DETAILS - MECHANICAL

PCC ROCK CREEK CAMPUS NEW BUILDING

PORTLAND COMMUNITY COLLEGE
ROCK CREEK CAMPUS
5702 NW Spring Road
PORTLAND, OREGON 97204

THOMAS HACKER ARCHITECTS INC.
735 SW GALE STREET
PORTLAND, OREGON 97205
(503) 227-1254

PAE CONSULTING ENGINEERS
808 SW THIRD AVENUE
PORTLAND, OREGON 97204
(503) 226-2921

REVISIONS :

DATE : 02/14/03
SCALE : NONE



EXPIRES 12-31-04
DRAWN BY : RRK
JOB NO. : 0115

DWG. NO.

M6.02

THOMAS HACKER
ARCHITECTS INC.



PLUMBING DESIGN CRITERIA

DOMESTIC WATER PIPING SYSTEM
BASIS OF DESIGN: 2000 OREGON STATE PLUMBING SPECIALTY CODE APPENDIX A "SIZING WATER SYSTEMS". PIPING SIZED ON 3.5 PSI/100 FT. DROP, NOT TO EXCEED 8 FT./SEC. VELOCITY.

WASTE AND VENT PIPING SYSTEM
BASIS OF DESIGN: 2000 OREGON STATE PLUMBING SPECIALTY CODE, CHAPTER 7 "SANITARY DRAINAGE". ALL WASTE PIPING SIZED AT 1/4"/FT. UNLESS OTHERWISE NOTED.

ROOF DRAIN/STORM DRAIN PIPING SYSTEMS
BASIS OF DESIGN: 2000 OREGON STATE PLUMBING SPECIALTY CODE, CHAPTER 11 "STORM AND GROUNDWATER DRAINAGE". STORM DRAIN SYSTEM SIZED AT 3"/HR RAINFALL AND 1/4"/FT SLOPE UNLESS OTHERWISE INDICATED ON DRAWINGS.

NATURAL GAS SYSTEM
BASIS OF DESIGN: 1999 OREGON STATE MECHANICAL SPECIALTY CODE, CHAPTER 13, "FUEL-GAS PIPING". EQUIVALENT LENGTH OF PIPE: 100 FT (g)

PLUMBING FIXTURE SCHEDULE						
SYMBOL	DESCRIPTION	ROUGH-IN		SIZE-INCHES		REMARKS
		W	V	CW	HW	
WC-1	WATER CLOSET	4	2	1½	—	WALL HUNG
WC-2	WATER CLOSET	4	2	1½	—	WALL HUNG, ADA,
U-1	URINAL	2	1½	¾	—	WALL HUNG, ADA,
L-1	LAVATORY	2	1½	½	½	WALL HUNG, ADA
S-1	SINK	2	1½	½	½	25" x 22" x 6½", SINGLE COMPARTMENT, S.S., ADA GARBAGE DISPOSAL, INSTA-HOT
S-2	SINK	2	1½	½	½	17" x 17" x 12", SINGLE COMPARTMENT, S.S. GARBAGE DISPOSAL
S-3	HAND SINK	2	1½	½	½	15"15"x6½", SINGLE COMP., S.S.
MS-1	MOP SINK	3	1½	½	½	FLOOR, CORNER
DF-1	DRINKING FOUNTAIN	2	1½	½	—	DUAL HEIGHT, ADA


PLUMBING EQUIPMENT SCHEDULE		
ITEM	DESCRIPTION	ELECTRICAL
GWH-1	GAS WATER HEATER 150 CFH INPUT 100 GALLON STORAGE, 214 GPH RECOVERY @ 80°F RISE BASED ON: A.O. SMITH MODEL: 8TH-150	3.0 FLA 120 V 1 PH
DET-1	DOMESTIC WATER EXPANSION TANK 2.4 GALLONS ACCEPTANCE VOLUME 4.7 GALLONS TANK VOLUME BASED ON: AMTROL AST-12-C	-
RHWP-1	RECIRCULATING HOT WATER PUMP 1 GPM AT 9 FEET HEAD BASED ON: GRUNDFOS UPS-15-42	1/8 HP 120 V 1 PH
RPBP-1 & RBPB-2 (HVAC MAKE-UP)	REDUCED PRESSURE BACKFLOW PREVENTOR 8 GPM @ 10 PSI MAX WATER PRESSURE DROP BASED ON: WAITS 909 (1")	-
GPRV-1 (GWH-1)	GAS PRESSURE REGULATOR VALVE 150 CFH, 2 PSI INLET, INCHES OUTLET TO BE COMPATIBLE WITH GAS WATER HEATER BASED ON: EQUIMETER 043	-
GPRV-2 (B-1)	GAS PRESSURE REGULATOR VALVE 1000 CFH, 2 PSI INLET, INCHES OUTLET TO BE COMPATIBLE WITH BOILER BASED ON: ROCKWELL	-
GPRV-3 (B-2)	GAS PRESSURE REGULATOR VALVE 1000 CFH, 2 PSI INLET, INCHES OUTLET TO BE COMPATIBLE WITH BOILER BASED ON: ROCKWELL	-
GPRV-4 (B-3)	GAS PRESSURE REGULATOR VALVE 1000 CFH, 2 PSI INLET, INCHES OUTLET TO BE COMPATIBLE WITH BOILER BASED ON: ROCKWELL	-
SP-1 & SP-2	ELEVATOR SUMP PUMP 10 GPM @ 24 FT HEAD BASED ON: PACO P1P701A	1/2 HP 120 V 1 PH

MISC. VALVES & COCKS

	SHUT-OFF VALVE
	GLOBE VALVE
	SHUT-OFF VALVE W/ TAMPER SWITCH
	CHECK VALVE
	BALANCING VALVE
	PRESSURE REDUCING VALVE
	RELIEF VALVE
	STRAINER
	DRAIN VALVE
	HOSE BIBB
	WALL HYDRANT
	PRESSURE GAUGE
	THERMOMETER
	FLOW SWITCH
	SHOCK ARRESTER
	VACUUM BREAKER
	REDUCED PRESSURE BACKFLOW PREVENTER
	OUTSIDE SCREW & YOKE


FIRE PROTECTION SYMBOLS	
	FIRE PROTECTION
	FIRE SPRINKLER
	ANTI-FREEZE FIRE SPRINKLER
	FIRE DEPARTMENT CONNECTION
	UPRIGHT SPRINKLER HEAD
	PENDANT SPRINKLER HEAD
	SIDEWALL SPRINKLER HEAD
	FLOW SWITCH
	SUPERVISED SHUT-OFF VALVE
	FIRE PROTECTION SYSTEM ZONE BOUNDARY

 PLUMBING SYMBOLS

	TB	THRUST BLOCK
	CO	CLEANOUT
	WCO	WALL CLEANOUT
	FCO	FLOOR CLEANOUT
	CTG	CLEANOUT TO GRADE
	FD	FLOOR DRAIN
	AD	AREA DRAIN
	CB	CATCH BASIN
	FS	FLOOR SINK
	RD	ROOF DRAIN
	OD	OVERFLOW DRAIN
		DOWNSPOUT NOZZLE
	TD	TRENCH DRAIN
	MH	MANHOLE (INVERTS IN & OUT)

PLUMBING		PIPING	
_____	W	WASTE	(ABOVE GRADE OR FLOOR)
_____	W	WASTE	(BELOW GRADE OR FLOOR)
_____ PW _____	PW	PUMPED WASTE	(ABOVE GRADE OR FLOOR)
_____ PW _____	PW	PUMPED WASTE	(BELOW GRADE OR FLOOR)
_____ SD _____	SD	STORM DRAIN	(ABOVE GRADE OR FLOOR)
_____ SD _____	SD	STORM DRAIN	(BELOW GRADE OR FLOOR)
_____ OD _____	OD	OVERFLOW DRAIN	(ABOVE GRADE OR FLOOR)
_____ OD _____	OD	OVERFLOW DRAIN	(BELOW GRADE OR FLOOR)
_____ D _____	D	DRAIN	(CONDENSATE/INDIRECT)
_____ V _____	V	VENT	
_____ CW _____	CW	COLD WATER	
_____ HW _____	HW	HOT WATER	
_____ RHW _____	RHW	RECIRCULATING HOT WATER	
_____ ICW _____	ICW	INDUSTRIAL COLD WATER	
_____ G _____	G	NATURAL GAS (2 PSI)	
_____ GV _____	GV	GAS VENT	

MISC. FITTINGS & SYMBOLS	
	DIRECTION OF FLOW
	DIRECTION OF SLOPE
	PIPE SLEEVE
	REDUCER
	ANCHOR
	ELBOW (90°)
	ELBOW (45°)
	TEE
	CROSS
	JOINT OR COUPLING POINT
	UNION
	FLANGED CONNECTION
	CAP
	PLUG OR BLIND FLANGE
	RISER
	ELBOW UP
	ELBOW DOWN
	TEE UP
	TEE DOWN
	HORIZONTAL TEE
	FLEXIBLE CONNECTION
	BALL JOINT
	MECHANICAL COUPLING

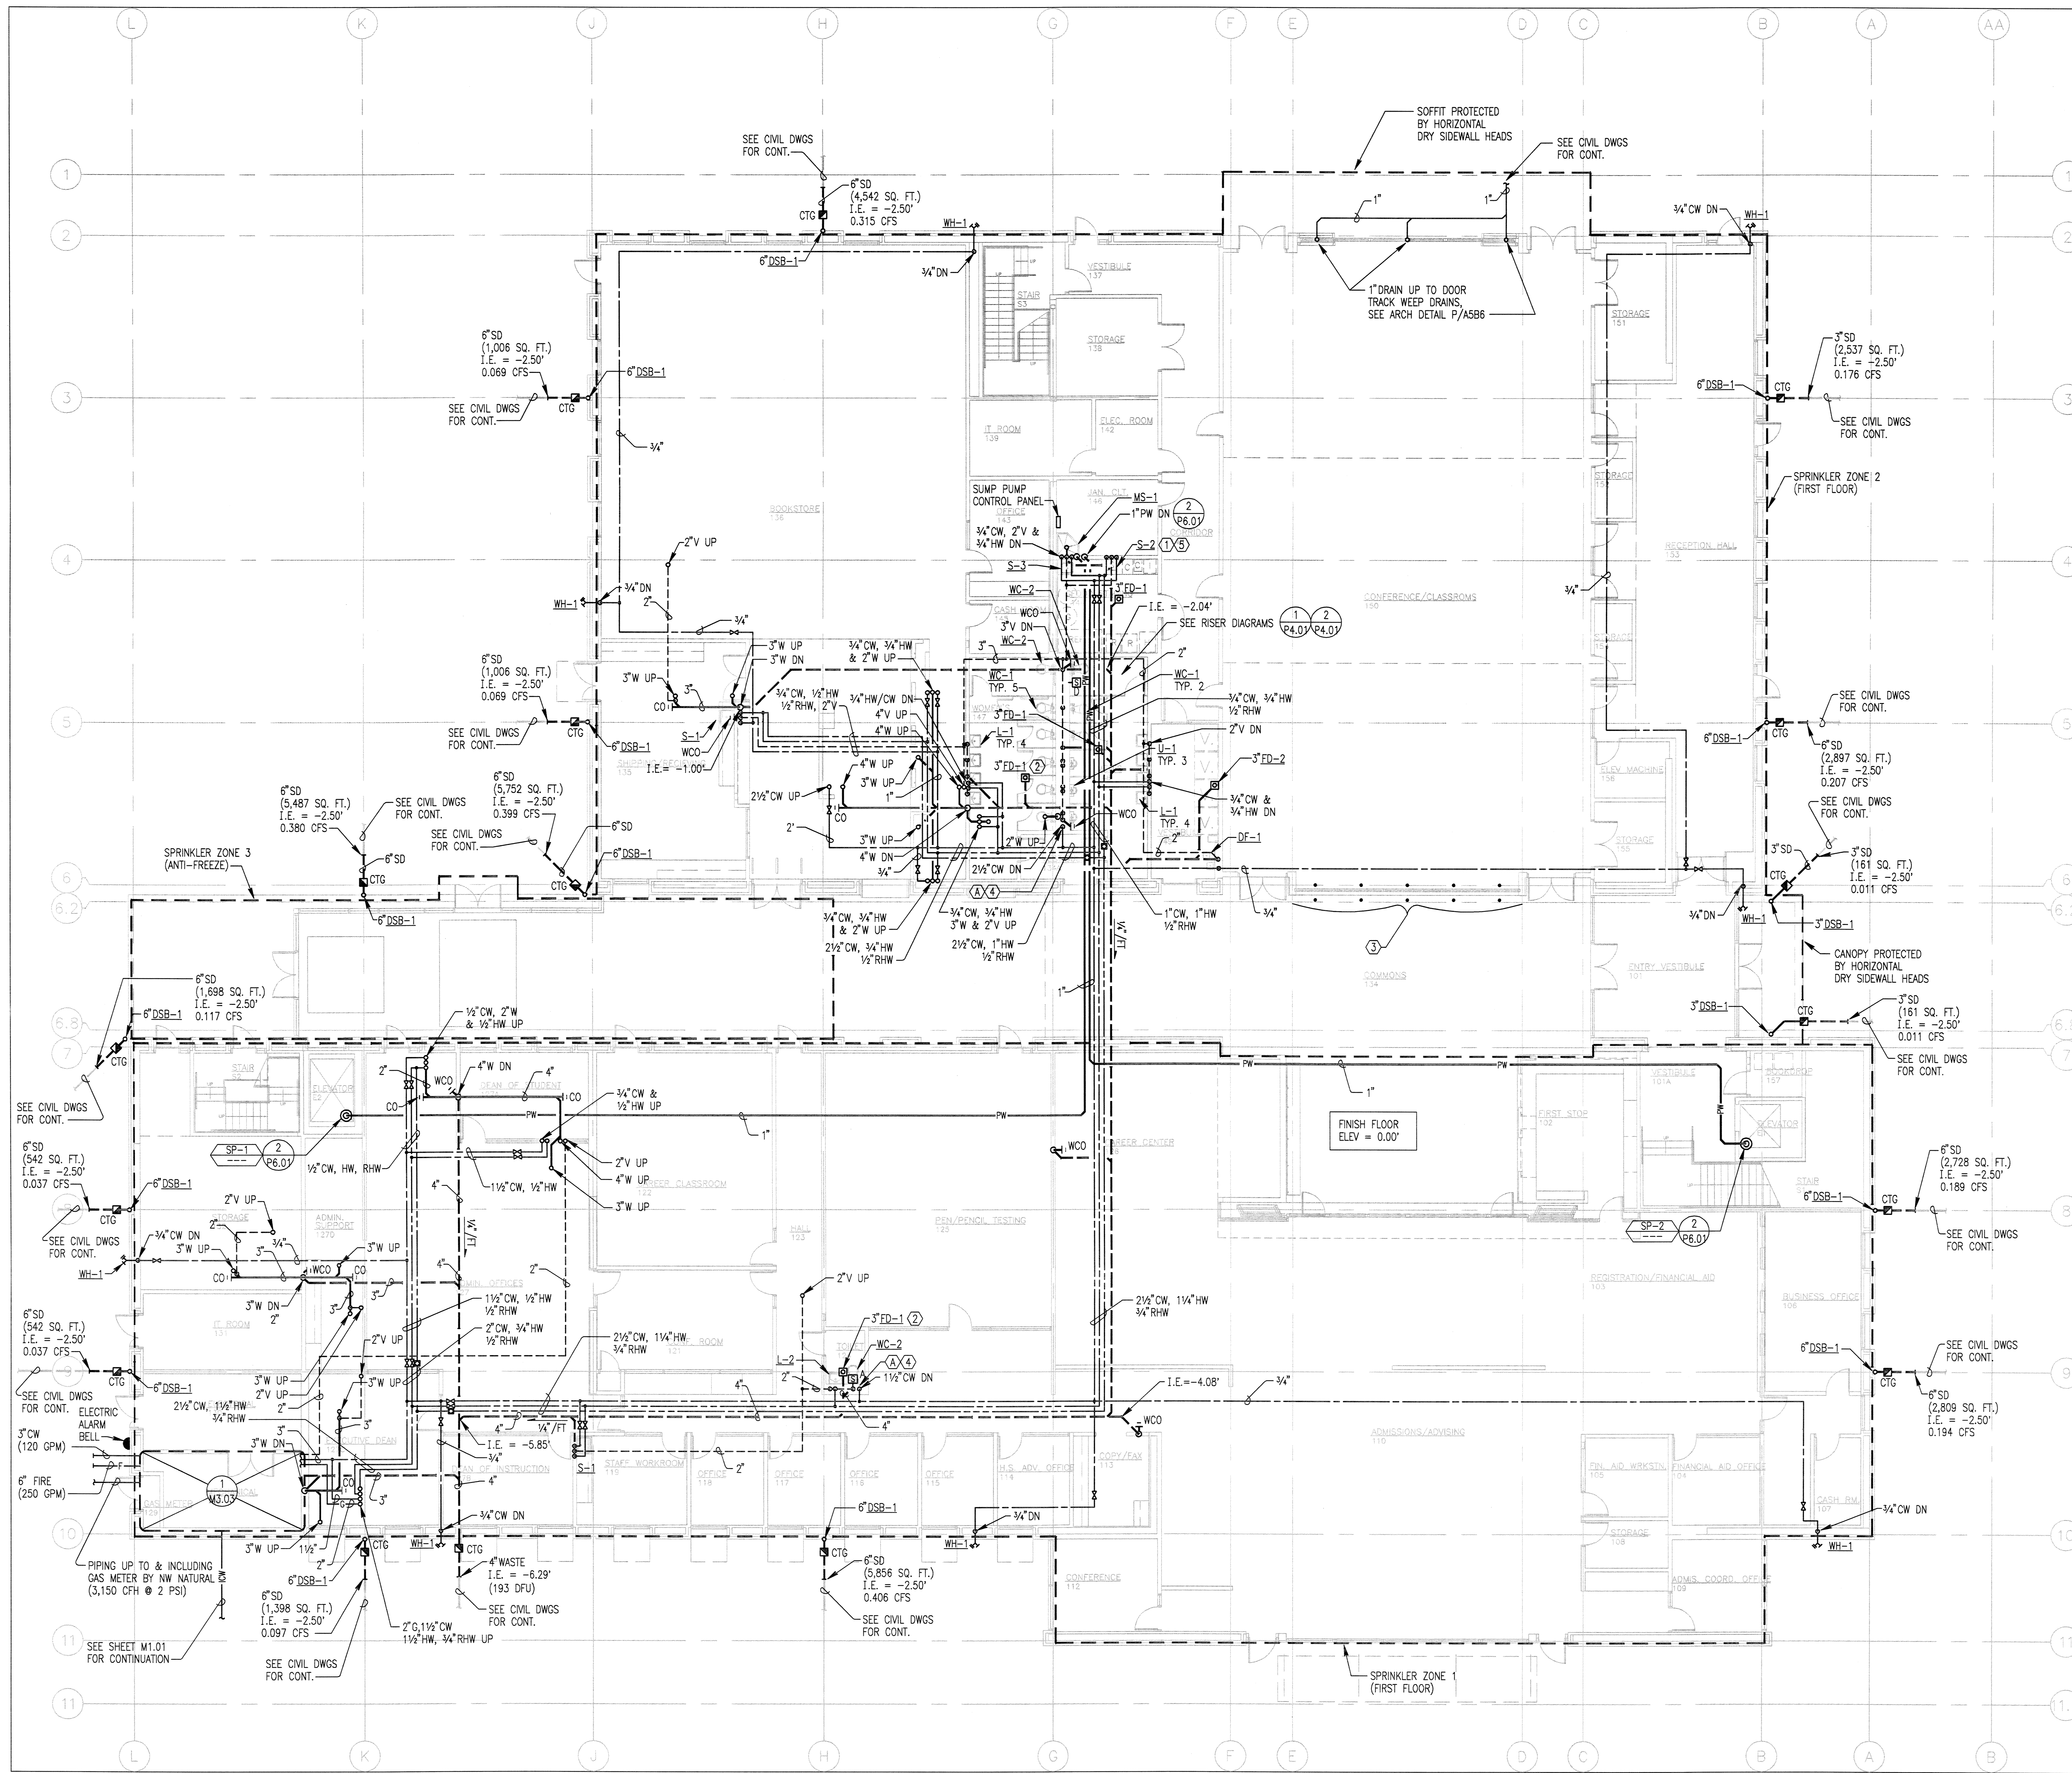


- GENERAL NOTES:**
1. INVERT ELEV. BASED ON FLOOR ELEVATION OF 0.00'. FOR ACTUAL INVERT ELEV. SEE CIVIL DRAWINGS.
- NOTES:**
1. PROVIDE HW & WASTE CONNECTION FOR DISHWASHER.
 2. COORDINATE EXACT LOCATION OF FLOOR DRAIN WITH ARCHITECT.
 3. PROVIDE "LIFE SAFETY TYPE" SPRINKLER HEADS FOR BOTH SIDES OF THIS SURFACE. REFERENCE SPECIFICATION SECTION 15300. SEE DETAIL V/AB81.
 4. PROVIDE SHUT OFF VALVES BEHIND ACCESS PANEL. SEE ARCH. DWGS FOR ACCESS PANEL LOCATION.
 5. PROVIDE 1/4" CW CONNECTION FOR COFFEE MAKERS (2).

FIRST FLOOR PLAN PLUMBING
PCC ROCK CREEK CAMPUS NEW BUILDING
PORTLAND COMMUNITY COLLEGE
ROCK CREEK CAMPUS
9705 NW Springdale Road
PORTLAND, OREGON 97229

THOMAS HACKER ARCHITECTS INC.
733 SW OAK STREET
PORTLAND, OREGON 97205
(503) 227-1254

PAE CONSULTING ENGINEERS
808 SW THIRD AVENUE
PORTLAND, OREGON 97204
(503) 226-2921

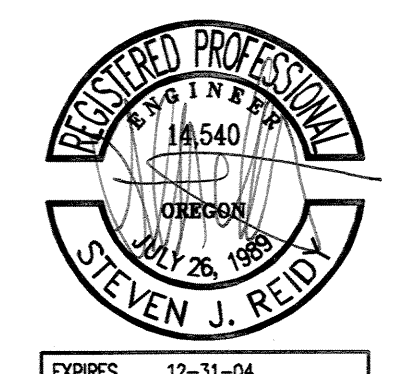


REVISIONS : 3/21/03


DATE : 02/14/03
SCALE : AS SHOWN

DRAWN BY : DWH
JOB NO. : 0115
DWG. NO. : P2.01

THOMAS HACKER ARCHITECTS INC.

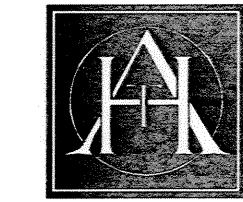

12:09 02/14/03 0080900 8087202.dwg x72809f2.57026534.57026531 c:\b09x\260901 1edlin [X:\38822f.pcx X:\38822f.ctb]

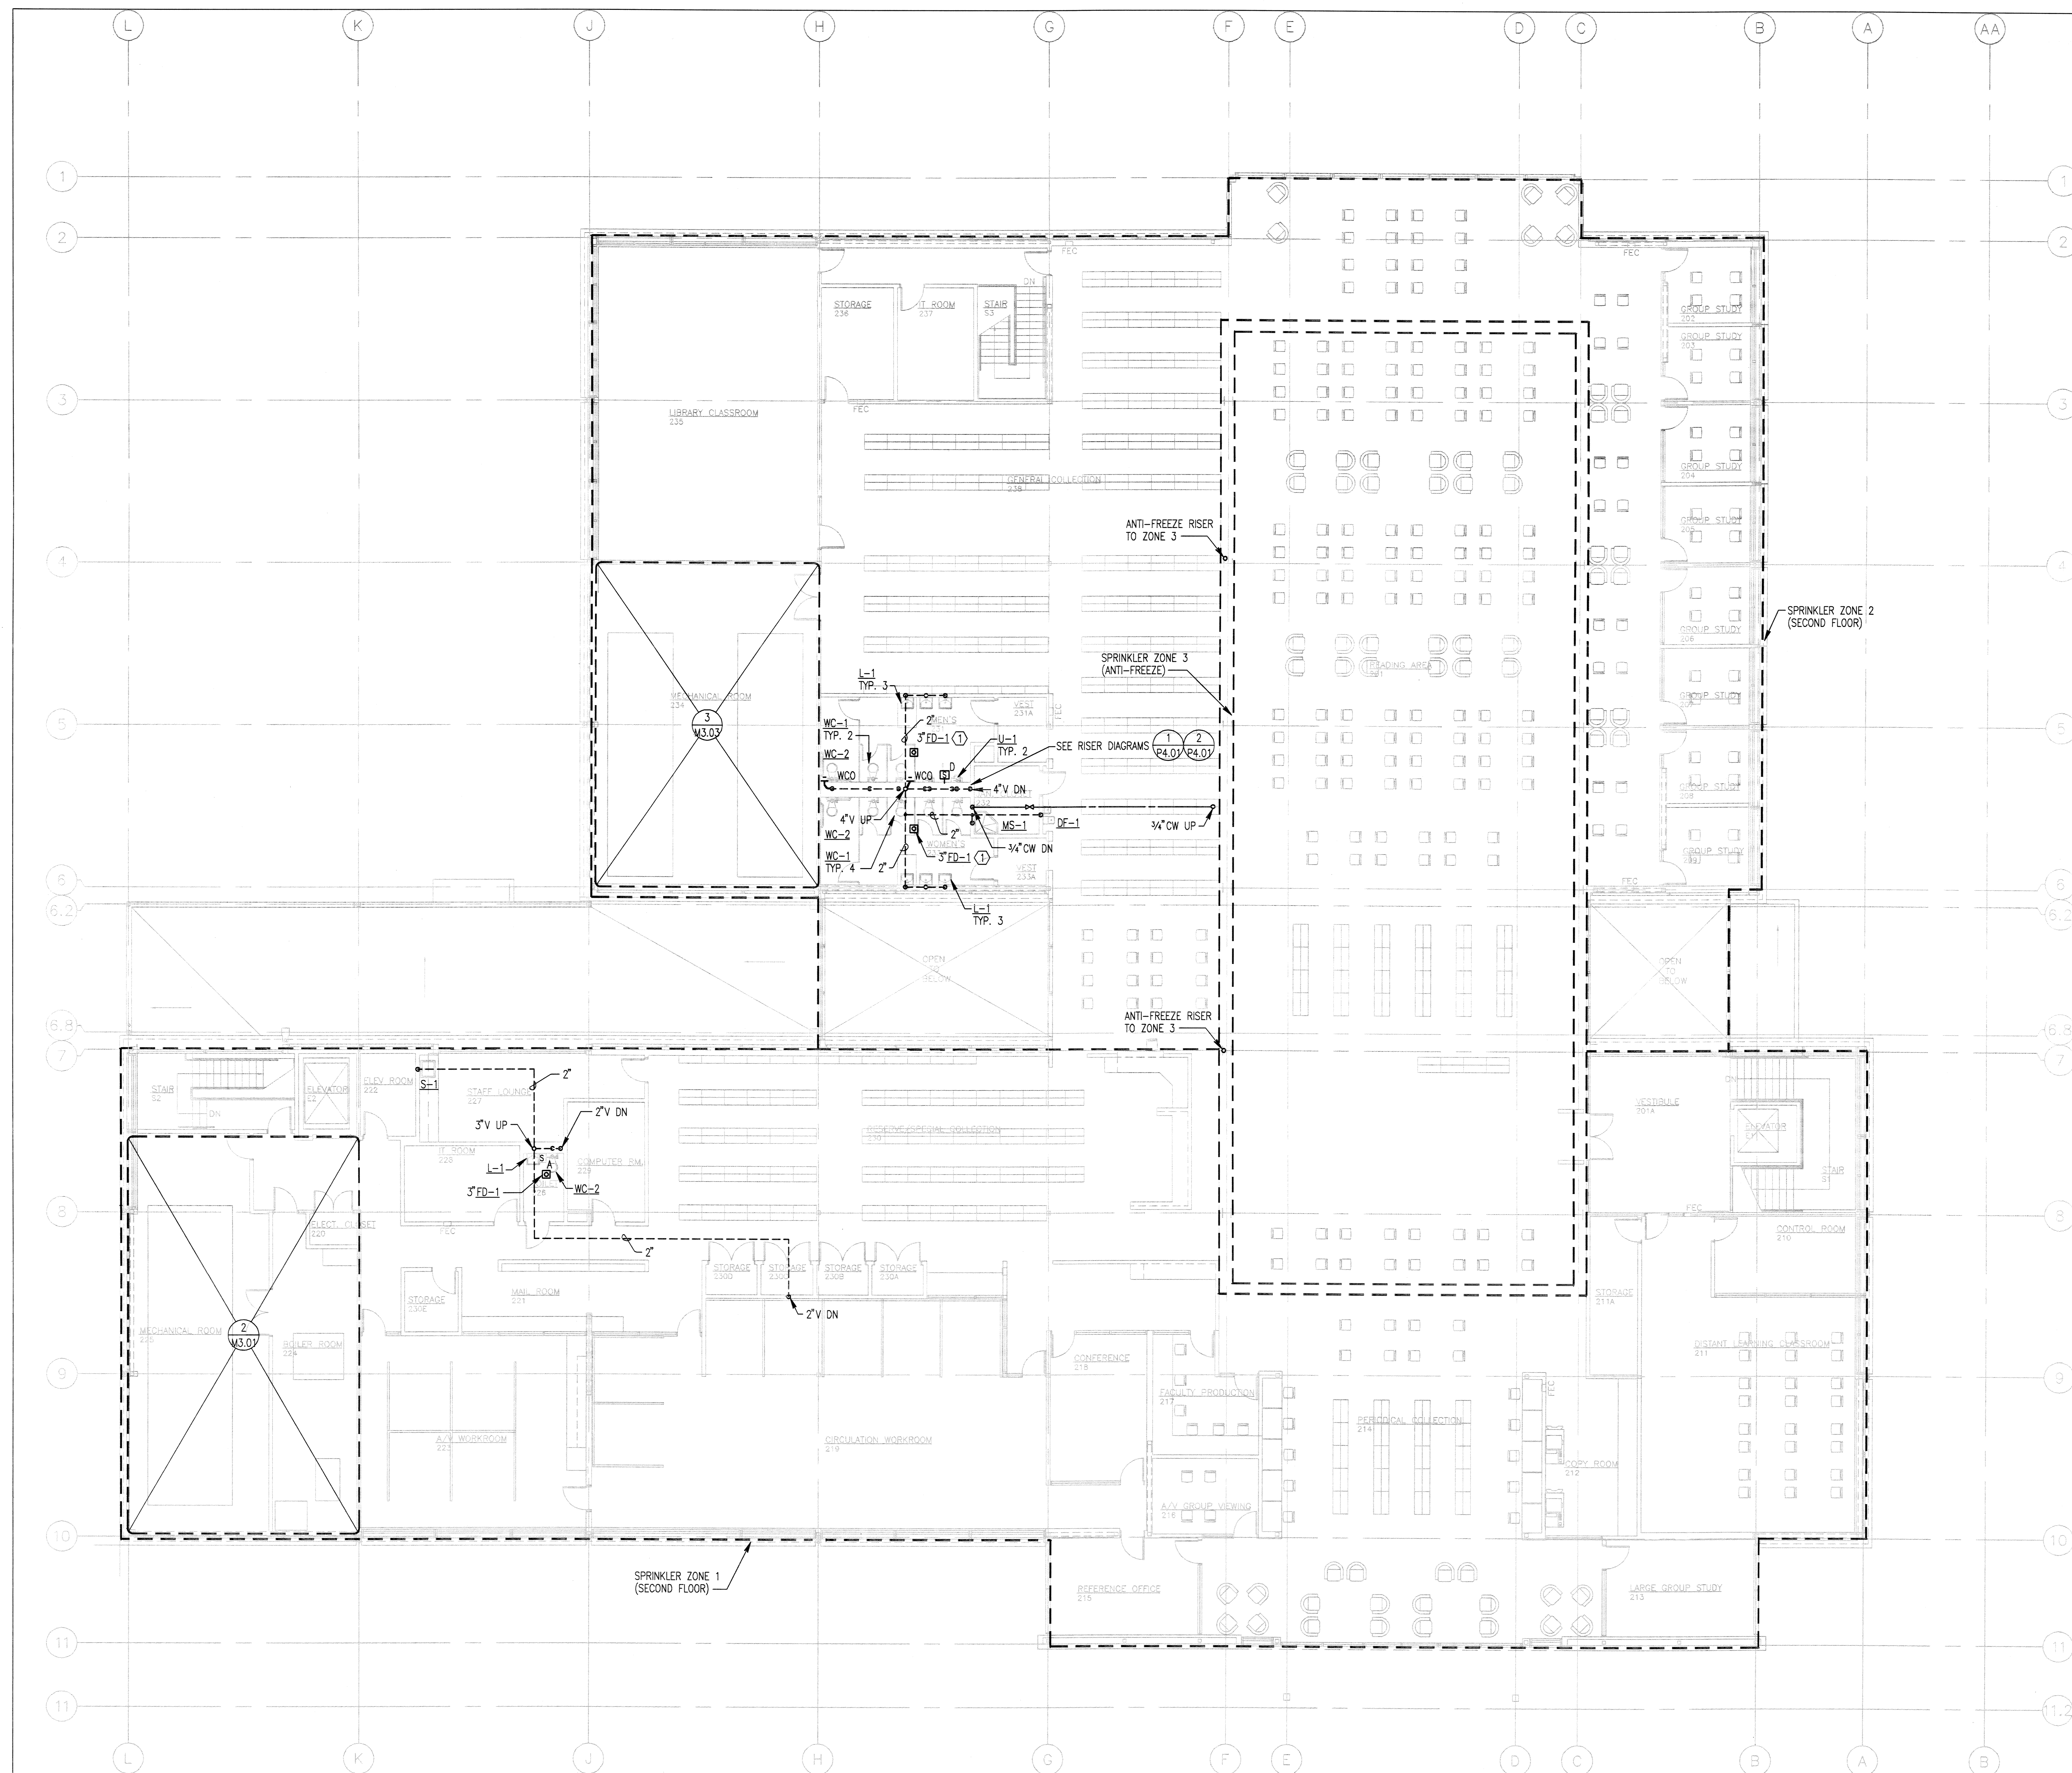


NOTES:
① COORDINATE EXACT LOCATION OF FLOOR DRAIN WITH ARCHITECT.


SECOND FLOOR PLAN
PLUMBING
PCC ROCK CREEK CAMPUS
NEW BUILDING
PORTLAND COMMUNITY COLLEGE
ROCK CREEK CAMPUS
1700 NW Springdale Road
PORTLAND, OREGON 97229
THOMAS HACKER ARCHITECTS INC
723 NW OAK STREET
PORTLAND, OREGON 97205
(503) 227-1254
PAE CONSULTING ENGINEERS
606 NW THIRD AVENUE
PORTLAND, OREGON 97204
(503) 226-2921



REVISIONS :
DATE : 02/14/03
SCALE : NONE
DRAWN BY : EMW
JOB NO. : 0115
DWG. NO. : P2.02


THOMAS HACKER
ARCHITECTS INC.

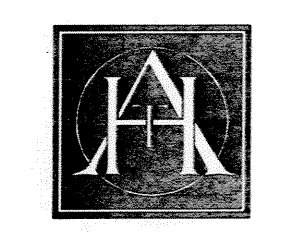

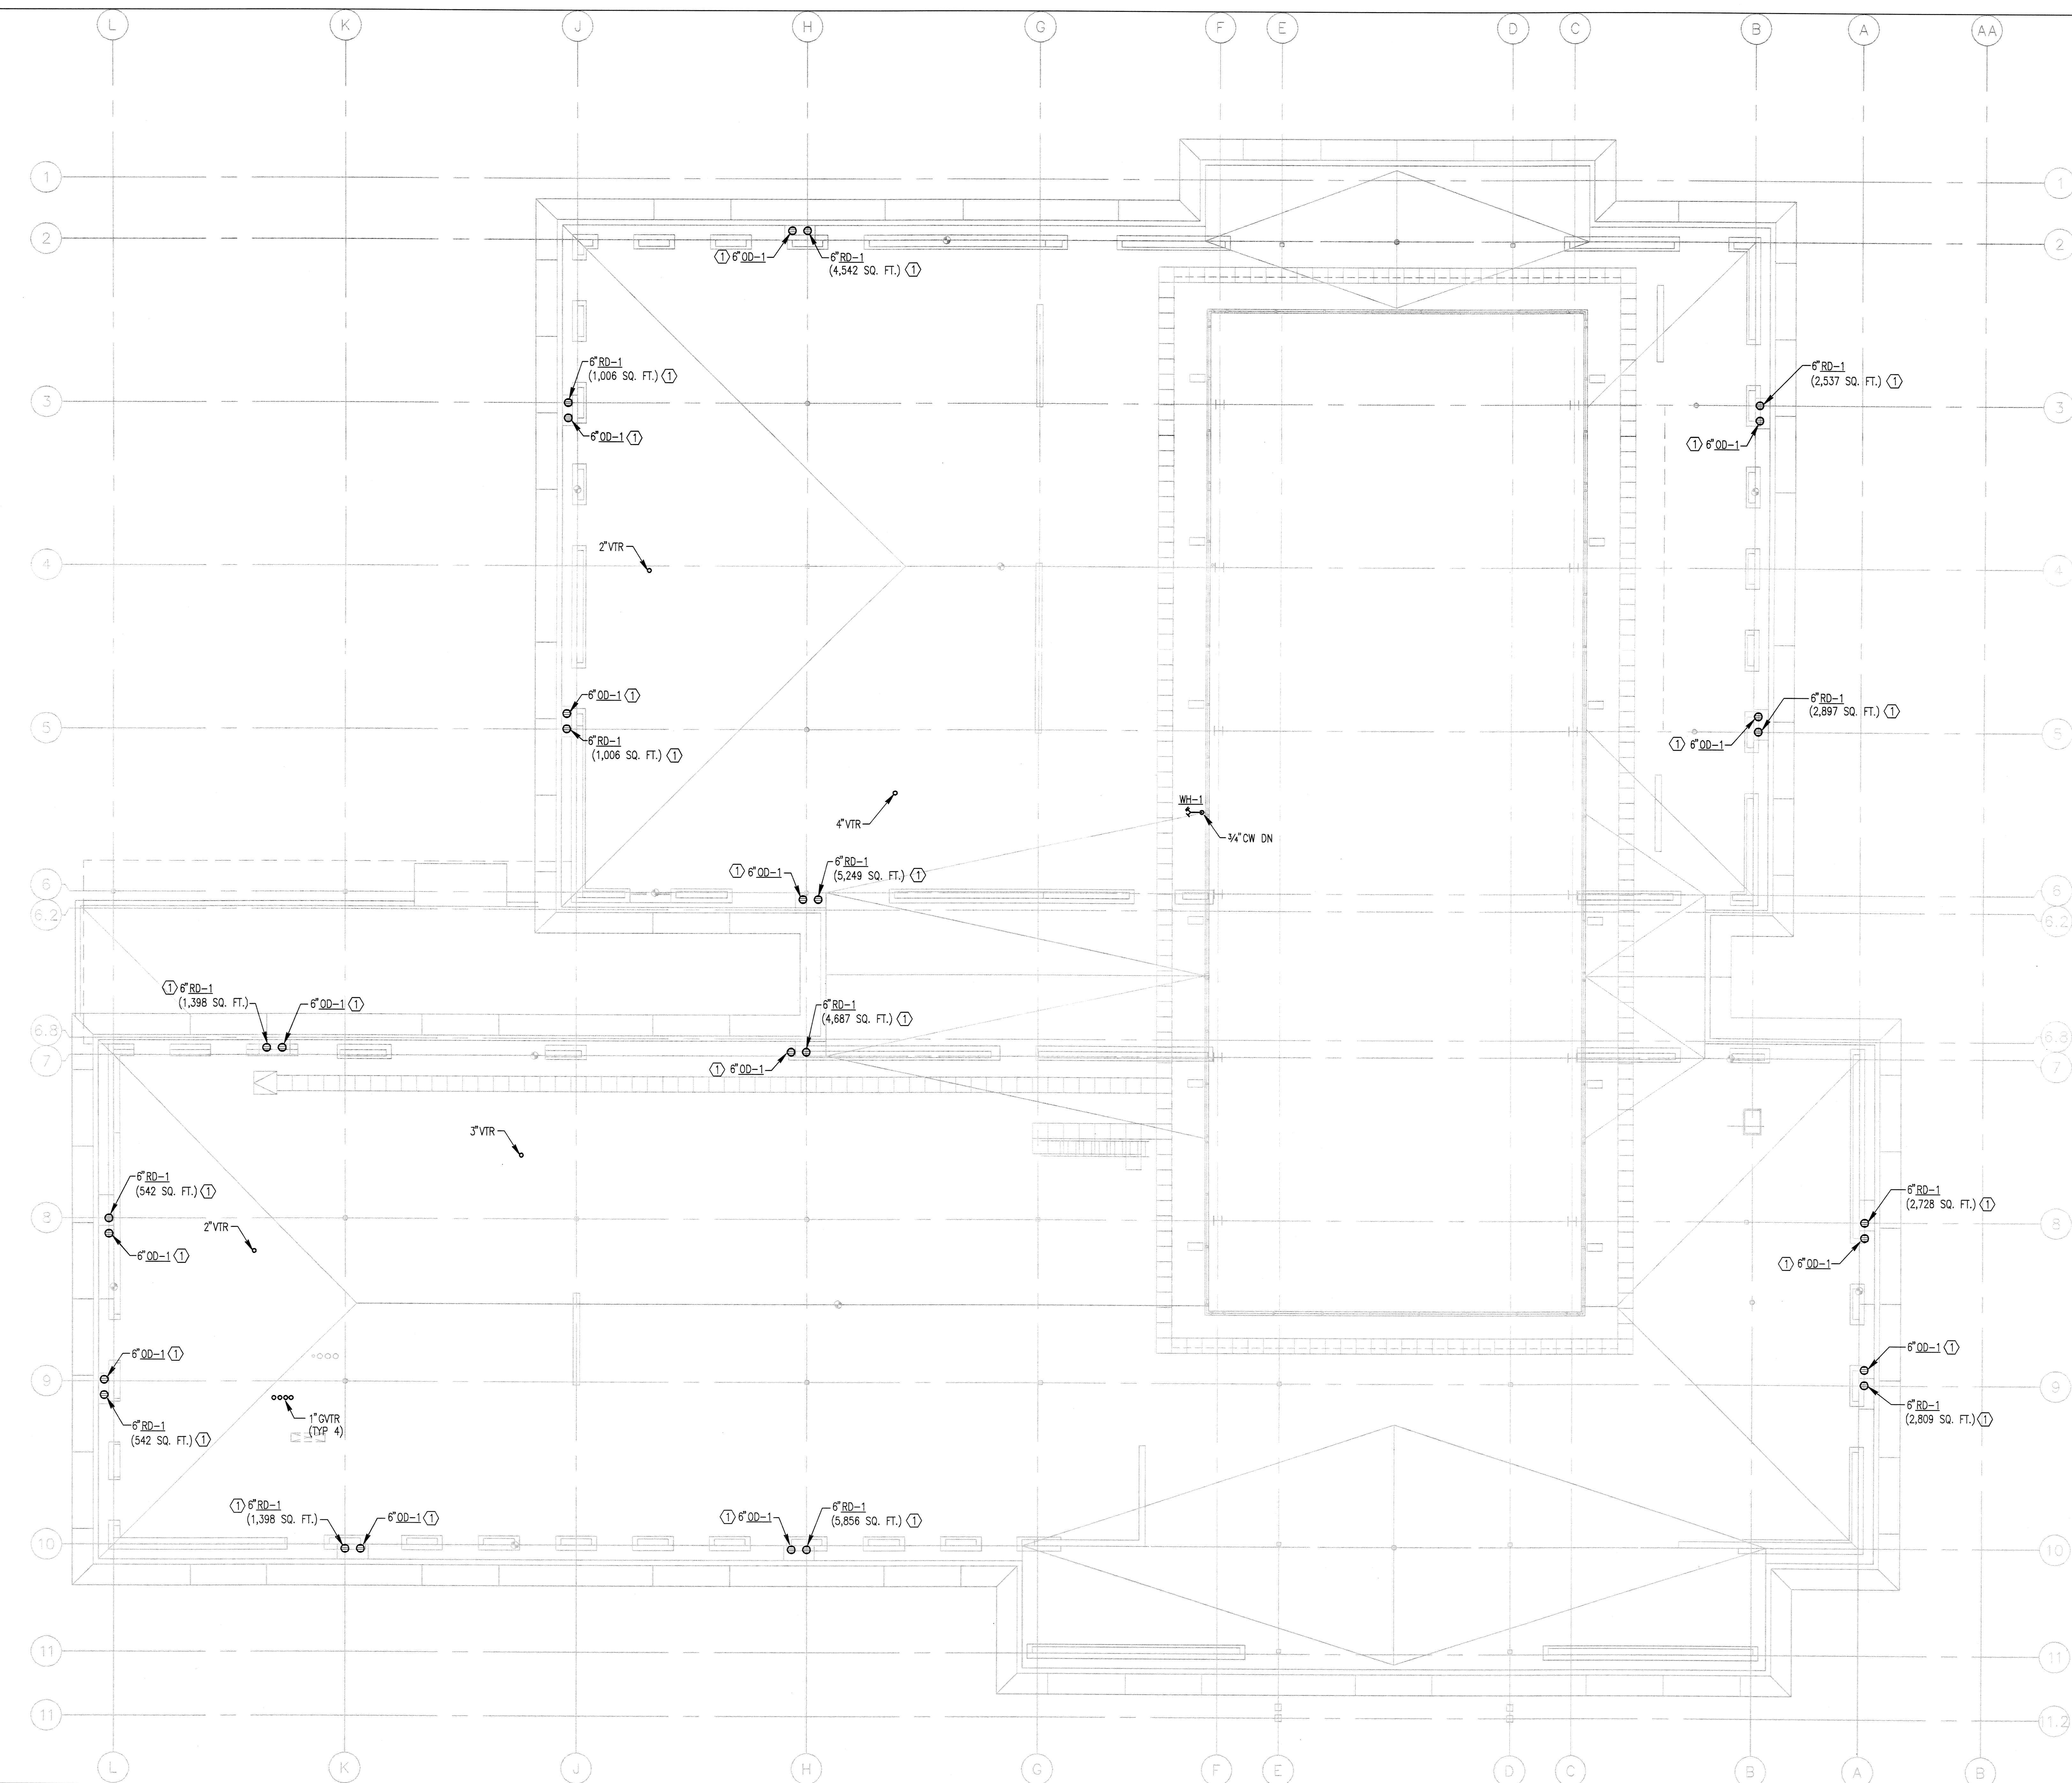


NOTES:
① CONNECT TO DOWNSPOUT PROVIDED BY OTHERS.
REFERENCE ARCH. DRAWINGS.

**ROOF PLAN
PLUMBING**
**PCC ROCK CREEK CAMPUS
NEW BUILDING**
PORTLAND COMMUNITY COLLEGE
ROCK CREEK CAMPUS
3700 NW Springville Road
PORTLAND, OREGON 97229
THOMAS HACKER ARCHITECTS INC.
733 SW OAK STREET
PORTLAND, OREGON 97205
(503) 227-1254
PAE CONSULTING ENGINEERS
508 SW THIRD AVENUE
PORTLAND, OREGON 97204
(503) 226-2951




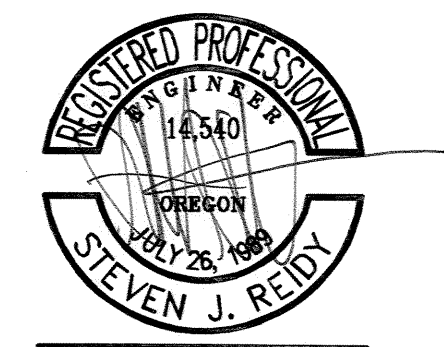


REVISIONS :	EXPRES	12-31-04
DATE :	02/14/03	RRK
SCALE :	NONE	JOB NO. : 0115

**THOMAS HACKER
ARCHITECTS INC.**

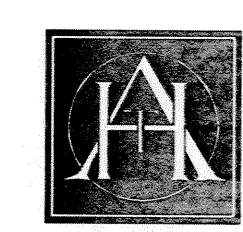

P2.03

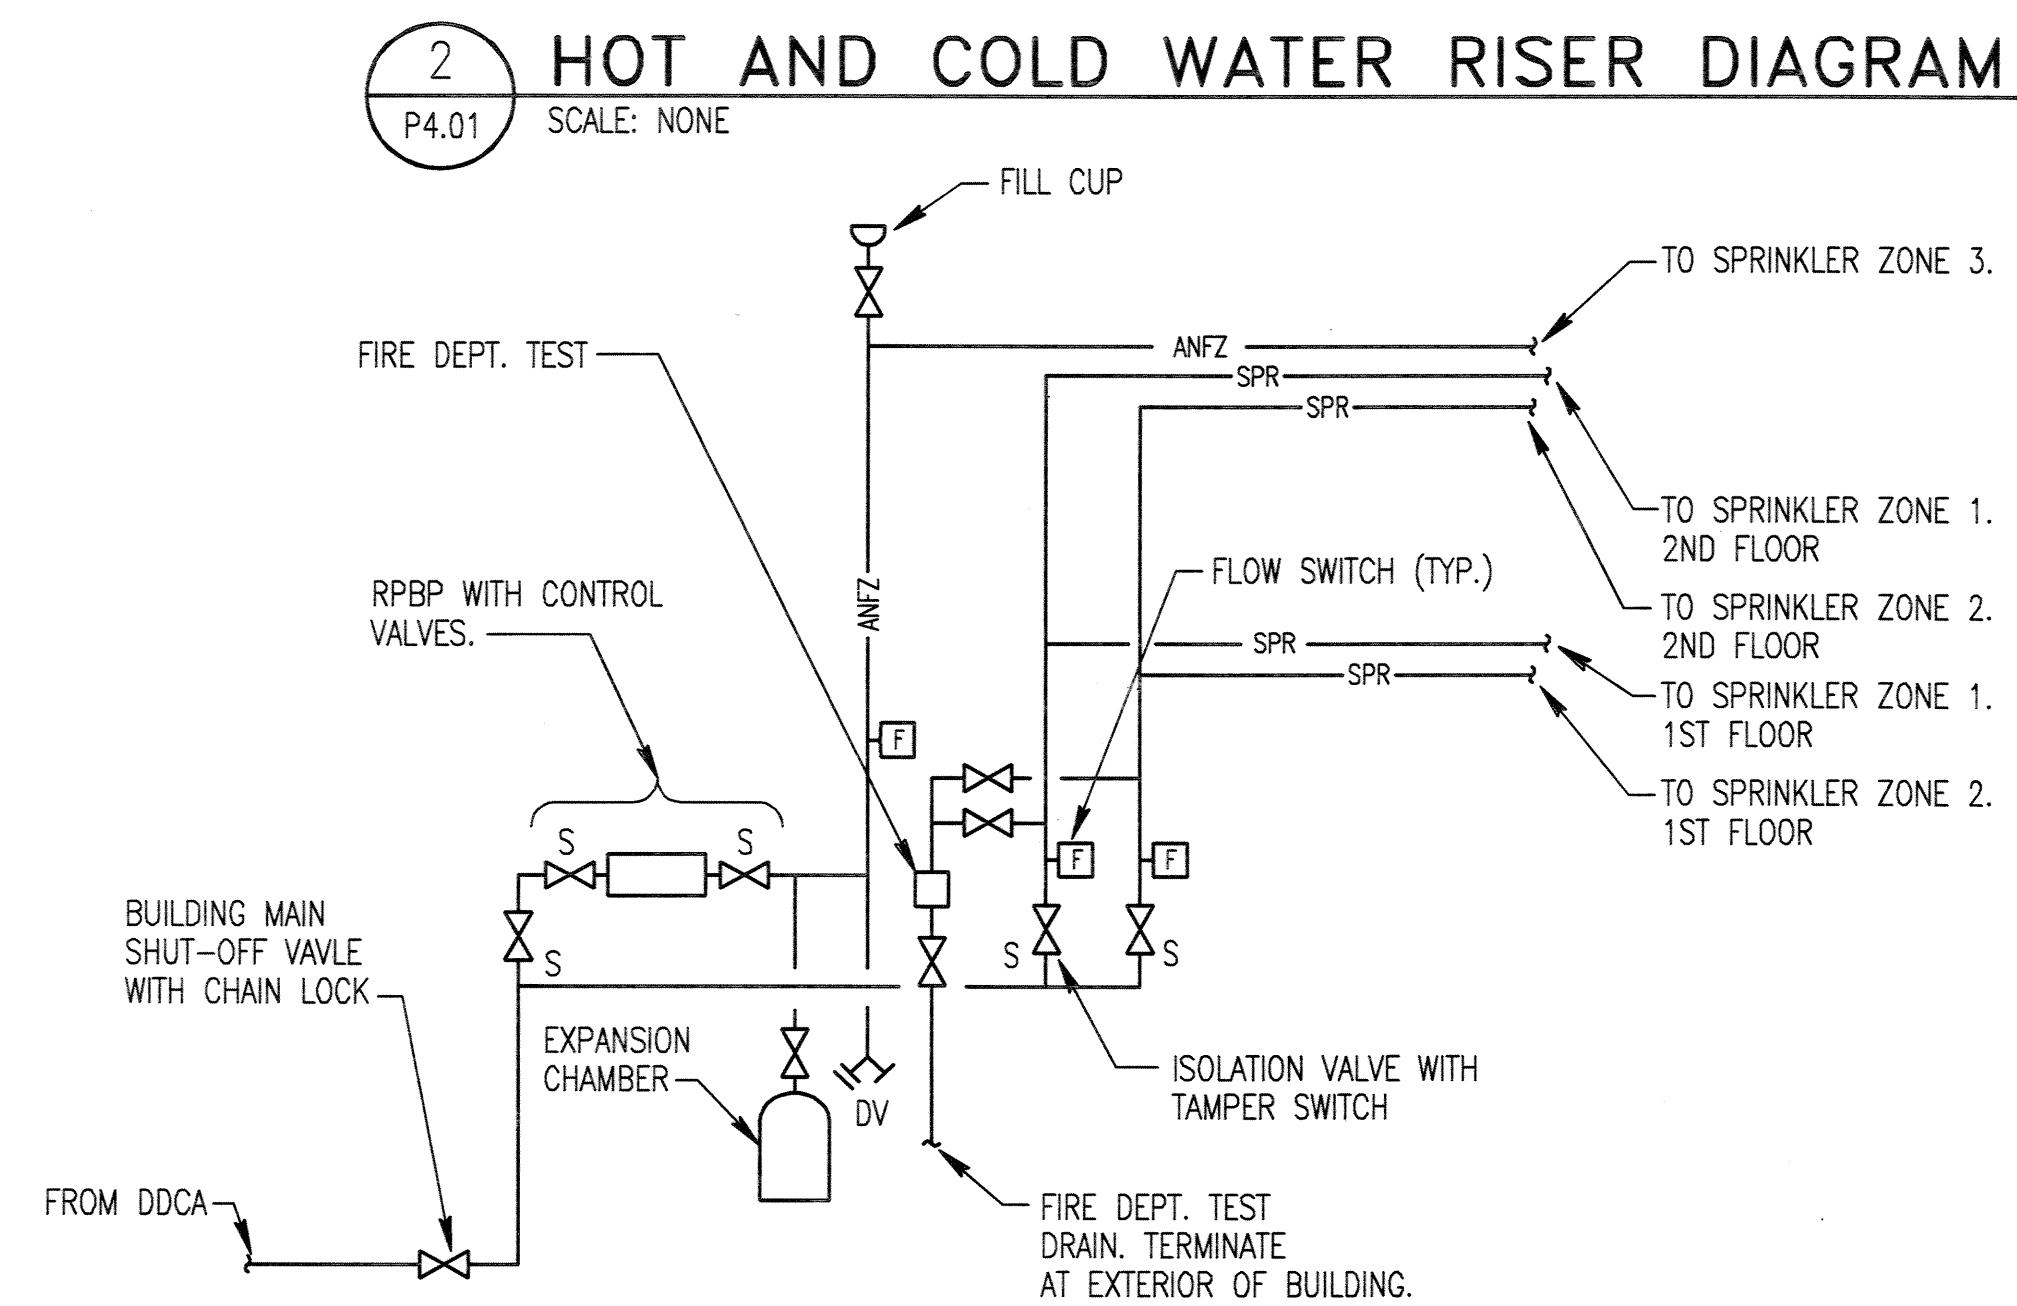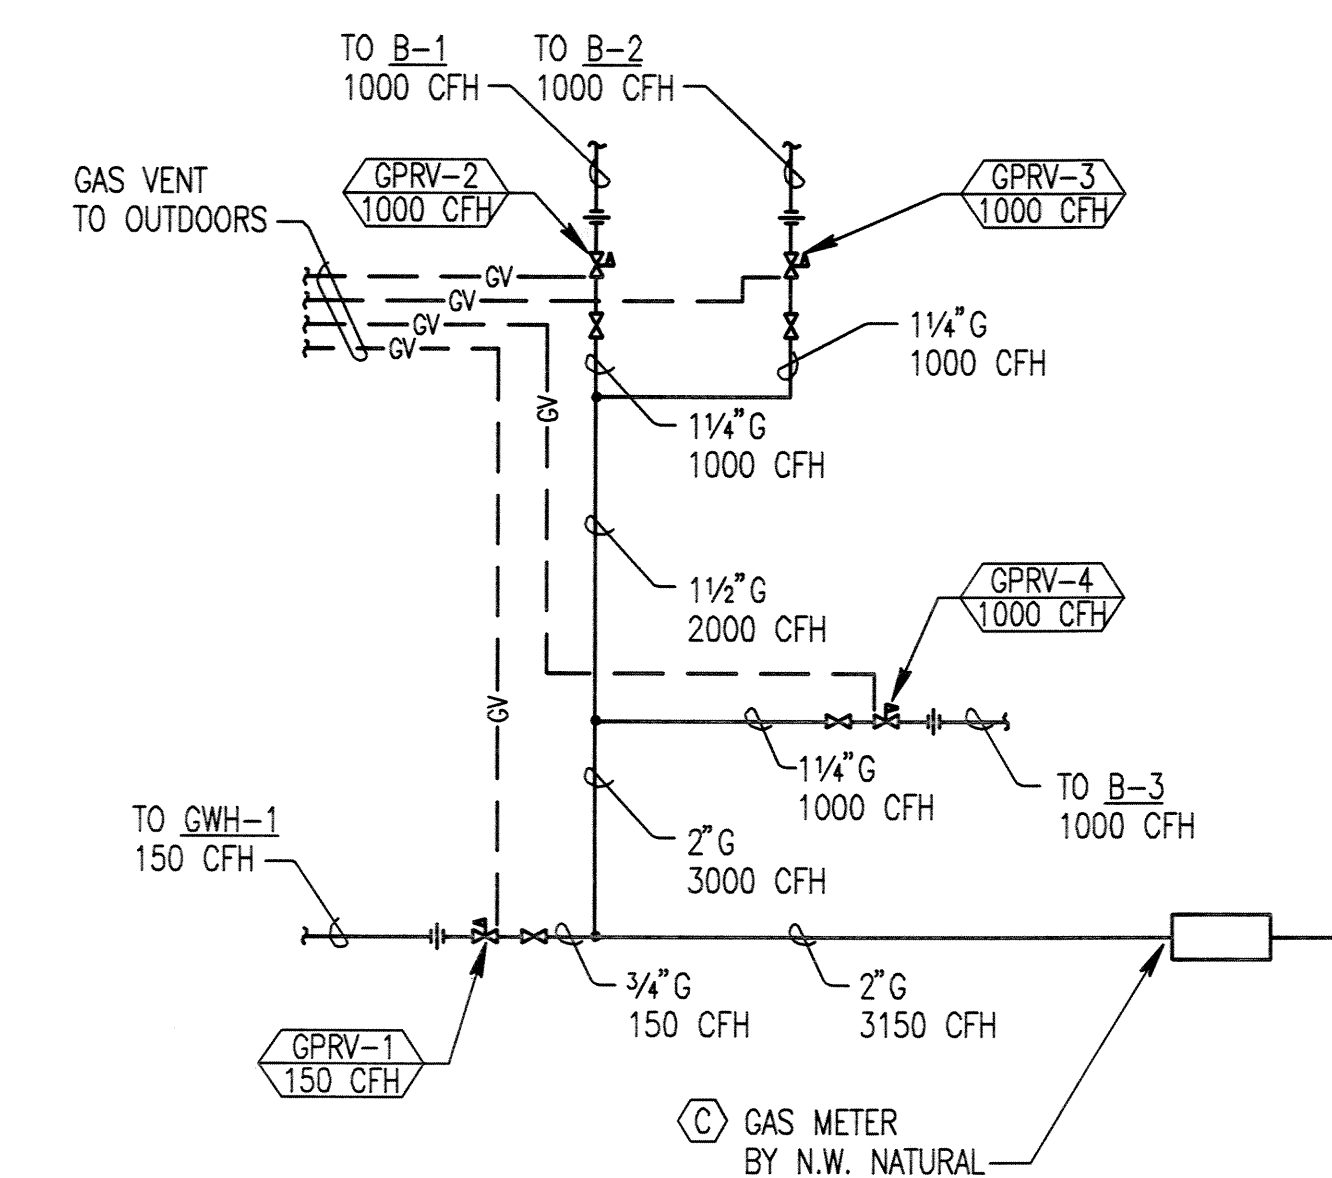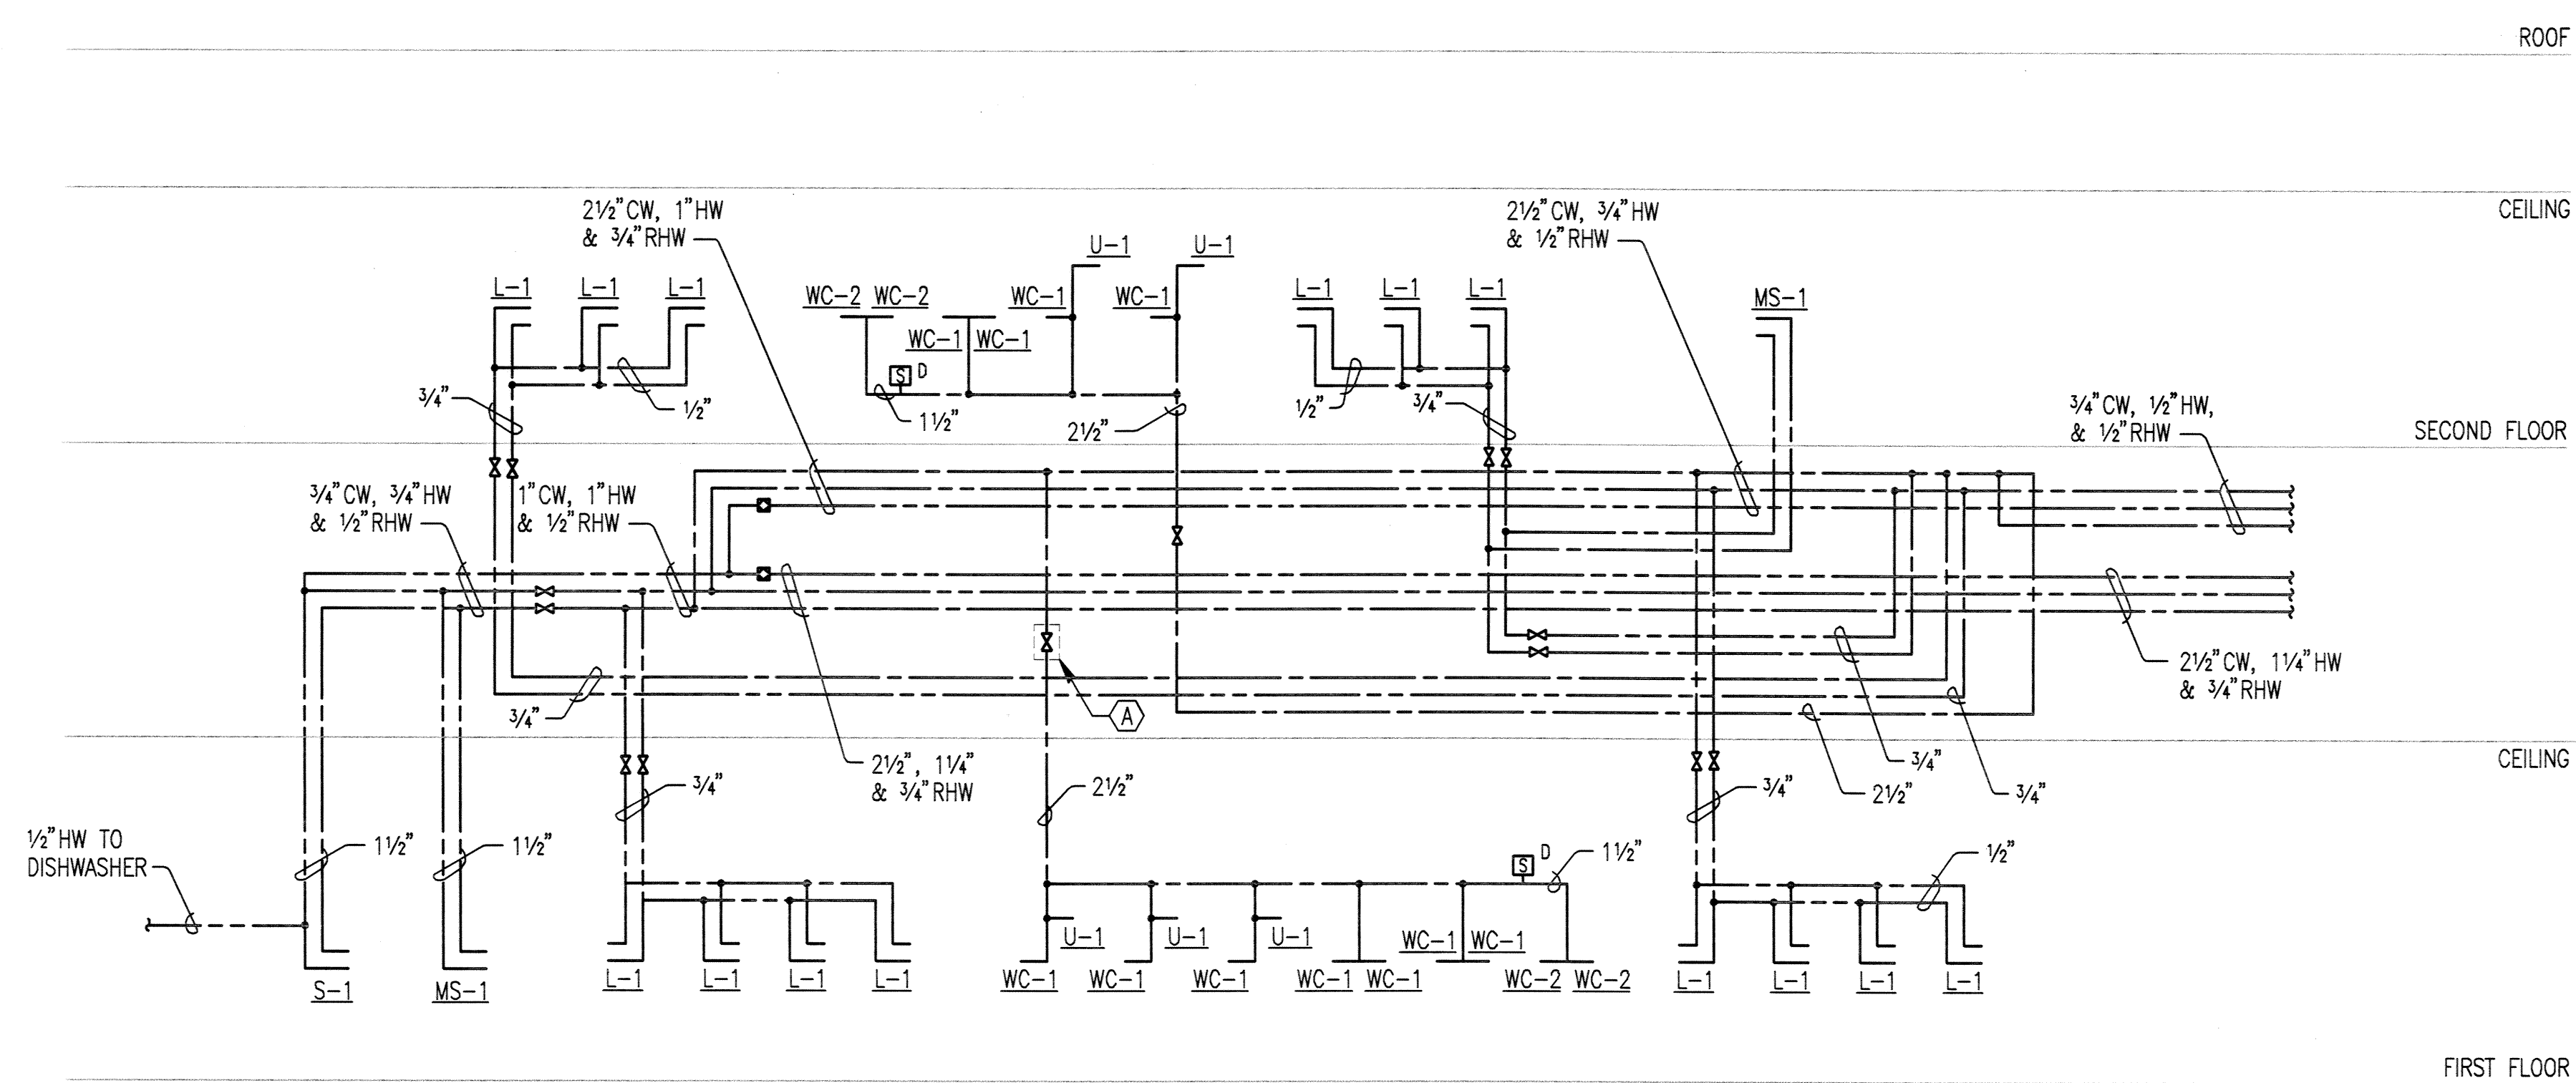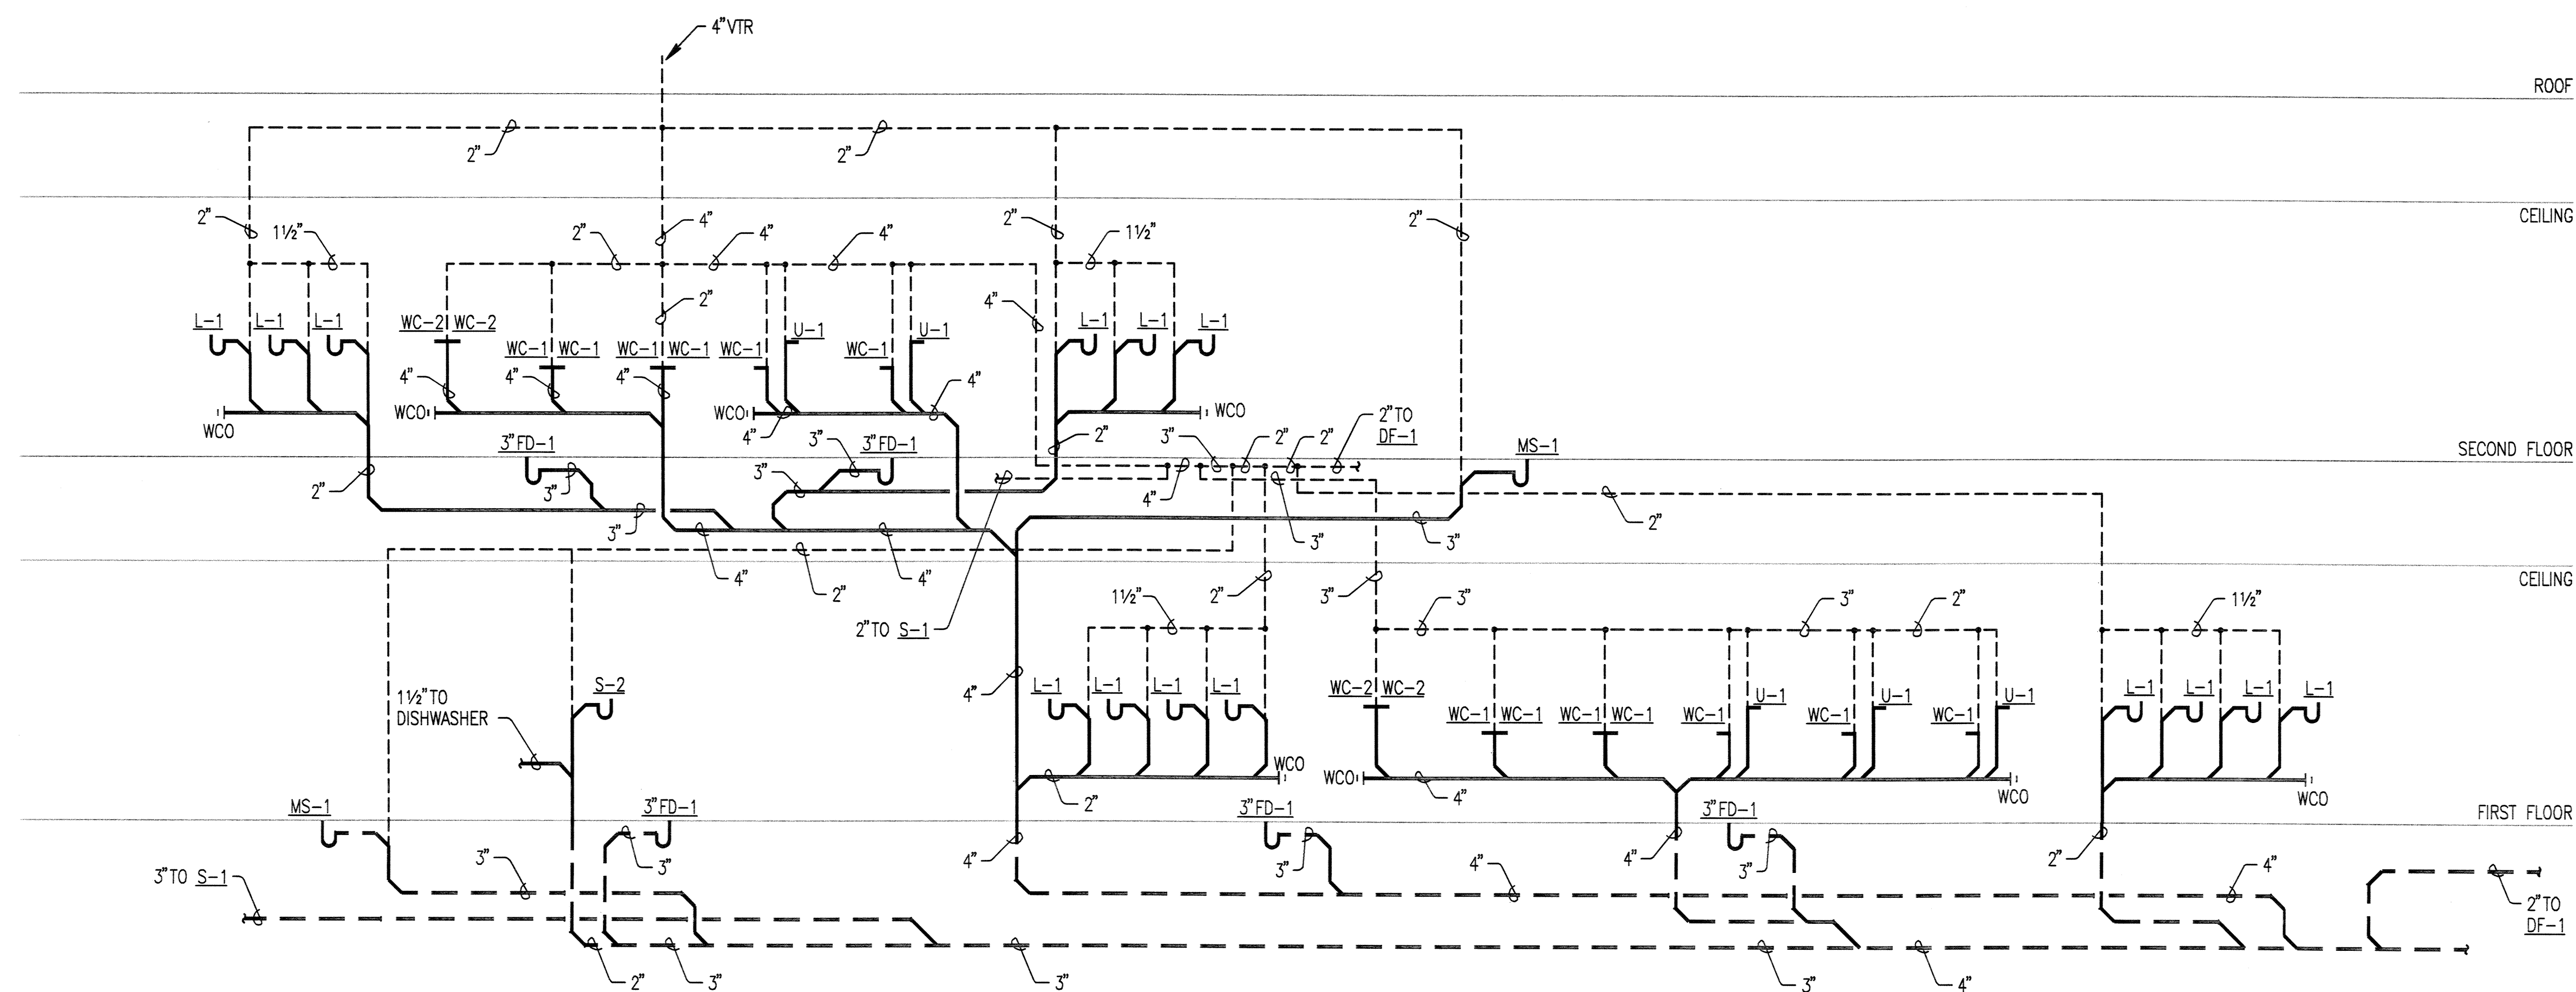

RISER DIAGRAMS – PLUMBING

PCC ROCK CREEK CAMPUS
NEW BUILDING

PORTLAND COMMUNITY COLLEGE
ROCK CREEK CAMPUS
17705 NW Springfield Road
PORTLAND, OREGON 97229

THOMAS HACKER ARCHITECTS INC
733 SW OAK STREET
PORTLAND, OREGON 97205
(503) 227-1254

PAE CONSULTING ENGINEERS
808 SW THIRD AVENUE
PORTLAND, OREGON 97204
(503) 226-2921

REVISIONS :

DATE : 02/14/03
SCALE : NONE

EXPIRES	12-31-04
---------	----------


DRAWN BY : RRK
JOB NO. : 0115

DWG. NO.


P4.01

THOMAS HACKER
ARCHITECTS INC.



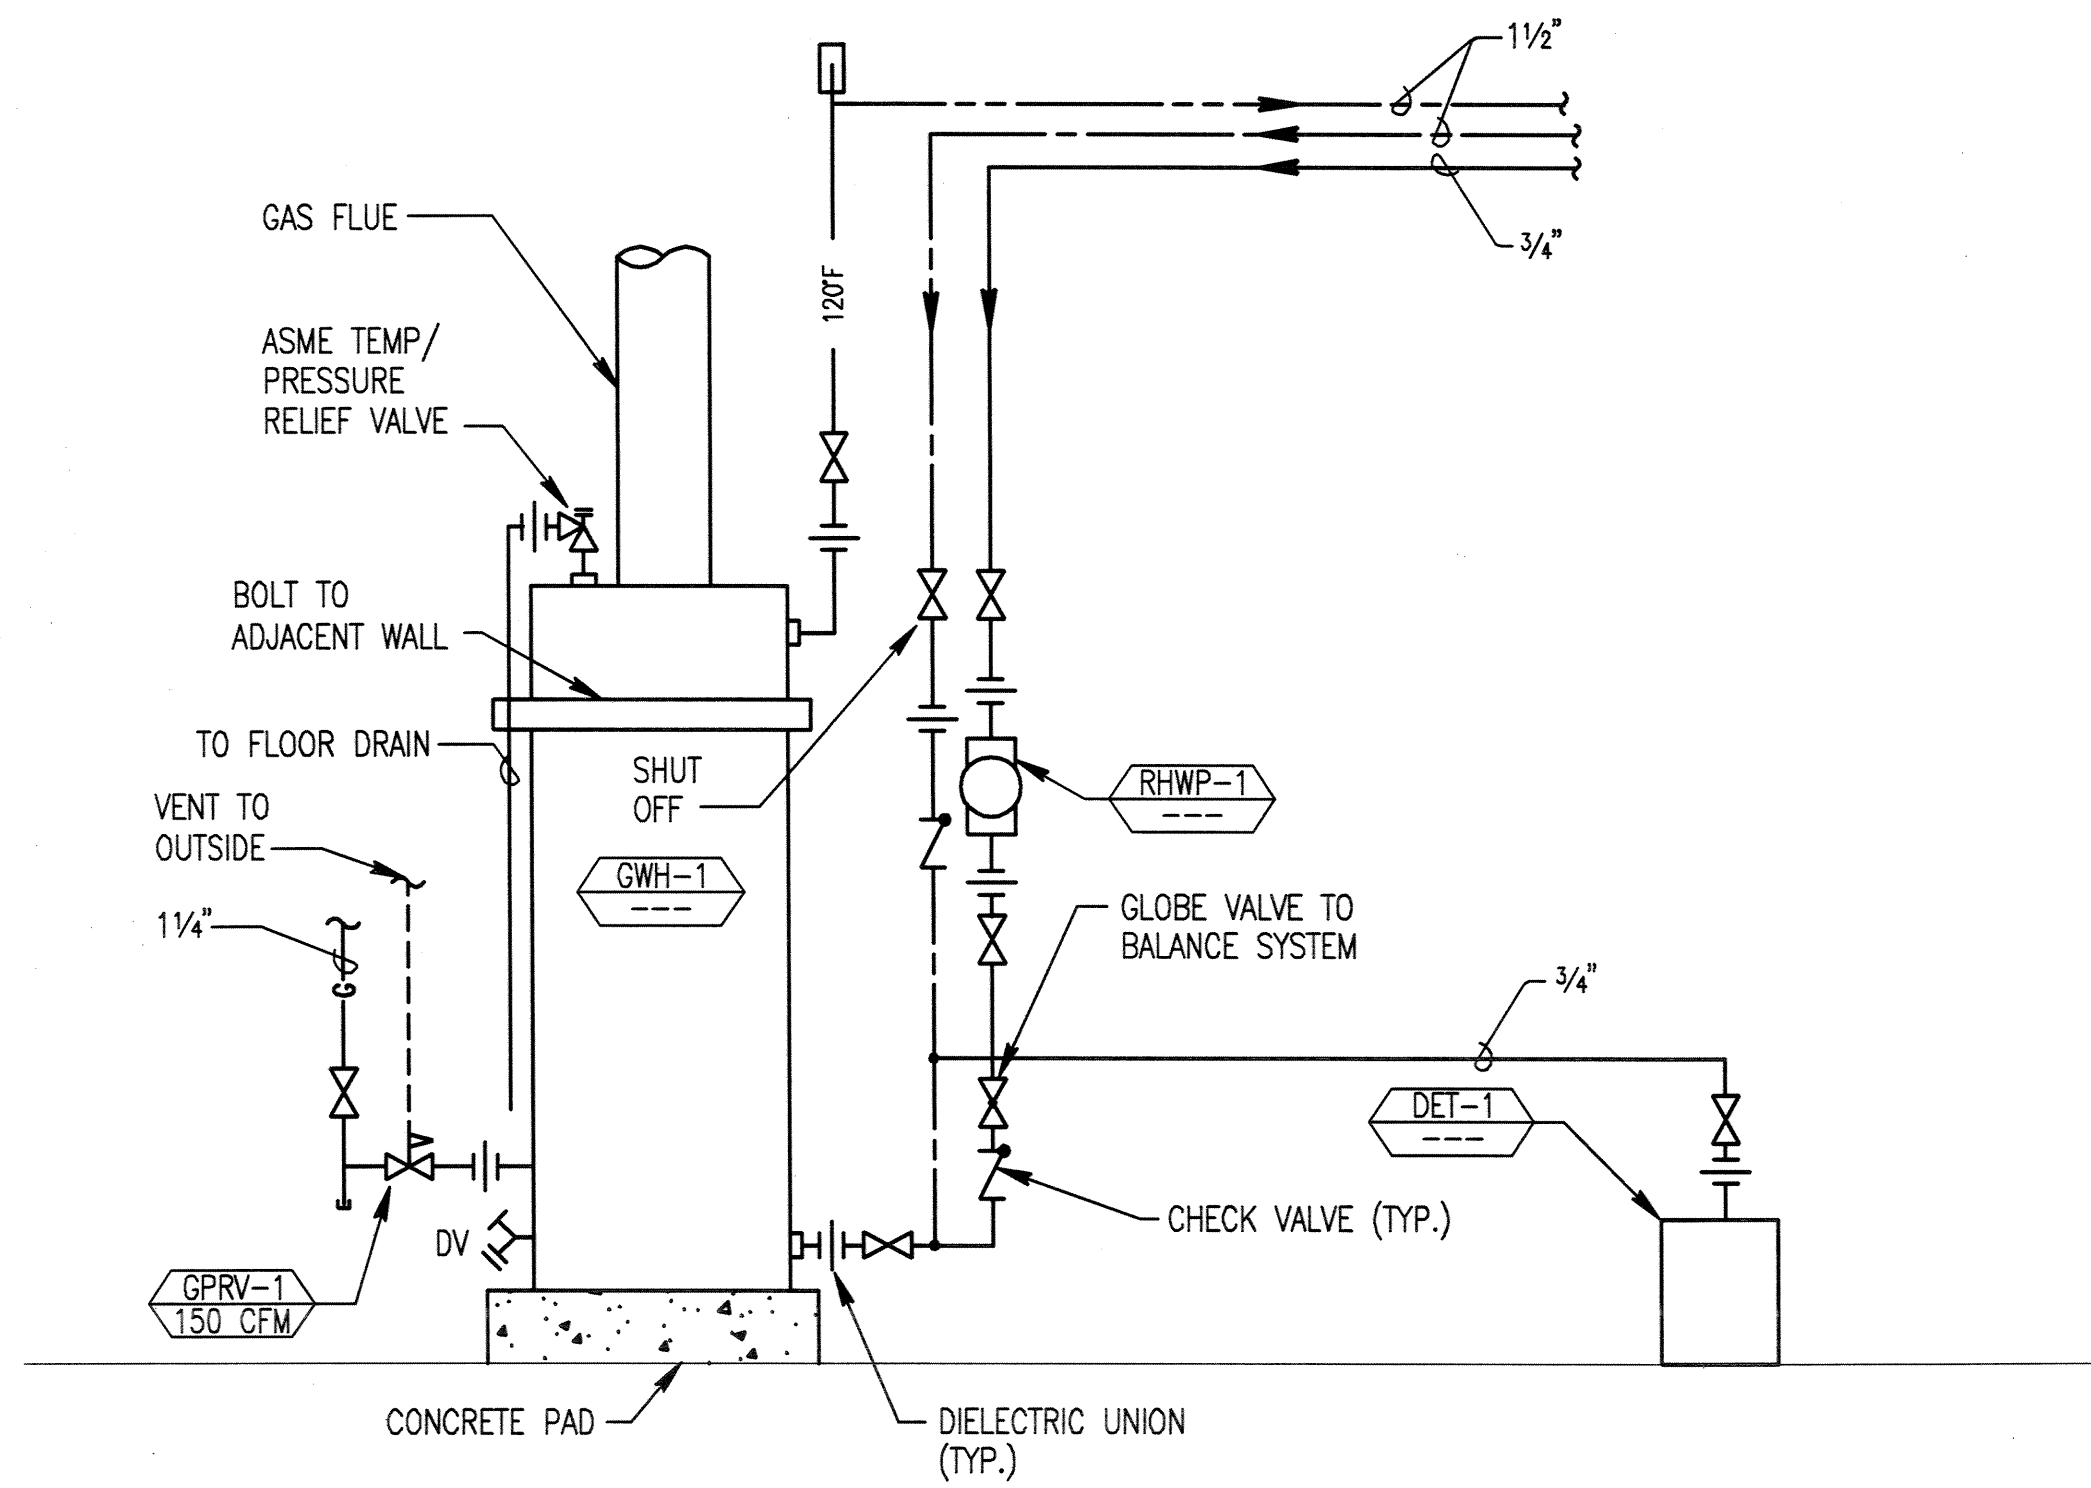

1 GAS WATER HEATER DETAIL
P6.01 SCALE: NONE

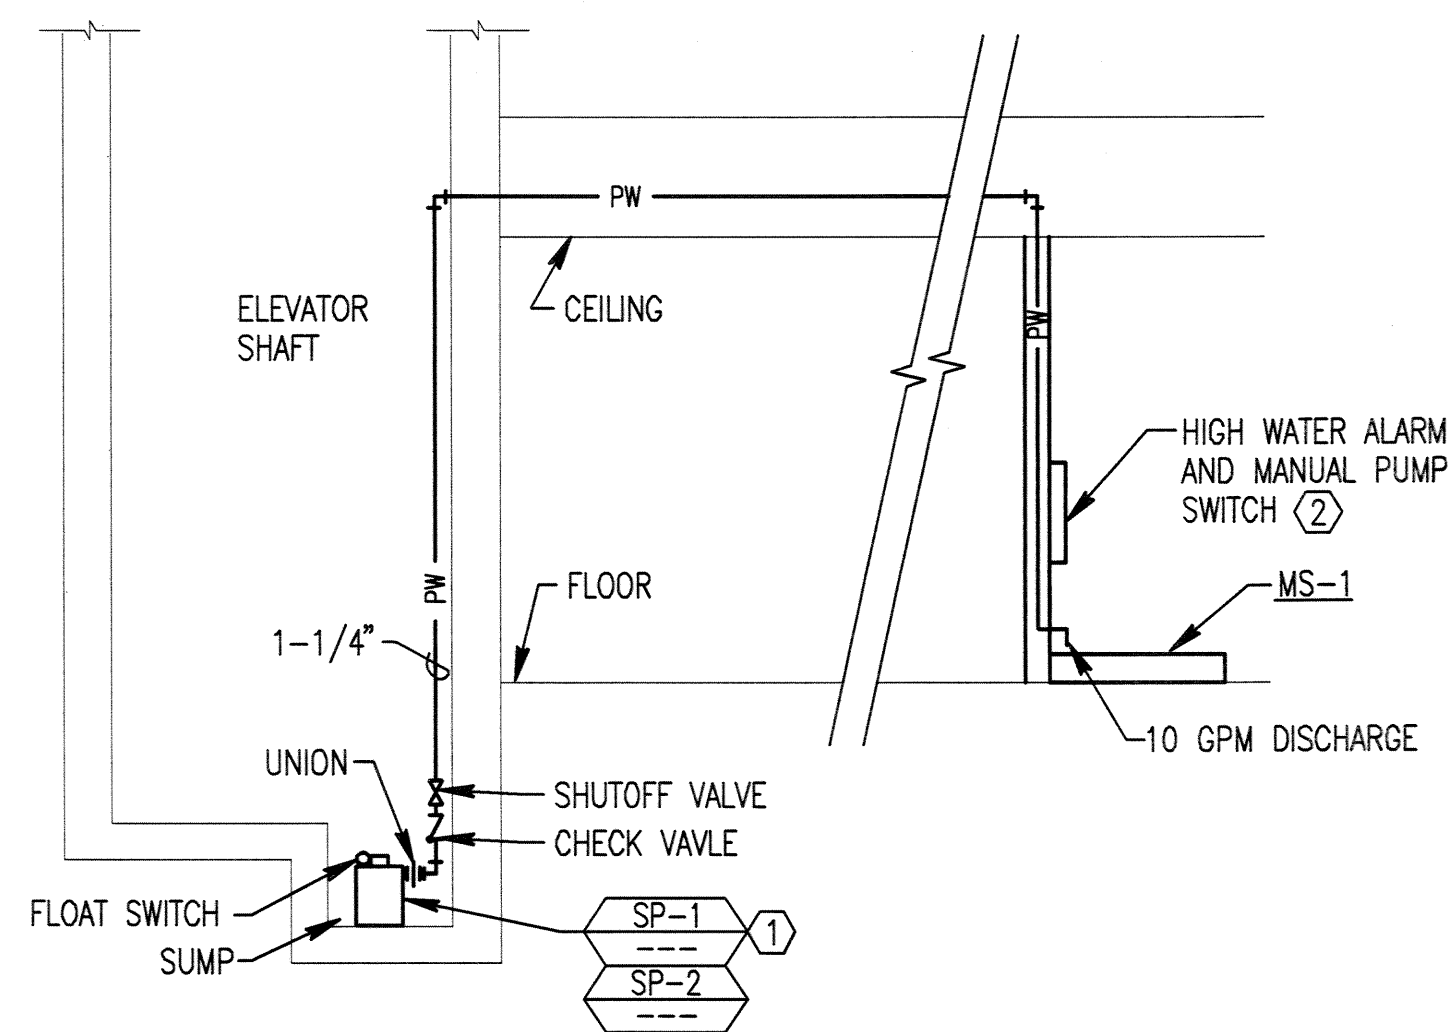

- NOTES:**
- ① PROVIDE LOCAL DISCONNECT FOR PUMP WITHIN ELEVATOR SHAFT. SEE DIV.16 FOR REQUIREMENTS.
 - ② LOCATE CONTROLLER FOR SUMP PUMPS IN JANITOR'S ROOM AS INDICATED ON DRAWINGS.

2 SUMP PUMP DETAIL
P6.01 SCALE: NONE

DETAILS — PLUMBING

**PCC ROCK CREEK CAMPUS
NEW BUILDING**

PORTLAND COMMUNITY COLLEGE
ROCK CREEK CAMPUS
9700 NW Springville Road
PORTLAND, OREGON 97229

THOMAS HACKER ARCHITECTS INC.
733 SW OAK STREET
PORTLAND, OREGON 97205
503 227-0254

PAE CONSULTING ENGINEERS
808 SW THIRD AVENUE
PORTLAND, OREGON 97204
503 226-2921



REVISIONS :

DATE : 02/14/03
SCALE : NONE

EXPIRES 12-31-04
DRAWN BY : RRR
JOB NO. : 0115














DWG. NO.






P6.01

















**THOMAS HACKER
ARCHITECTS INC.**


















ABBREVIATIONS			
AFF	ABOVE FINISHED FLOOR	KVA	KILOVOLT AMP
A	AMPERE (AMP)	KVAR	KILOVOLT AMPS REACTIVE
AL	ALUMINUM	LA	LIGHTNING ARRESTOR
ARCH	ARCHITECT / ARCHITECTURAL	LTG	LIGHTING
ATS	AUTOMATIC TRANSFER SWITCH	LV	LOW VOLTAGE
CB	CIRCUIT BREAKER	MATV	MASTER ANTENNA TELEVISION
C	CONDUIT	MCA	MINIMUM CIRCUIT AMPS
CCTV	CLOSED CIRCUIT TELEVISION	MCB	MAIN CIRCUIT BREAKER
CKT	CIRCUIT	MCC	MOTOR CONTROL CENTER
CLG	CEILING	MDP	MAIN DISTRIBUTION PANEL
CT	CURRENT TRANSFORMER	MECH	MECHANICAL
CU	COPPER	MH	METAL HALIDE
DN	DOWN	MLO	MAIN LUGS ONLY
EMERG	EMERGENCY	MV	MERCURY VAPOR
EMT	ELECTRIC METALLIC TUBING	MTS	MANUAL TRANSFER SWITCH
EP	EXPLOSION PROOF	NIC	NOT IN CONTRACT
EPO	EMERGENCY POWER OFF	NL	NIGHT LIGHT CIRCUIT
EW	ELECTRIC WATER COOLER	PA	PUBLIC ADDRESS
FA	FIRE ALARM	PE	PHOTO ELECTRIC CELL
FLA	FULL LOAD AMPS	PF	POWER FACTOR
FLUOR	FLUORESCENT	PNL	PANELBOARD
FCIC	FURNISHED BY CONTRACTOR	PVC	POLYVINYL CHLORIDE CONDUIT
	INSTALLED BY CONTRACTOR	PWR	POWER
FOIC	FURNISHED BY OWNER	SDP	SUB-DISTRIBUTION PANEL
	INSTALLED BY CONTRACTOR	STR	STARTER
FOIO	FURNISHED BY OWNER	SV	SOLENOID VALVE
	INSTALLED BY OWNER	SW	SWITCH
F.O.	FIBER OPTIC	TD	TIME DELAY
GFP	GROUND FAULT PROTECTION	TP	TAMPERPROOF
GFI	GROUND FAULT INTERRUPTER	TTB	TELEPHONE TERMINAL BOARD
GFI	GROUND FAULT CIRCUIT INTERRUPTER	TTC	TELEPHONE TERMINAL CABINET
GRC	GALVANIZED RIGID CONDUIT	TV	TELEVISION
GRD	GROUND	TYP	TYPICAL
HP	HORSEPOWER	UG	UNDERGROUND
HPS	HIGH PRESSURE SODIUM	UON	UNLESS OTHERWISE NOTED
HV	HIGH VOLTAGE	UPS	UNINTERRUPTABLE POWER SUPPLY
HZ	HERTZ	V	VOLTAGE
IG	ISOLATED GROUND	VA	VOLT AMPERES
INC	INCANDESCENT	VP	VAPOR PROOF
JB	JUNCTION BOX	W	WATTS
KW	KILOWATT	WP	WEATHER PROOF
KWH	KILOWATT HOUR	XFMR	TRANSFORMER
KV	KILOVOLT	XFSW	TRANSFER SWITCH

           
 
 
LIGHTING	
	CEILING LUMINAIRE: SURFACE, RECESSED
	CEILING LUMINAIRE: PENDANT MOUNTED
	WALL LUMINAIRE: SURFACE, RECESSED
	WALL WASHER: SURFACE, RECESSED
	TRACK WITH HEADS LOCATED
	FLUORESCENT LUMINAIRE: SURFACE, RECESSED
	FLUORESCENT LUMINAIRE: WALL MOUNTED, PENDANT
	FLUORESCENT LUMINAIRE: BARE LAMP
	POLE LIGHT: LUMINAIRES AS SHOWN
	DESIGNATES LIGHT ON EMERGENCY CIRCUIT
	EXIT LIGHT: CEILING, WALL (ARROWS AS SHOWN)
	BOLLARD
	EMERGENCY BATTERY LIGHT: HEADS AS SHOWN
	WALL SWITCH: 1 POLE, 2 POLE
	WALL SWITCH: 3 WAY, 4 WAY
	WALL SWITCH: KEY LOCK, MOMENTARY
	WALL SWITCH: LOW VOLTAGE, PILOT
	WALL SWITCH: TIMER, MANUAL DIMMER
	PHOTOELECTRIC CELL, OCCUPANCY SENSOR
	DESIGNATES LUMINAIRE TYPE (SEE LUMINAIRE SCHEDULE)

     EQUIPMENT	
	ELECTRICAL EQUIPMENT
	PANELBOARD: SURFACE, RECESSED
	CABINET: SURFACE, RECESSED
	TRANSFORMER
	GROUND ROD, IN TEST WELL
	GROUND PAD
	EQUIPMENT WITH DERIVED GROUND
	VOLTMETER, AMMETER
	SELECTOR SWITCH: VOLTMETER, AMMETER
	METER: KILOWATT HOUR, POWER FACTOR
	POTENTIAL TRANSFORMER
	CURRENT TRANSFORMER
	CABLE TRAY: CENTER SUPPORT, OUTER SUPPORTS

                POWER	
	WALL RECEPTACLE: SINGLE, DUPLEX
	WALL RECEPTACLE: EMERGENCY, 4-PLEX
	CEILING RECEPTACLE: DUPLEX
	DENOTES RECEPTACLE ABOVE COUNTER
	SPECIAL PURPOSE OUTLET AS NOTED, EMERGENCY
	CLOCK HANGER RECEPTACLE
	FLUSH IN-FLOOR OUTLET: SEE PLANS FOR TYPE
	PEDESTAL OUTLET: POWER, SIGNAL, COMBINATION
	SURFACE OUTLET STRIP: DIMENSION AS SHOWN
	TELEPOWER POLE, POWER, COMBINATION
	JUNCTION BOX
	DISCONNECT SWITCH: FUSED, NON-FUSED
	MOTOR STARTER: MANUAL, MAGNETIC, COMBINATION
	MOTOR CONNECTION
	CONTACTOR, RELAY, SOLENOID
	PUSH BUTTON STATION
	WIRING CONCEALED IN CEILING OR WALL
	WIRING CONCEALED IN FLOOR OR UNDERGROUND
	INDICATES INSULATED GREEN GROUND WIRE
	HOME RUN DESTINATION SHOWN
	CONDUIT ELL: UP, DN.

     ONE-LINE	
	CIRCUIT BREAKER
	SWITCH, FUSED SWITCH
	BUSS
	AUTOMATIC SWITCH
	METER
	PANEL
	FEEDER CALLOUT
	FAULT CURRENT CALLOUT

          SIGNAL	
	SPRINKLER SYSTEM SWITCH: FLOW, TAMPER
	MANUAL FIRE ALARM STATION
	DETECTOR: IONIZATION, HEAT, PHOTOELECTRIC
	DUCT DETECTOR, TYPE AS NOTED
	FIRE ALARM: VISUAL
	FIRE ALARM: BELL; BELL W/VISUAL
	FIRE ALARM: CHIME; CHIME W/VISUAL
	FIRE ALARM: HORN; HORN W/VISUAL
	FIREMANS PHONE JACK
	SPEAKER: WALL, CEILING
	MAGNETIC DOOR HOLDER, CLOSER
	ELECTRIC DOOR LOCK, CONTACT
	FIRE ALARM SPEAKER: WALL, CEILING
	WALL OUTLET: DATA
	WALL OUTLET: BLANK
	WALL OUTLET: COMBINATION TELEPHONE/DATA
	WALL OUTLET: MICROPHONE, INTERCOM, AUDIO JACK
	FLUSH IN-FLOOR OUTLET: DATA
	CCTV CAMERA
	SYSTEM CLOCK: WALL, CEILING
	MASTER ANTENNA TV OUTLET
	CARD KEY READER STATION
	SECURITY ELECTRONIC SENSOR

   DESIGNATION SYMBOLS	
	EQUIPMENT DESIGNATOR SEE SCHEDULE.
	EXISTING TO REMAIN, EXISTING TO BE REMOVED
	EXISTING TO BE RELOCATED
	NEW, FUTURE
	NOTE

NOTE	
THIS IS A STANDARD LEGEND SHEET, THEREFORE, SOME SYMBOLS MAY APPEAR ON THIS SHEET THAT DO NOT APPEAR ON THE DRAWINGS.	

LEGENDS, SYMBOLS AND ABBREVIATIONS - ELECTRICAL

PCC ROCK CREEK CAMPUS NEW BUILDING

PORTLAND COMMUNITY COLLEGE
ROCK CREEK CAMPUS
1700 NW Springville Road
PORTLAND, OREGON 97229

THOMAS HACKER ARCHITECTS INC.
703 SW OAK STREET
PORTLAND, OREGON 97205
0603 227-0254

PAE CONSULTING ENGINEERS
808 SW THIRD AVENUE
PORTLAND, OREGON 97204
0603 228-2921



REVISIONS :


DATE : 02/14/03
SCALE : NONE

EXPRES 12-31-04
DRAWN BY : WED
JOB NO. : 0115

DATE : 02/14/03
SCALE : NONE
DWG. NO. :

E0.01

THOMAS HACKER
ARCHITECTS INC.

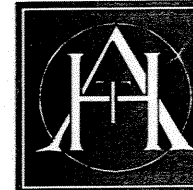

GENERAL NOTES:
1. PROVIDE DIMMING BALLASTS IN ALL FLUORESCENT FIXTURES LOCATED IN ROOMS WITH DAYLIGHT PHOTO SENSOR.

- NOTES:
- ① LOW VOLTAGE SWITCH LAYOUT:
- ② LOW VOLTAGE SWITCH LAYOUT:
- ③ LOW VOLTAGE SWITCH LAYOUT:
- ④ LOW VOLTAGE SWITCH LAYOUT:
- ⑤ LOW VOLTAGE SWITCH LAYOUT:
- ⑥ LOW VOLTAGE TRANSFORMERS MOUNTED ABOVE CEILING.
- ⑦ ROUTE ALL CONDUIT IN INSULATION ABOVE ROOF CANOPY.
- ⑧ ROUTE CONDUIT IN INSULATION SPACE AND INTO WALL ABOVE WINDOW DOOR MULLION.
- ⑨ PROVIDE NOVITAS DUAL TECHNOLOGY CEILING MOUNTED OCCUPANCY SENSOR. CONNECT FOR MASTER CONTROL OF ROOM AHEAD OF ANY SWITCHING SHOWN. SEE SPECIFICATIONS.
- ⑩ ROUTE UP TO LIGHTING ON SECOND FLOOR. SEE 1/E2.02.

FIRST FLOOR PLAN LIGHTING
PCC ROCK CREEK CAMPUS
NEW BUILDING

PORTLAND COMMUNITY COLLEGE
ROCK CREEK CAMPUS
5700 NW Springdale Road
PORTLAND, OREGON 97229

THOMAS HACKER ARCHITECTS INC.
733 SW OAK STREET
PORTLAND, OREGON 97205
(503) 227-1254

PAE CONSULTING ENGINEERS
808 SW THIRD AVENUE
PORTLAND, OREGON 97204
(503) 226-2921

REVISIONS : 03/21/03

DATE : 02/14/03
SCALE : NONE



DRAWN BY : WBO
JOB NO. : 0115


DWG. NO.



E2.01

THOMAS HACKER
ARCHITECTS INC.



1 FIRST FLOOR PLAN - LIGHTING
E2.01 SCALE: 1/8" = 1'-0"

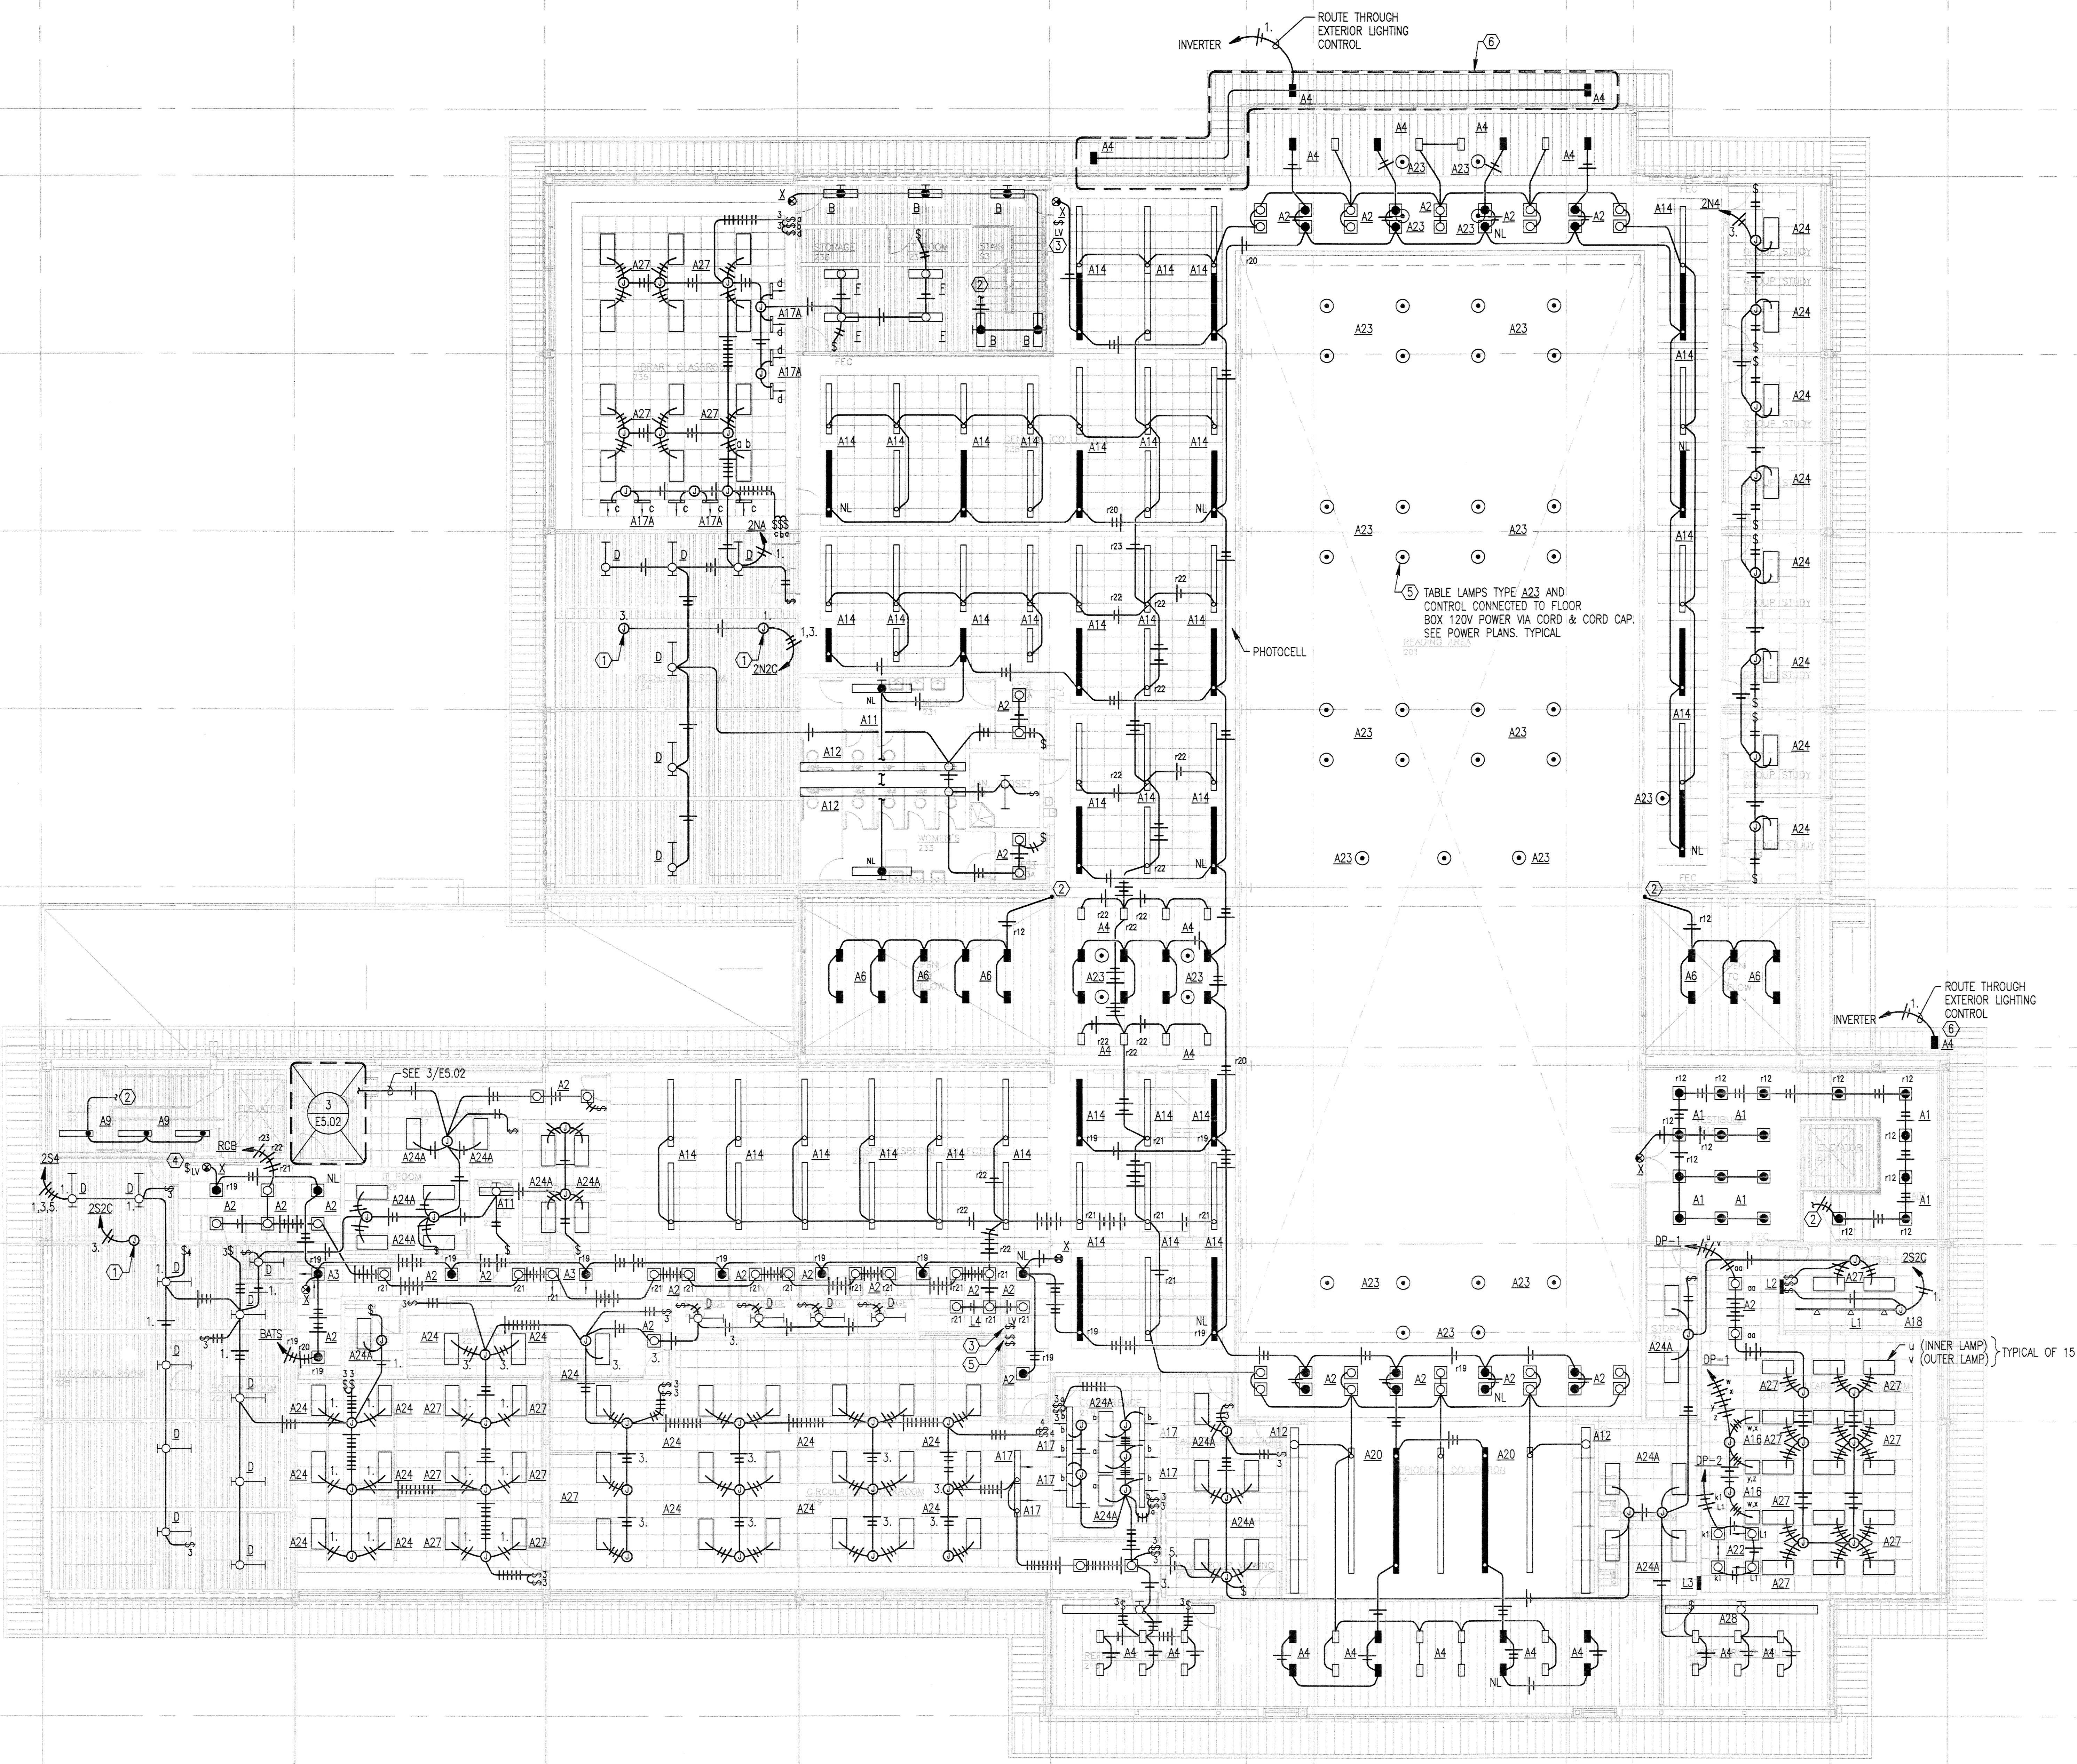

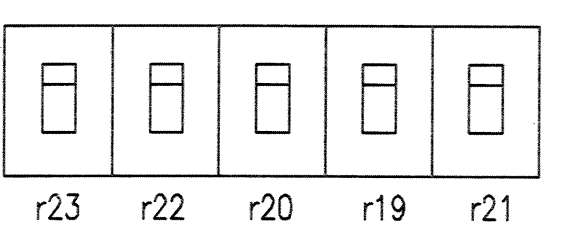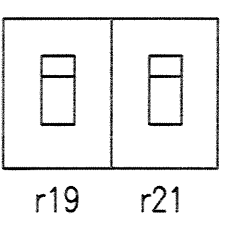- NOTES:**
1. PROVIDE J-BOX FOR CONNECTION TO MECHANICAL EQUIPMENT INTERIOR LIGHTING AND CONTROL.
 2. ROUTE DOWN TO FIRST FLOOR LIGHTING, SEE E2.01.
 3. LOW VOLTAGE LIGHTING CONTROL CONFIGURATION:

 4. LOW VOLTAGE LIGHTING CONTROL CONFIGURATION:

 5. SWITCHES FOR CONTROL AT RELAYS CONTROLLING FLOOR BOX POWER AT READING TABLES. SEE DETAIL 6/5.03.
 6. ROUTE CONDUIT IN INSULATION ABOVE CANOPY.

SECOND FLOOR PLAN LIGHTING

**PCC ROCK CREEK CAMPUS
NEW BUILDING**

PORTLAND COMMUNITY COLLEGE
ROCK CREEK CAMPUS
5700 NW Springdale Road
PORTLAND, OREGON 97209

THOMAS HACKER ARCHITECTS INC.
733 SW Oak Street
PORTLAND, OREGON 97205
503.227.0544

PAE CONSULTING ENGINEERS
808 SW Third Avenue
PORTLAND, OREGON 97204
503.226.2921



REVISIONS :  03/21/03

DRAWN BY : WSD
JOB NO. : 0115


DATE : 02/14/03
SCALE : NONE

DWG. NO. : E2.02

1 SECOND FLOOR PLAN - LIGHTING
E2.02 SCALE: 1/8" = 1'-0"

**THOMAS HACKER
ARCHITECTS INC.**



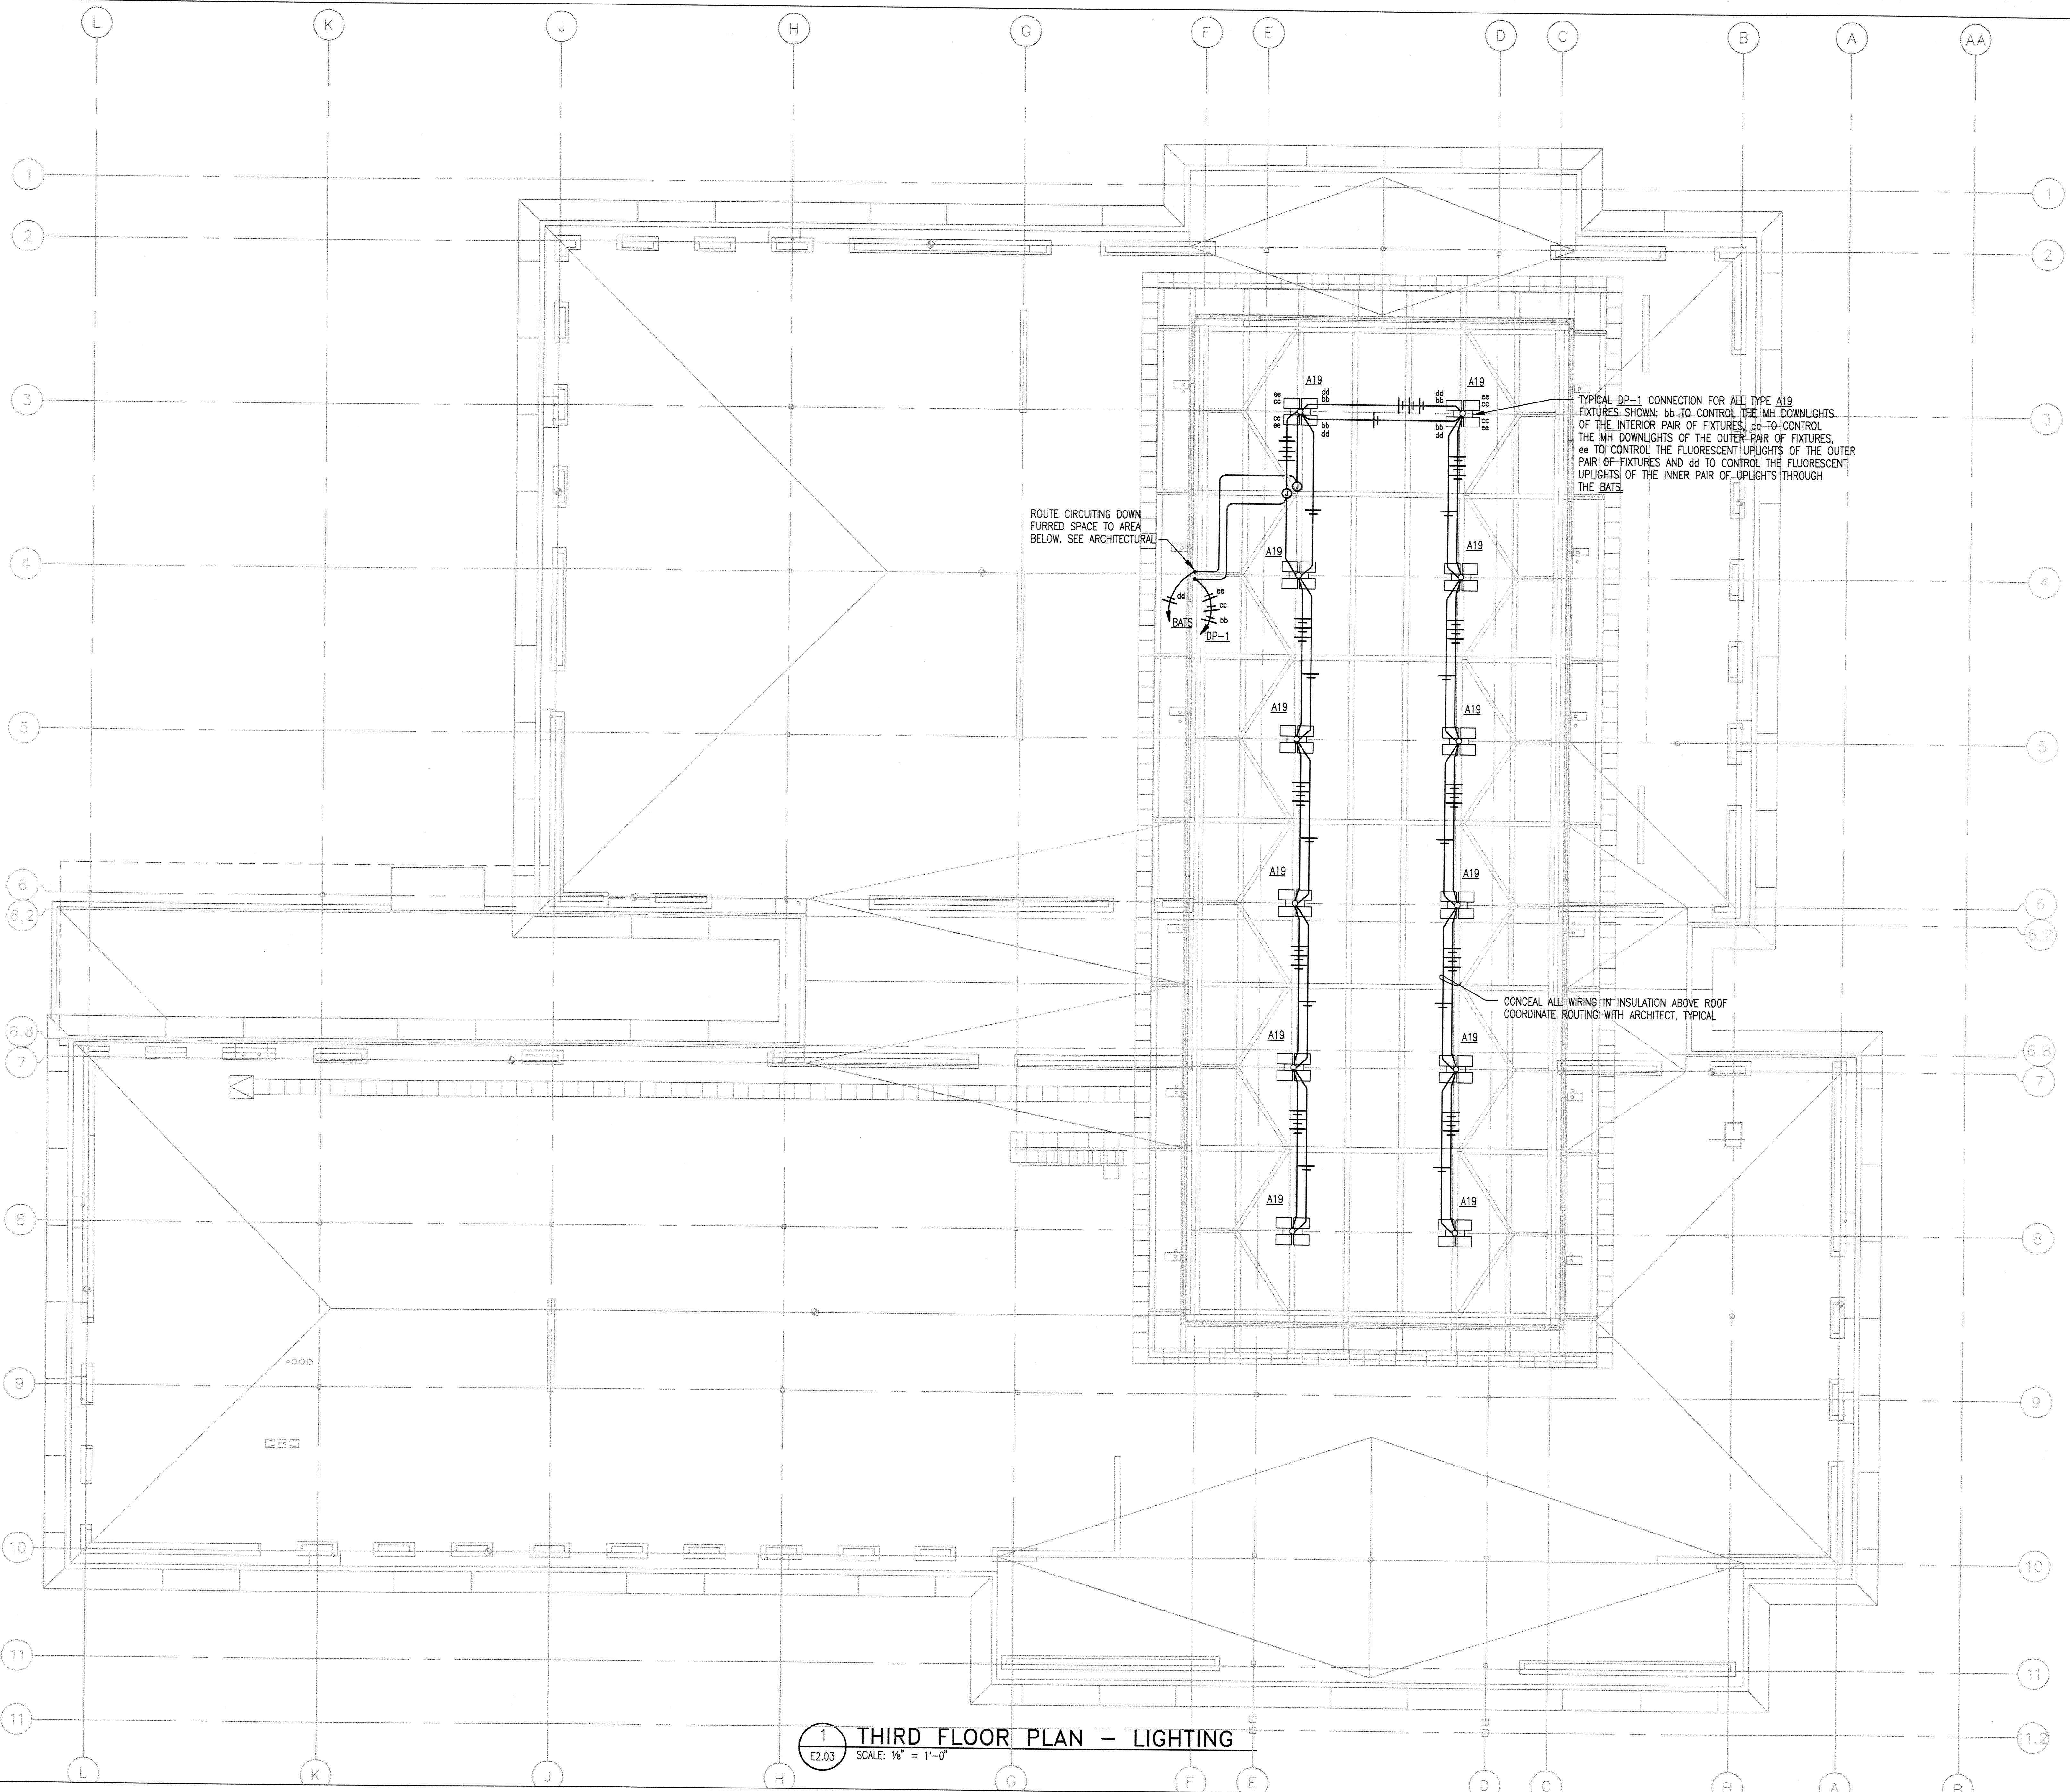

1 THIRD FLOOR PLAN - LIGHTING
E2.03 SCALE: 1/8" = 1'-0"


THIRD FLOOR PLAN
LIGHTING
PCC ROCK CREEK CAMPUS
NEW BUILDING
PORTLAND COMMUNITY COLLEGE
ROCK CREEK CAMPUS
1700 NW Springdale Road
PORTLAND, OREGON 97229
THOMAS HACKER ARCHITECTS INC.
735 SW Oak Street
PORTLAND, OREGON 97205
(503) 227-1254
PAE CONSULTING ENGINEERS
808 SW Third Avenue
PORTLAND, OREGON 97204
(503) 226-2921



REVISIONS :
DATE : 02/14/03
SCALE : NONE
DRAWN BY : WBD
JOB NO. : 0115
DWG. NO. : E2.03

THOMAS HACKER
ARCHITECTS INC.



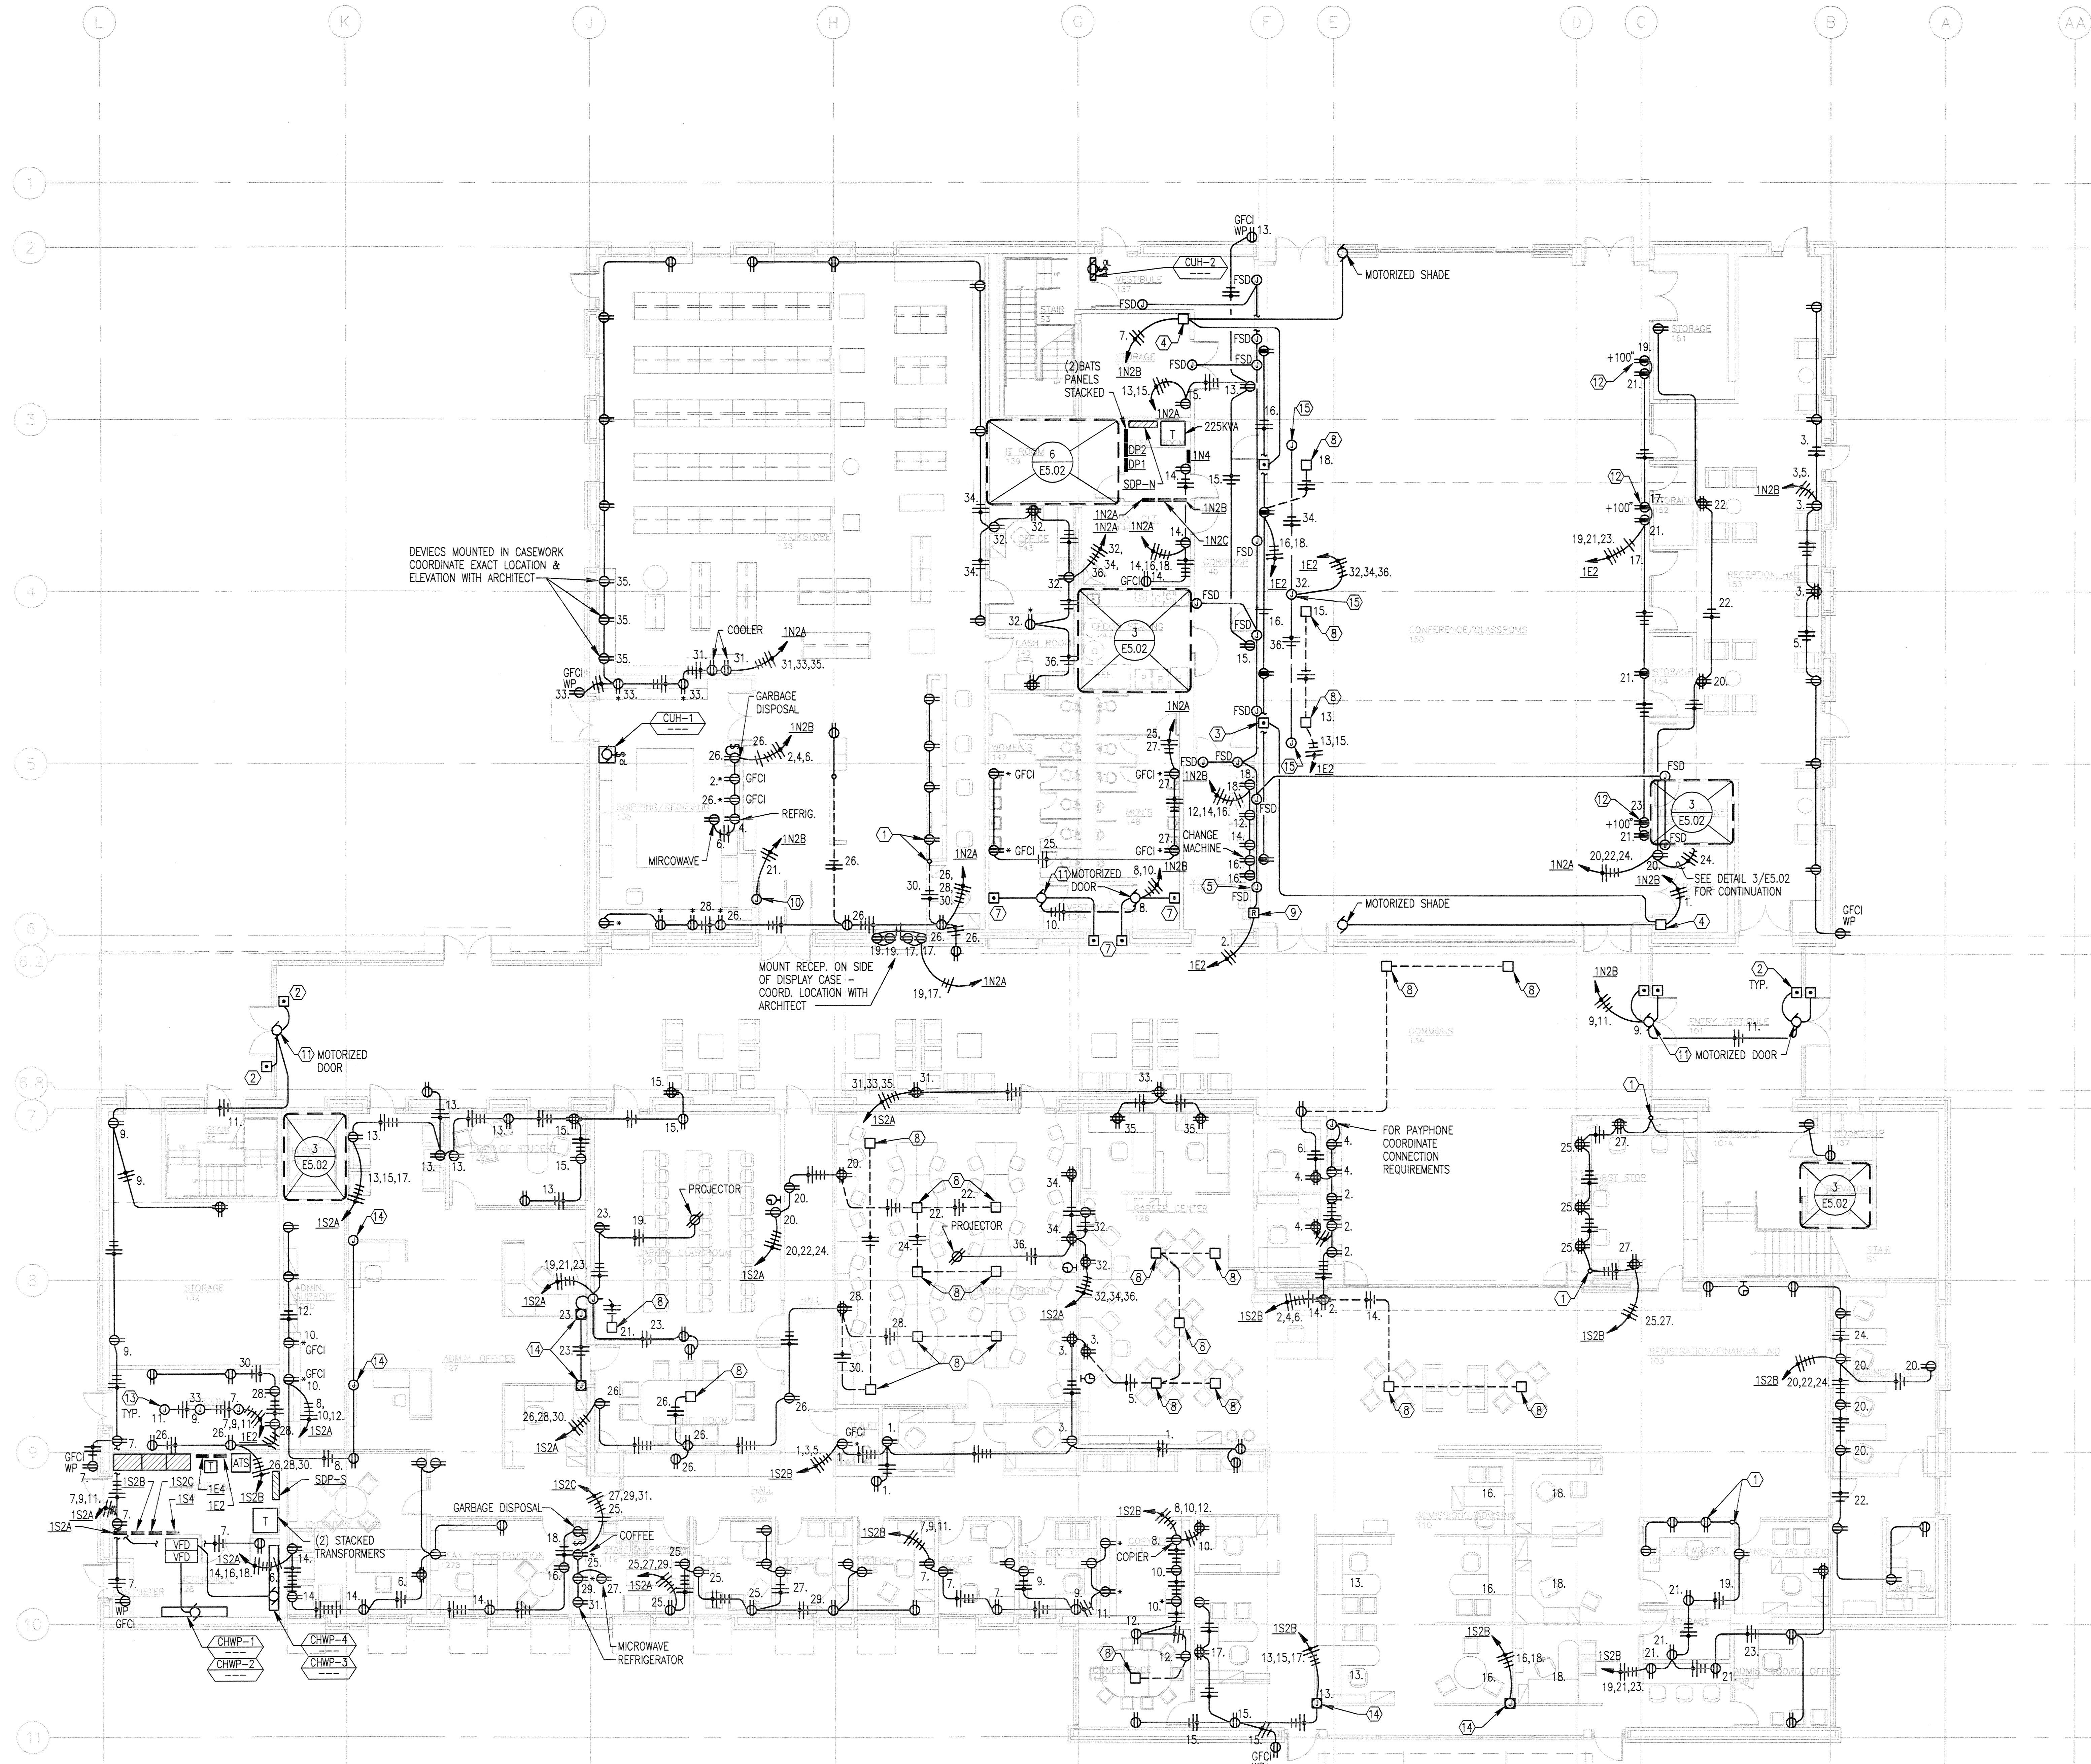

- GENERAL NOTES:**
- COORDINATE ALL DEVICE LOCATIONS WITH ARCHITECTURAL INTERIOR ELEVATIONS.
 - SEE EQUIPMENT CONNECTION SCHEDULE ON E5.01 FOR ALL DEVICES NOT SHOWN CIRCUITED ON PLANS.
 - COORDINATE PARTITION CONNECTION REQUIREMENTS FOR ALL POWERED MODULAR FURNITURE. CONNECT DEVICES TO CIRCUITS DESIGNATED.
 - WALK ARCHITECT THROUGH J-BOX LAYOUT PRIOR TO WIRING.
- NOTES:**
- STUB INTO CASEWORK AND MOUNT RECEPTACLES IN CASEWORK. COORDINATE WITH CASEWORK SUPPLIER AND ARCHITECT.
 - MOUNT TO MULLION. SEE DETAIL 6/E5.03 TYPICAL. PROVIDE 1/2" CONDUIT FROM MOTOR TO MULLION.
 - SHADE LV CONTROL SWITCH. TYPICAL OF 2. COORDINATE WITH DRAPERY SUPPLIER.
 - SHADE CONTROL MODULE. COORDINATE WITH SHADE SUPPLIER.
 - COORDINATE CONNECTION OF FIRE SMOKE DAMPERS WITH MECHANICAL.
 - COORDINATE J-BOX LOCATION WITH RACKS. COORDINATE QUANTITY AND LOCATION OF RACK MOUNTED RECEPTACLES IN THIS AREA.
 - WALL MOUNT MOTORIZED DOOR CONTROL SWITCH COORDINATE ROUGH IN AND PATHWAY REQUIREMENT WITH SUPPLIER.
 - PROVIDE SPIDER MANUFACTURING #AFB-501 FLUSH FLOOR BOX WITH #AFB-501-PB CONCRETE POUR ADAPTER WITH (2) DUPLEX RECEPTACLES. COORDINATE EXACT LOCATION WITH ARCHITECT.
 - PROVIDE INTERPOSING RELAY FOR CONTROL OF FSD CIRCUIT. PROVIDE CONTROL CONNECTION TO FA PANEL. SEE 5/E5.03.
 - PROVIDE STEEL FLOOR BOX 5"x5" MOUNTED FLUSH IN FLOOR. PROVIDE COVER, GASKET, AND CARPET RING AS REQUIRED. CONNECT POWER CORD TO CIRCUIT SHOWN. COORDINATE WITH SECURITY GATE SUPPLIER FOR 3M MODEL #3802 BURIED POWER INSTALLATION INSTRUCTIONS.
 - COORDINATE CONNECTION OF DOOR CONTROL MOTOR WITH MOTOR SUPPLIER AND ARCHITECT. CONCEAL ALL CONDUIT.
 - FOR PROJECTOR COORDINATE WITH ARCHITECTURAL LOCATION.
 - CONNECT TO PLUGSTRIP FURNISHED WITH TELECOM RACKS. COORDINATE WITH TELECOMMUNICATIONS CONTRACTOR.
 - PROVIDE FLUSH SERIES FURNITURE FEED FLOOR BOX CONNECTION TO PARTITION. HUBBELL ONE PIECE UNIT COORDINATED FLOOR BOX LOCATION WITH ARCHITECT.
 - MOTORIZED PROJECTION SCREEN. INSTALL CONTROL FURNISHED WITH SCREEN. VERIFY LOCATION WITH ARCHITECT.

1 FIRST FLOOR PLAN - POWER
E3.01 SCALE: 1/8" = 1'-0"

FIRST FLOOR PLAN POWER
PCC ROCK CREEK CAMPUS NEW BUILDING
PORTLAND COMMUNITY COLLEGE
ROCK CREEK CAMPUS
5700 NW Springdale Road
PORTLAND, OREGON 97229

THOMAS HACKER ARCHITECTS INC.
733 SW OAK STREET
PORTLAND, OREGON 97205
503.227.1254

PAE CONSULTING ENGINEERS
808 SW THIRD AVENUE
PORTLAND, OREGON 97204
503.226.2921



REVISIONS : 03/21/03
DATE : 02/14/03
SCALE : 1/8" = 1'-0"

DRAWN BY : WBO
JOB NO. : 0115
DWG. NO. : E3.01

GENERAL NOTES:

1. COORDINATE ALL DEVICE LOCATIONS WITH ARCHITECTURAL.
2. PROVIDE 1 1/4" CONDUIT UP TO ABOVE ACCESSIBLE CEILING FROM ALL FLOOR BOXES AND WALL DATA BOXES SHOWN FOR NETWORK SERVICES UN. DRILL HOLE AS REQUIRED TO CONNECT CONDUIT TO BOX.
3. WHERE DEVICES ARE SHOWN BELOW WINDOWS, ROUTE 1" CONDUIT OVER TO NEAREST WALL TO CEILING. MINIMIZE BENDS.

NOTES:

- 1 PROVIDE JUNCTION BOX ABOVE DOOR HEADER TO ACCOMMODATE SECURITY REQUIREMENTS. COORDINATE WITH ARCHITECTURAL AND OWNER. STUB 3/4" CONDUIT TO NEAREST ACCESSIBLE CEILING. PROVIDE J-BOX FOR CARD READER. COORDINATE WITH SECURITY SUPPLIER. WIRE TO FA FOR INSTRUCTIONS.
- 2 PROVIDE CONDUIT FOR A/V.
- 3 FLUSH FLOOR BOX. SEE E3.01 FOR SPEC. PROVIDE 1 1/2" CONDUIT TO ABOVE CEILINGS AS SHOWN FOR PODIUM A/V AND (2) 1" NETWORK. COORDINATE LOCATION W/POWER FLOOR BOXES SEE E3.01.
- 4 PROVIDE 1 GANG MUD RING WITH BLANK PLATE AND PULL STRING AT ALL SPEAKER LOCATION FLANKING SCREENS.
- 5 INSTRUCTORS PODIUM.
- 6 STUB IN CASEWORK AND MOUNT TELECOM PROVISIONS IN CASEWORK. COORDINATE WITH CASEWORK SUPPLIER AND ARCHITECT.
- 7 J-BOX FOR A/V LOCATED IN CEILING SPACE. COORDINATE WITH ARCHITECT FOR EXACT LOCATION.
- 8 FLOOR BOX WITH 1" CONDUIT TO NEAREST WALL OR ACCESSIBLE CEILING SPACE. COORDINATE EXACT LOCATION WITH ARCHITECT. SEE E3.01 FOR SPEC.
- 9 CLOCK AND PROGRAM CLOCK CONNECT TO MASTER CLOCK CONTROL PANEL SYSTEM. EQUAL TO SIMPLEX.
- 10 CCTV SECURITY CAMERA. NO WORK REQUIRED WHERE CAMERA IS ON ACCESSIBLE CEILING. PROVIDE ROUGH-IN SHOWN.
- 11 PROVIDE WEATHER PROOF PUSH BUTTON TO ACTIVATE INTERCOM AT LIBRARY CIRCULATION DESK.
- 12 PROVIDE 1 1/4" RIGID NON METALLIC CONDUIT IN FLOOR FOR SECURITY GATE INTERCONNECTION. COORDINATE WITH SECURITY GATE SUPPLIER FOR 3M MODEL #3802 BARRIED CABLE INSTALLATION INSTRUCTIONS.
- 13 PROVIDE TALK-A-PHONE MS-400 FLUSH MOUNTING STEEL BOX WITH 1" CONDUIT TO NEAREST ACCESSIBLE CEILING. DRILL HOLE AS REQUIRED TO CONNECT CONDUIT TO BOX.
- 14 PROVIDE J-BOX IN WALL WITH 1" CONDUIT ROUTED TO ACCESSIBLE CEILING SPACE FOR MOTORIZED WINDOWS. COORDINATE WITH WINDOW SUPPLIER AND DIV. 15.
- 15 POWER NETWORK FLOOR BOX SEE E3.01 FOR SPEC. PROVIDE 1"C. UP TO ABOVE ACCESSIBLE CEILING FOR NETWORK.
- 16 SPIDER MFG AFB-501 FLUSH FLOOR BOX WITH AFB-501-PB CONCRETE POUR BOX LOCATED ADJACENT TO POWER/NETWORK BOX. PROVIDE 1 1/2" CONDUITS FOR A/V AS SHOWN. DRILL BOX AS REQUIRED FOR CONDUITS.
- 17 PROVIDE FLUSH FLOOR BOX FOR PARTITION LV SERVICE. HUBBEL ONE PIECE UNIT PROVIDE FLEX WHIP.

FIRST FLOOR PLAN SIGNAL

PCC ROCK CREEK CAMPUS NEW BUILDING

PORTLAND COMMUNITY COLLEGE
ROCK CREEK CAMPUS
3700 NW Springville Road
PORTLAND, OREGON 97229

THOMAS HACKER ARCHITECTS INC
733 SW OAK STREET
PORTLAND, OREGON 97205
503.227.1054

PAE CONSULTING ENGINEERS
808 SW THIRD AVENUE
PORTLAND, OREGON 97204
503.226.2921

REVISIONS : 03/21/03

DATE : 02/14/03
SCALE : 1/8" = 1'-0"




EXPRES 12-31-04
DRAWN BY : WSD
JOB NO. : 0115

DWG. NO.

E4.01

THOMAS HACKER
ARCHITECTS INC.

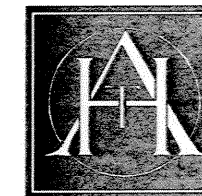

1 FIRST FLOOR PLAN - SIGNAL

E4.01 SCALE: 1/8" = 1'-0"

- GENERAL NOTES:**
1. COORDINATE ALL DEVICE LOCATIONS WITH ARCHITECTURAL INTERIOR ELEVATIONS.
 2. PROVIDE 1/4" CONDUIT UP TO ABOVE ACCESSIBLE CEILING FROM ALL FLOOR BOXES AND WALL DATA BOXES SHOWN FOR NETWORK SERVICES UN. DRILL HOLE AS REQUIRED TO CONNECT CONDUIT TO BOX.
 3. WHERE DEVICES ARE SHOWN BELOW WINDOWS, ROUTE 1" CONDUIT OVER TO NEAREST WALL TO CEILING. MINIMIZE BENDS.

- NOTES:**
- 1 MOUNT FIRE ALARM DEVICES ON CEILING.
 - 2 PROVIDE JUNCTION BOX ABOVE DOOR HEADER TO ACCOMMODATE SECURITY REQUIREMENTS. COORDINATE WITH ARCHITECTURAL AND OWNER. STUB 3/4" CONDUIT TO NEAREST ACCESSIBLE CEILING. PROVIDE J-BOX FOR CARD READER. COORDINATE WITH SECURITY SUPPLIER. WIRE TO FA PER INSTRUCTIONS.
 - 3 CLOCK AND PROGRAM CLOCK. CONNECT TO MASTER CLOCK CONTROL PANEL SYSTEM. EQUAL TO SIMPLEX.
 - 4 FLUSH FLOOR BOX. PROVIDE 1/2" CONDUIT TO ABOVE CEILINGS AS SHOWN FOR PODIUM A/V AND NETWORK.
 - 5 CCTV SECURITY CAMERA. NO WORK REQUIRED WHERE CAMERA IS ON ACCESSIBLE CEILING. PROVIDE ROUGH-IN SHOWN.
 - 6 PROVIDE 1/4" RIGID NON METALLIC CONDUIT IN FLOOR FOR SECURITY GATE INTERCONNECTION. COORDINATE WITH SECURITY GATE SUPPLIER FOR 3M MODEL #3802 BARRIED CABLE INSTALLATION INSTRUCTIONS.
 - 7 PROVIDE J-BOX IN WALL WITH 1" CONDUIT ROUTED TO ACCESSIBLE CEILING SPACE FOR MOTORIZED WINDOWS. COORDINATE WITH WINDOW SUPPLIER AND DIV. 15.
 - 8 DATA ONLY FLOOR BOX SPIDER MANUFACTURING #AFB-301 FLUSH FLOOR BOX WITH AFB-301-PB CONCRETE POUR ADAPTER LOCATE ADJACENT TO TABLE POWER FLOOR BOX - SEE E3.02. PROVIDE (1)1"C. TO WALL 7 UP TO ABOVE NEAREST ACCESSIBLE CEILING.
 - 9 POWER/DATA FLUSH FLOOR BOX - SEE E3.02 FOR SPEC. PROVIDE (1)1"C. TO WALL & UP TO ABOVE NEAREST ACCESSIBLE CEILING.

**SECOND FLOOR PLAN
SIGNAL**

**PCC ROCK CREEK CAMPUS
NEW BUILDING**

PORTLAND COMMUNITY COLLEGE
ROCK CREEK CAMPUS
5700 SW SENGUPTA ROAD
PORTLAND, OREGON 97209

THOMAS HACKER ARCHITECTS INC.
733 SW OAK STREET
PORTLAND, OREGON 97205
503.227.1254

PAE CONSULTING ENGINEERS
808 SW THIRD AVENUE
PORTLAND, OREGON 97204
503.226.2921

REVISIONS : 03/21/03

DATE : 02/14/03
SCALE : 1/8" = 1'-0"



EXPIRES 12-31-04
DRAWN BY : WBD
JOB NO. : 0115

DWG. NO.

E4.02

**THOMAS HACKER
ARCHITECTS INC.**



1 SECOND FLOOR PLAN - SIGNAL
E4.02 SCALE: 1/8" = 1'-0"

GENERAL NOTES:
1. COORDINATE ALL DEVICE LOCATIONS WITH ARCHITECTURAL INTERIOR ELEVATIONS.

1 UPPER FLOOR PLAN - SIGNAL
E4.03 SCALE: 1/8" = 1'-0"

UPPER FLOOR PLAN
SIGNAL

PCC ROCK CREEK CAMPUS
NEW BUILDING

PORTLAND COMMUNITY COLLEGE
ROCK CREEK CAMPUS
9708 NW Springdale Road
PORTLAND, OREGON 97229

THOMAS HACKER ARCHITECTS INC.
733 SW OAK STREET
PORTLAND, OREGON 97205
(503) 227-1254

PAE CONSULTING ENGINEERS
808 SW THIRD AVENUE
PORTLAND, OREGON 97204
(503) 226-2921

REVISIONS : 1 03/21/03

DATE : 02/14/03
SCALE : 1/8" = 1'-0"




EXPIRES 12-31-04
DRAWN BY : WBD
JOB NO. : 0115

DWG. NO.

E4.03

THOMAS HACKER
ARCHITECTS INC.



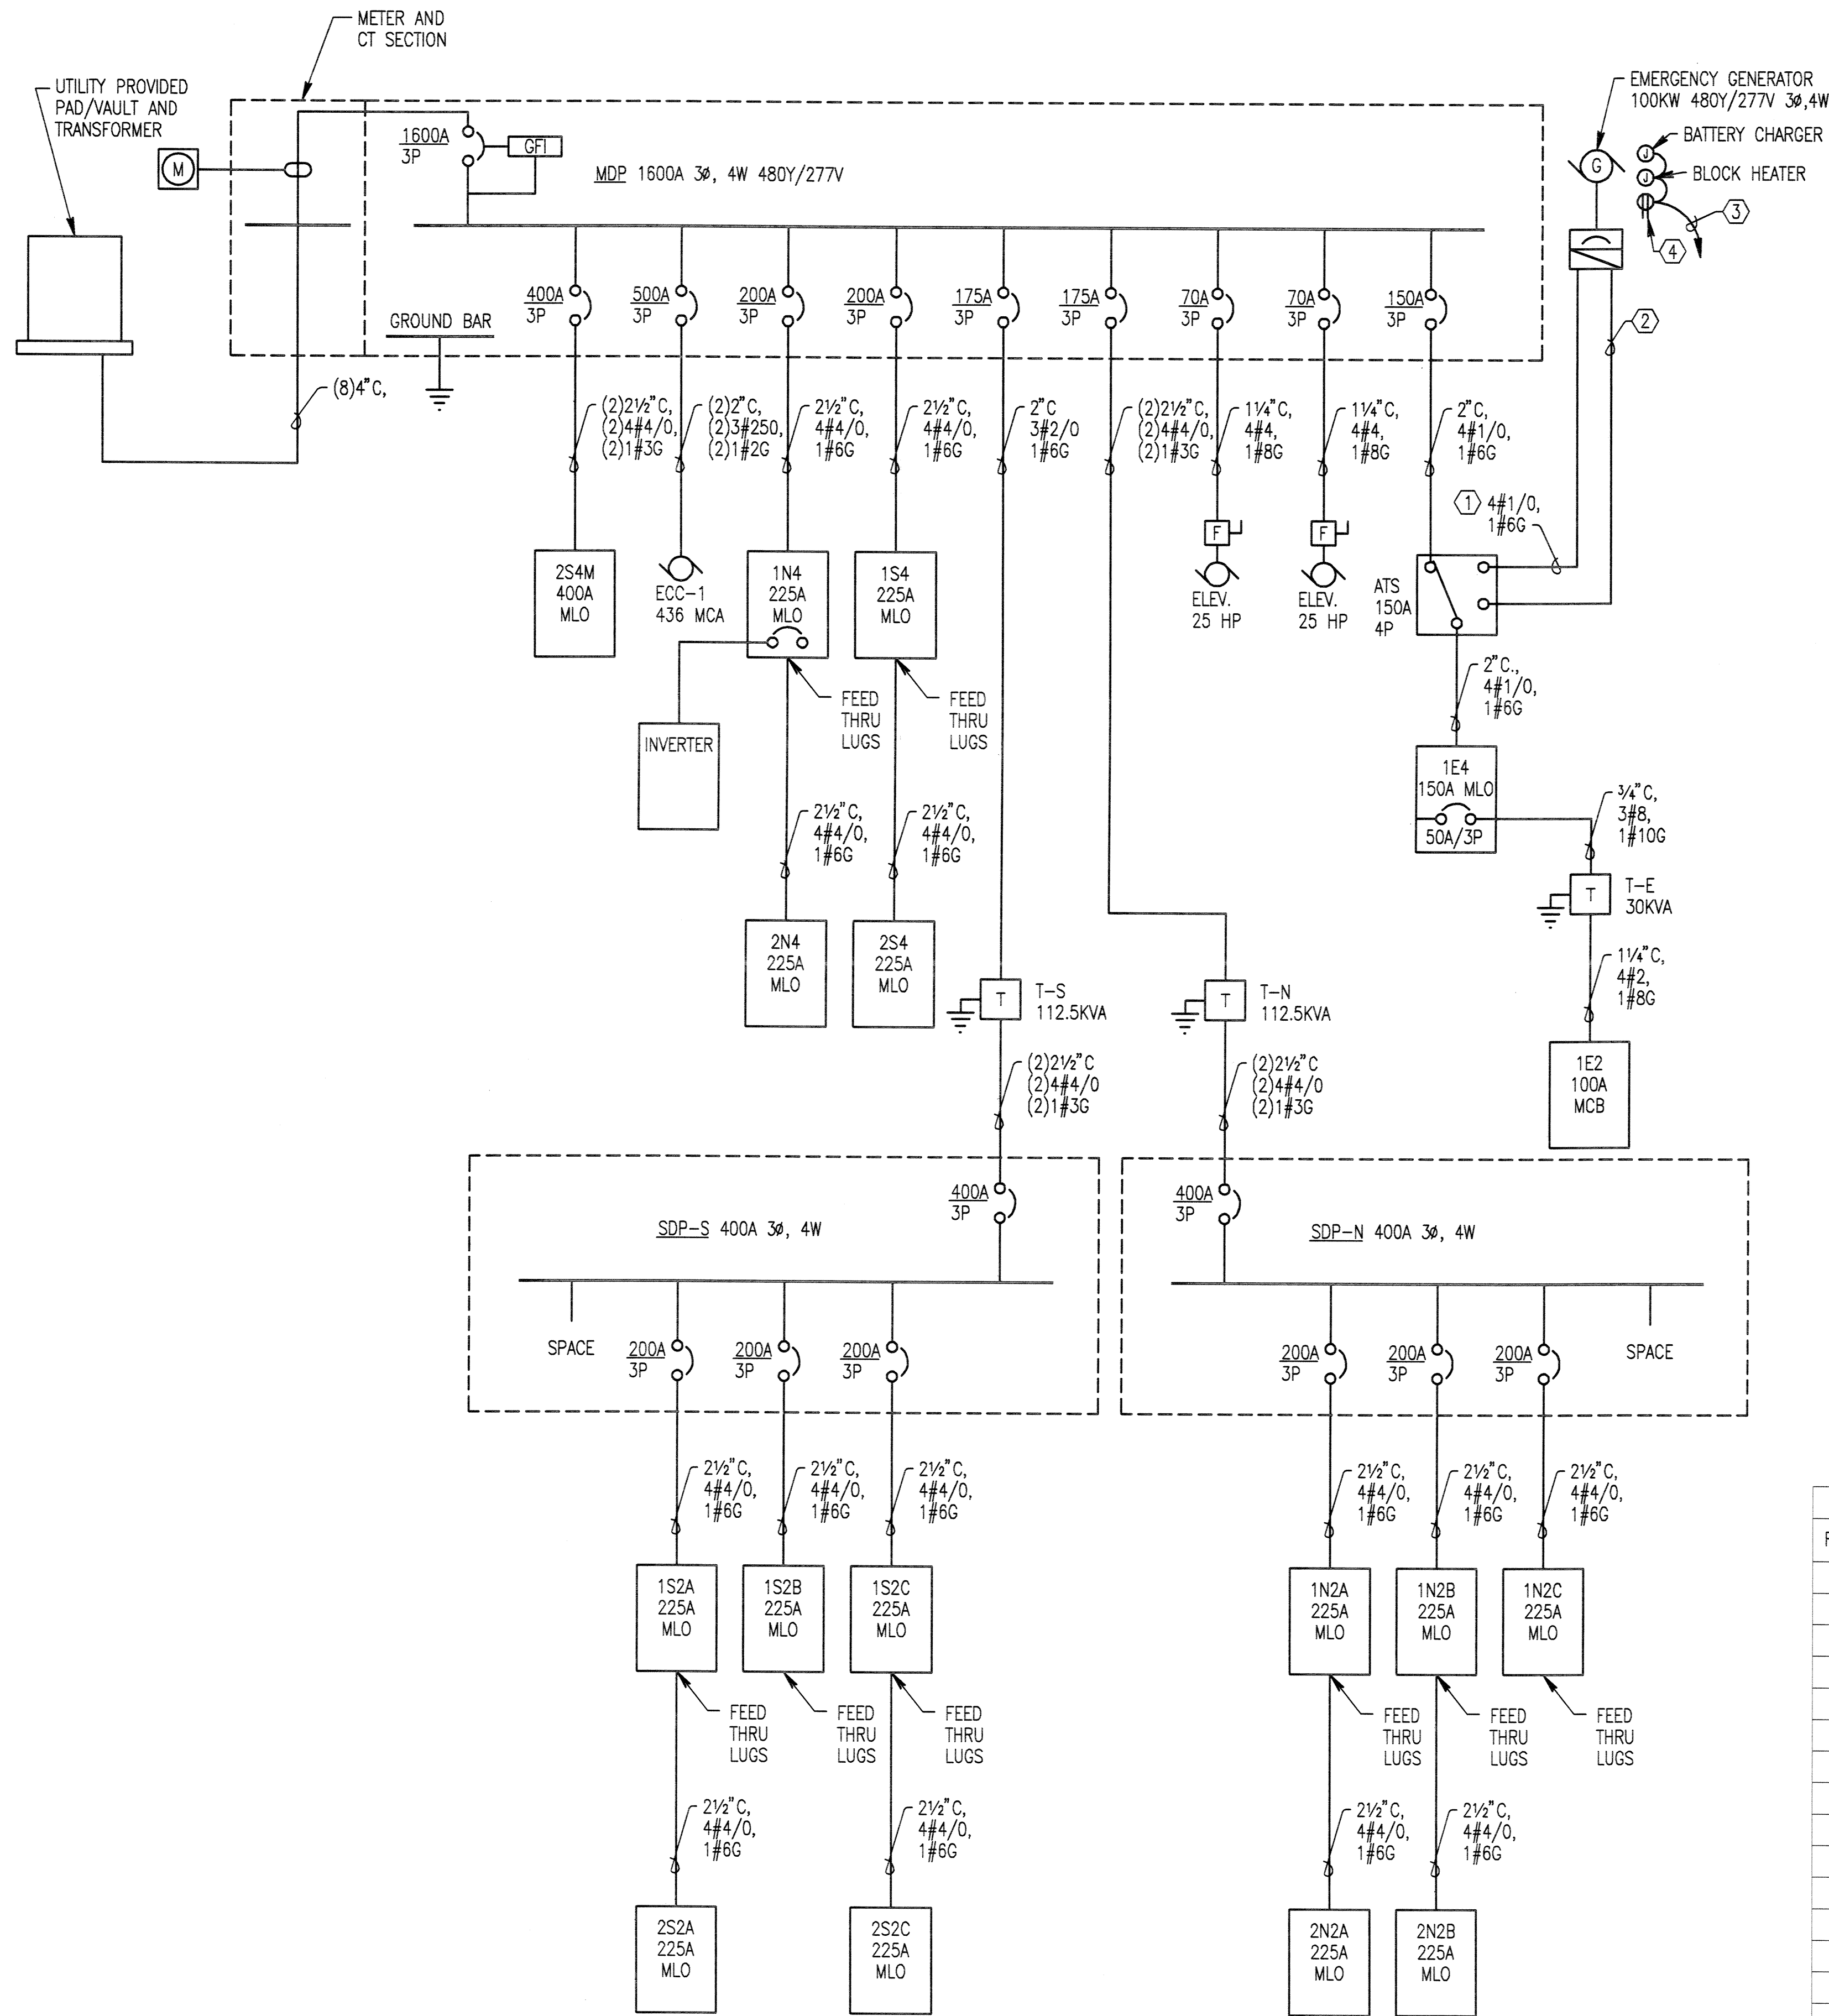

NOTES:

- EXISTING 2" CONDUIT PROVIDED UNDER SITE PACKAGE. SEE 1/E1.01. EXTEND TO GENERATOR OUTPUT BREAKER AND ATS. PULL WIRE AS SHOWN.
- EXISTING 1" CONDUIT PROVIDED UNDER SITE PACKAGE FOR CONTROL. EXTEND TO GENERATOR CONTROL PANEL AND ATS. PROVIDE WIRING AS REQUIRED.
- EXISTING 1" CONDUIT PROVIDED UNDER SITE PACKAGE. PROVIDE 3#10, 1#10G FOR 120V BATTERY CHARGER AND 120V BLOCK HEATER AT GENERATOR. CONNECT TO CIRCUIT 33 IN PANEL 1E2.
- PROVIDE WP, GFCI RECEPTACLE AT GENERATOR. CONNECT TO BLOCK HEATER CIRCUIT 31 IN PANEL 1E2.

ONE-LINE DIAGRAM

SCALE: NONE

RELAY CONTROL SCHEDULE				
RELAY	LOAD	PANEL	CIRCUIT	NOTES
RCA				
r1	1575	1N2C	1	BOOK STORE TRACK
r2	1575	1N2C	3	BOOK STORE TRACK
r3	1575	1N2C	5	BOOK STORE TRACK
r4	1575	1N2C	7	BOOK STORE TRACK
r5	1575	1N2C	2	BOOK STORE TRACK
r6	1575	1N2C	4	BOOK STORE TRACK
r7	1575	1N2C	6	BOOK STORE TRACK
r8	1575	1N2C	8	BOOK STORE TRACK
r9	1904	1N4	1	BOOK STORE LTG
r10	778	1N4	3	BOOK STORE LTG
r11	717	1N4	3	BOOK STORE LTG
r12	800	1E4	3	THROUGH RELAY BATS
r13	628	1E4	3	THROUGH RELAY BATS
r14	336	1E4	3	THROUGH RELAY BATS
r15	840	1E4	3	THROUGH RELAY BATS
r16	1764	1N4	6	SOUTH WEST LTG
r17	2484	1N4	8	SOUTH WEST LTG
r18	888	1N4	8	SOUTH WEST LTG
r24	1000	1N2C	9	LV TRANSFORMER
r25	93	1E4	1	THROUGH RELAY BATS
r26	372	1E4	1	THROUGH RELAY BATS
r27	496	1E4	1	THROUGH RELAY BATS
RCB				
r19	1804	1E4	5	THROUGH RELAY BATS
r20	2724	1E4	7	THROUGH RELAY BATS
r21	2696	2S4	2	2ND FLOOR LTG
r22	3444	2S4	4	2ND FLOOR LTG
r23	2592	2S4	6	2ND FLOOR LTG

BRANCH AUTOMATIC TRANSFER SWITCH (BATS) SCHEDULE				
MODULE	DIMMER	FEED	EMERG. FEED	AREA SERVED
PANEL CIRCUIT PANEL CIRCUIT				
DIMMER BATS				
1	DP-1	b	1E4	2 CLASSROOM
2	DP-1	dd	1E4	4 LIBRARY
3	DP-1	a	1E4	2 CLASSROOM
4	DP-1	g	1E4	2 CLASSROOM
5	DP-1	h	1E4	2 CLASSROOM
6	DP-1	i	1E4	2 CLASSROOM
7	DP-1	o	1E4	2 CLASSROOM
8	DP-1	p	1E4	2 CLASSROOM
9				SPARE
10				SPARE
11				SPARE
12				SPARE
MODULE RELAY FEED EMERG. FEED AREA SERVED				
PANEL CIRCUIT PANEL CIRCUIT				
RELAY BATS				
1	RPA	r12	1E4	3
2	RPA	r13	1E4	3
3	RPA	r14	1E4	3
4	RPA	r15	1E4	3
5	RPB	r19	1E4	5
6	RPB	r20	1E4	7
7	RPA	r25	1E4	8 BOOKSTORE
8	RPA	r26	1E4	8 BOOKSTORE
9	RPA	r27	1E4	8 BOOKSTORE
10				
11				
12				

DP-1 SCHEDULE 480Y/277V				
DIMMER	LOAD	EMERG. FEED	NOTES	
DESIG. SPEC PANEL CIRCUIT				
a	2	252 1E4	2	3 WIRE - SEE BATS SCHED.
b	3	756 1E4	2	3 WIRE - SEE BATS SCHED.
c	4	180	-	NON DIM
d	8	80	-	NON DIM
e	9a	240	-	NON DIM
f	9b	320	-	NON DIM
g	10	252 1E4	2	3 WIRE - SEE BATS SCHED.
h	11	504 1E4	2	3 WIRE - SEE BATS SCHED.
i	12	252 1E4	2	3 WIRE - SEE BATS SCHED.
j	13	180	-	NON DIM
k	14	180	-	NON DIM
l	20	80	-	NON DIM
m	21	240	-	NON DIM
n	22	320	-	NON DIM
o	26	252 1E4	2	3 WIRE - SEE BATS SCHED.
p	27	756 1E4	2	3 WIRE - SEE BATS SCHED.
q	28	180	-	NON DIM
r	32	80	-	NON DIM
s	33	240	-	NON DIM
t	34	320	-	NON DIM
u	41	450	-	NON DIM
v	42	900	-	NON DIM
w	43	160	-	NON DIM
x	44	160	-	NON DIM
y	45	80	-	NON DIM
z	46	80	-	NON DIM
aa	49	80	-	NON DIM
bb	50	1200	-	NON DIM
cc	51	2880	-	NON DIM
dd	52	1200 1E4	4	3 WIRE - SEE BATS SCHED.
ee	53	1880	-	NON DIM

DP-2 SCHEDULE 208Y/120V				
DIMMER	LOAD	EMERG. FEED	NOTES	
DESIG. SPEC PANEL CIRCUIT				
g1	5	300	-	INC. 2 WIRE - DIM
b1	7	1800	-	INC. 2 WIRE - DIM
c1	15	300	-	INC. 2 WIRE - DIM
d1	17	1350	-	INC. 2 WIRE - DIM
e1	18	300	-	INC. 2 WIRE - DIM
f1	23	150	-	INC. 2 WIRE - DIM
g1	24	750	-	INC. 2 WIRE - DIM
h1	25	300	-	INC. 2 WIRE - DIM
i1	29	300	-	INC. 2 WIRE - DIM
j1	31	1800	-	INC. 2 WIRE - DIM
k1	47	300	-	INC. 2 WIRE - DIM
l1	48	300	-	INC. 2 WIRE - DIM

ONE-LINE DIAGRAM & SCHEDULES - ELECTRICAL

PCC ROCK CREEK CAMPUS NEW BUILDING

PORTLAND COMMUNITY COLLEGE
ROCK CREEK CAMPUS
5700 NW Springdale Road
PORTLAND, OREGON 97209

THOMAS HACKER ARCHITECTS INC.
735 NW OAK STREET
PORTLAND, OREGON 97205
(503) 227-0254

PAE CONSULTING ENGINEERS
908 SW THIRD AVENUE
PORTLAND, OREGON 97204
(503) 226-2921



REVISIONS : 03/21/03


DRAWN BY : WBO
JOB NO. : 0115

DATE : 02/14/03
SCALE : NONE


EXPIRES 12-31-04

DWG. NO.

THOMAS HACKER ARCHITECTS INC.

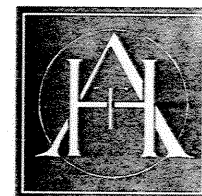


E5.01

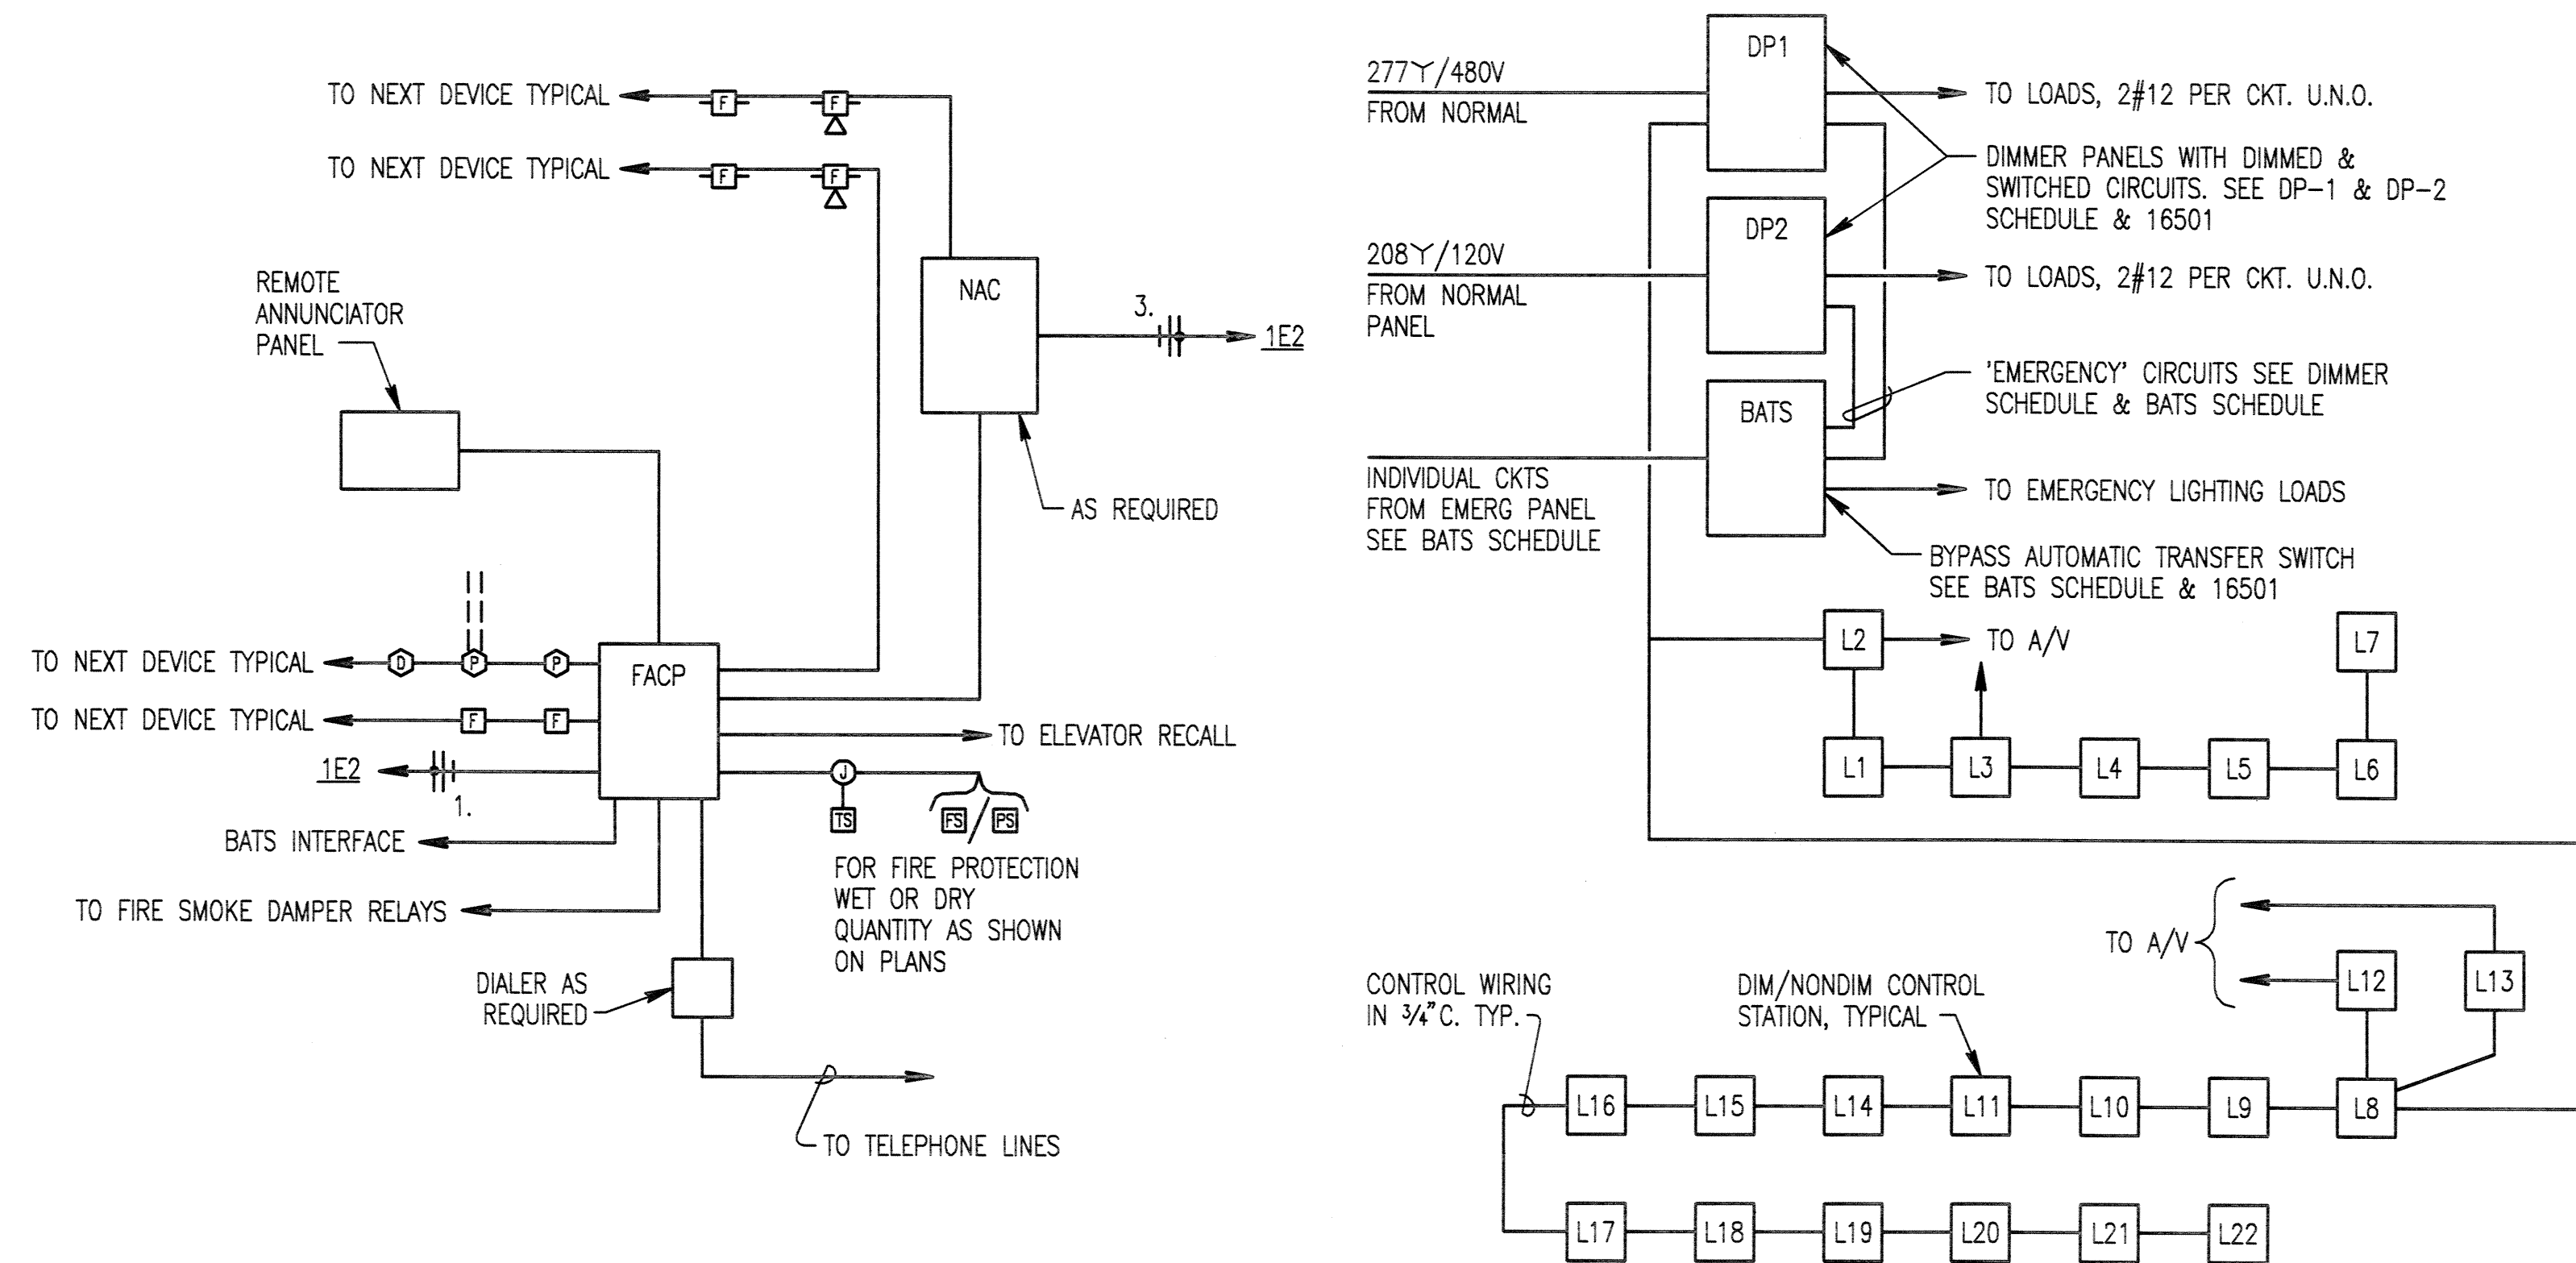

1 FIRE ALARM DIAGRAM
E5.02 SCALE: NONE

2 DIMMING SYSTEM ONE-LINE DIAGRAM
E5.02 SCALE: NONE

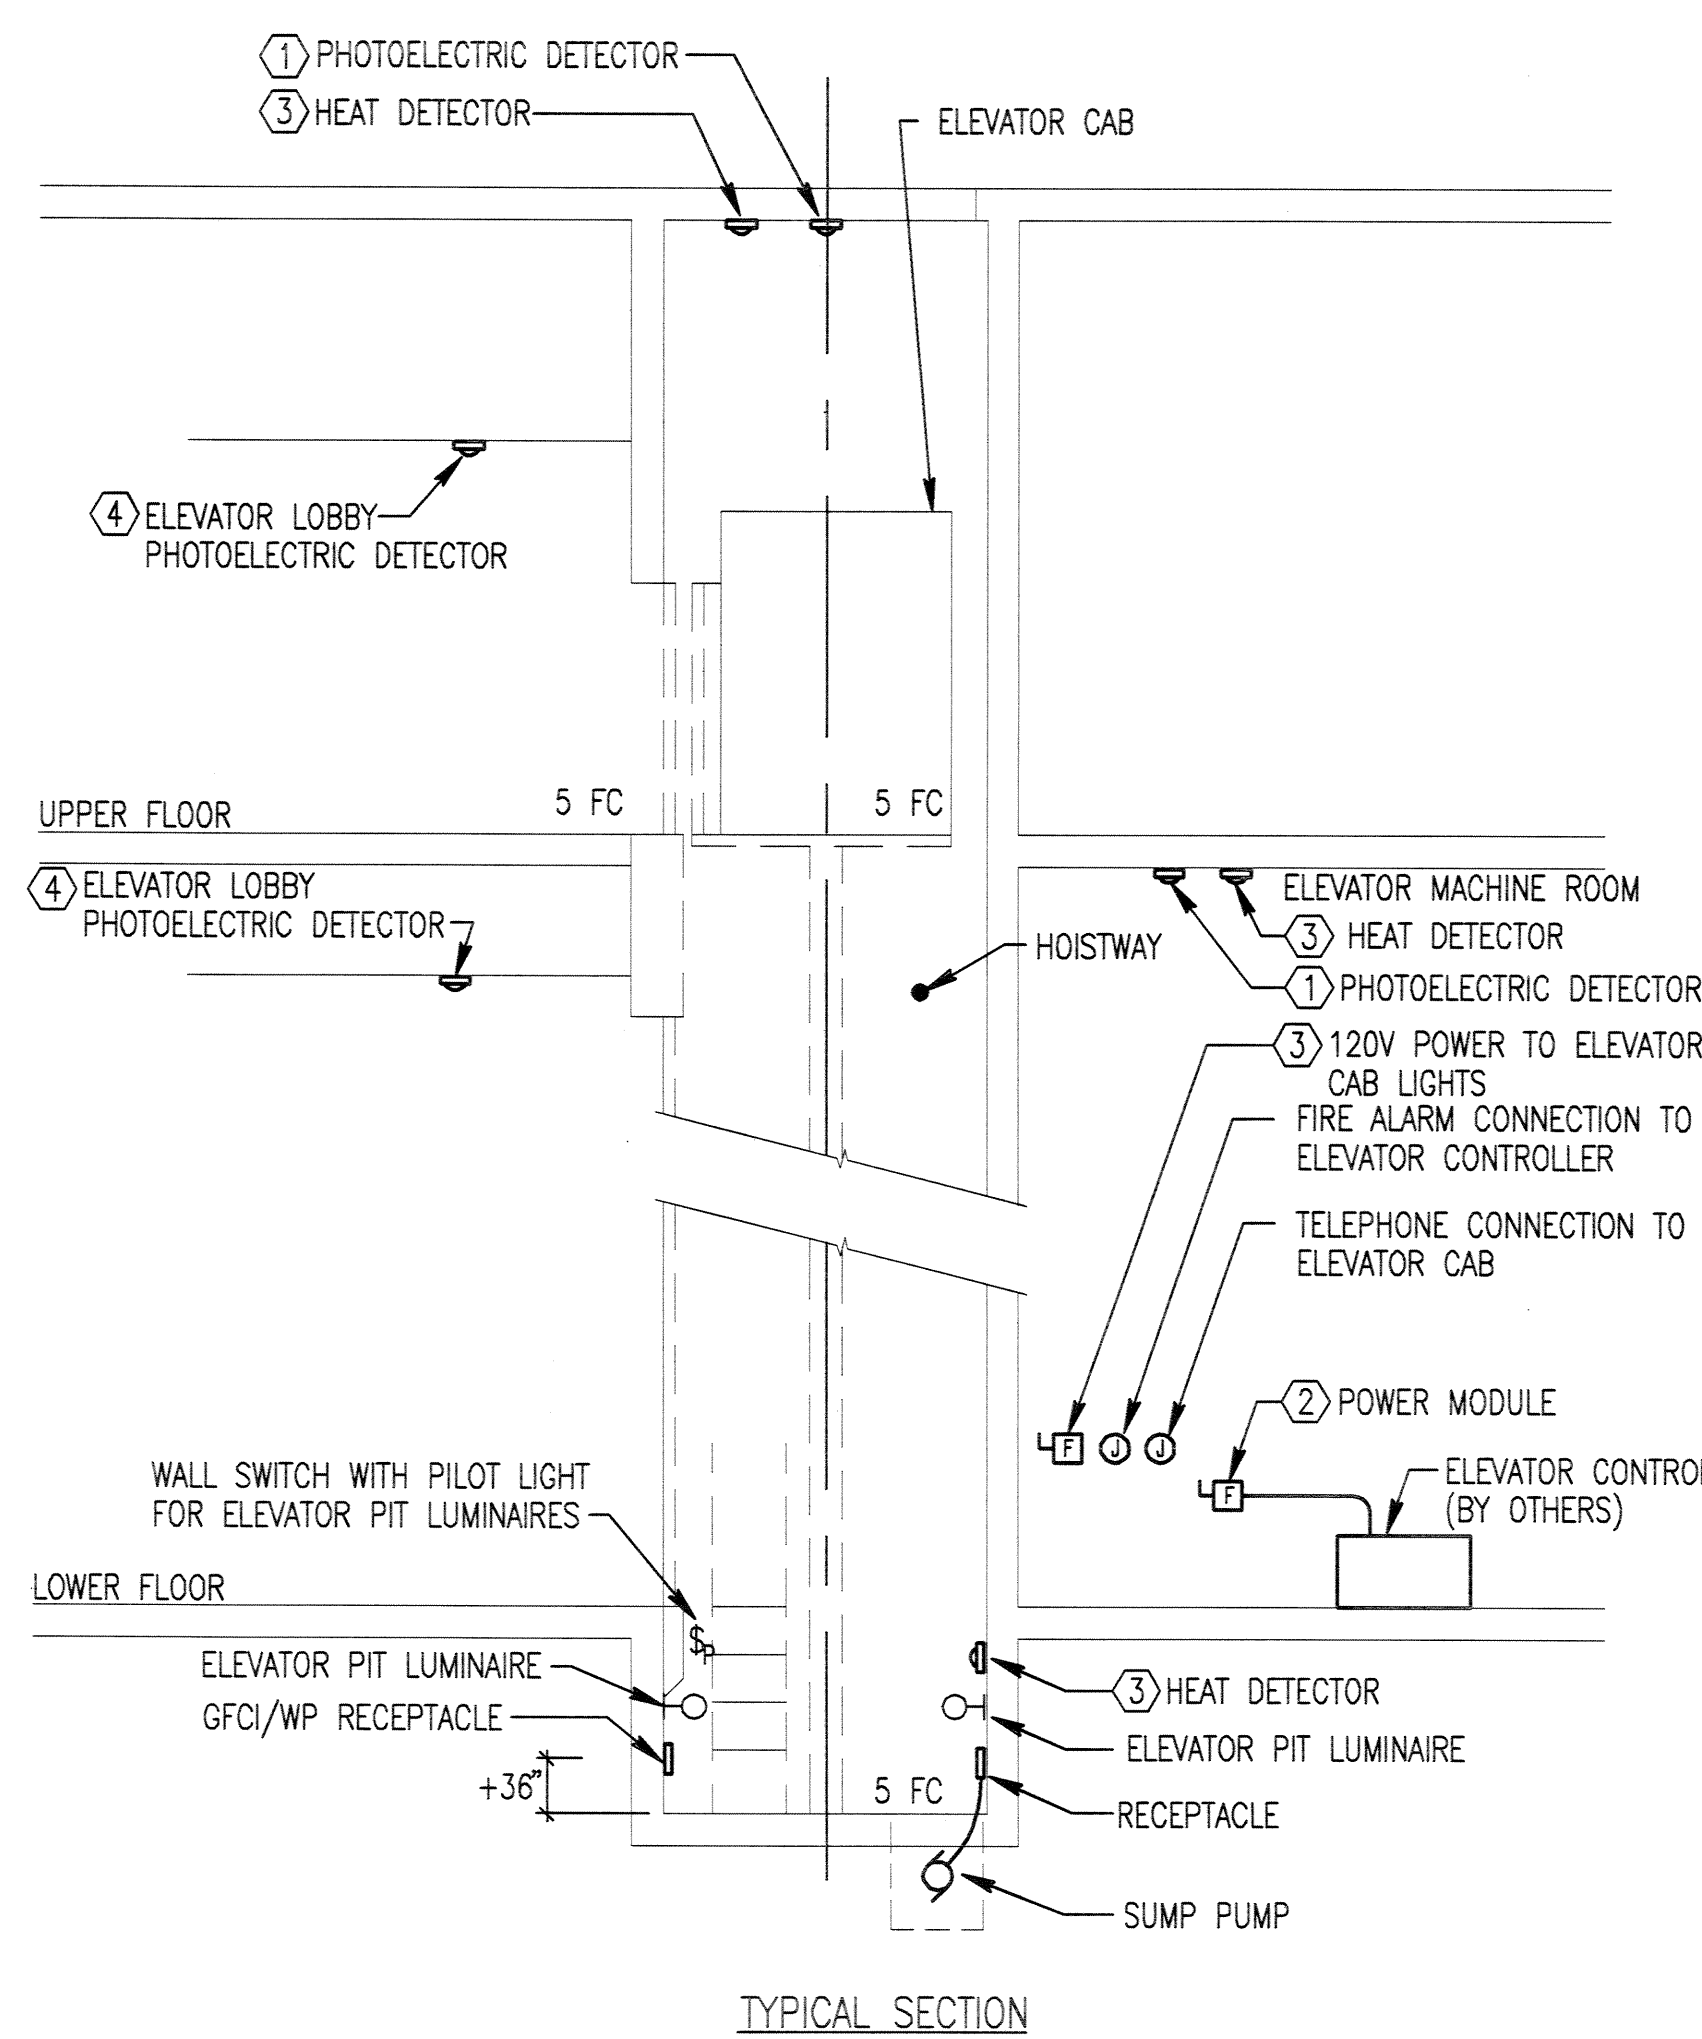


TYPICAL SECTION

GENERAL NOTES:


- PER NEC 620.
a. ELEVATOR MACHINE ROOM LIGHTING AND RECEPTACLE MUST HAVE SEPARATE CIRCUITS.
b. ELEVATOR PIT LIGHTING AND RECEPTACLE MUST HAVE SEPARATE CIRCUITS.
c. ELEVATOR CAB LIGHTING AND HVAC MUST HAVE DISCONNECT MEANS IN THE ELEVATOR MACHINE ROOM.
- NO CONDUIT CAN PASS THROUGH ELEVATOR SHAFT.
- SUMP PUMP CONTROL PANELS CAN NOT BE IN THE ELEVATOR EQUIPMENT ROOM OR ELEVATOR PIT.
- ELEVATOR CODE REQUIRES 5 FOOTCANDELS OF LIGHTING IN ELEVATOR PIT AND 10 FOOTCANDELS OF LIGHTING IN ELEVATOR MACHINE ROOM.

NOTES:


- PROVIDE AUXILIARY CONTACTS IN DETECTOR. CONNECT TO ELEVATOR CONTROLLER FOR ELEVATOR RECALL.
- PROVIDE ELEVATOR POWER MODULE (WITH INTEGRAL SHUNT TRIP). CONNECT SHUNT TRIP CONTROL VIA HEAT DETECTORS' AUXILIARY CONTACTS IN HOISTWAY, EQUIPMENT ROOM AND PIT TO POWER MODULE. POWER SHALL BE AUTOMATICALLY DISCONNECTED UPON INITIATION OF ANY OF THESE HEAT DETECTORS AND PRIOR TO SPRINKLER WATER FLOW.
a. LOCATE WITHIN 24" OF MACHINE ROOM DOOR. NOT REQUIRED TO BE NEMA 3R.
- LOCATE FIXED TYPE HEAT DETECTOR WITHIN 24" OF SPRINKLER HEAD, COORDINATE THE SPRINKLER RESPONSE TIME. PROVIDE AUXILIARY CONTACTS IN DETECTOR. CONNECT TO POWER MODULE IN EQUIPMENT ROOM FOR ELEVATOR POWER SHUTDOWN.
a. ALL THREE DETECTORS (ELEVATOR PIT, EQUIPMENT ROOM AND TOP OF ELEVATOR SHAFT) CAN BE ON THE SAME ZONE TO SHUT DOWN POWER.
b. LOCATE WITHIN 24" OF SPRINKLER HEAD. HEAT DETECTOR FIXED TYPE, COORDINATE WITH SPRINKLER RESPONSE TIME.
- PROVIDE AUXILIARY CONTACTS IN DETECTOR. CONNECT TO ELEVATOR CONTROLLER (FOR RESPECTIVE ELEVATOR DOOR LOCK-OUT).
a. LOCATE DETECTOR IN TYPICAL 4'-6" RADIUS AREA FROM CENTER OF ELEVATOR DOOR.
b. PROVIDE N.O. DRY CONTACT IN ELEVATOR LOBBY DETECTOR TO ACTUATE ELEVATOR SMOKE DOOR. SEE DETAIL 3/EB.1.
- PROVIDE DISCONNECT MEANS FOR ELEVATOR CAB LIGHTING. SEE SPECIFICATIONS.
- IN ELEVATOR PIT WALL, COORDINATE ROUGH-IN WITH GENERAL CONTRACTOR.

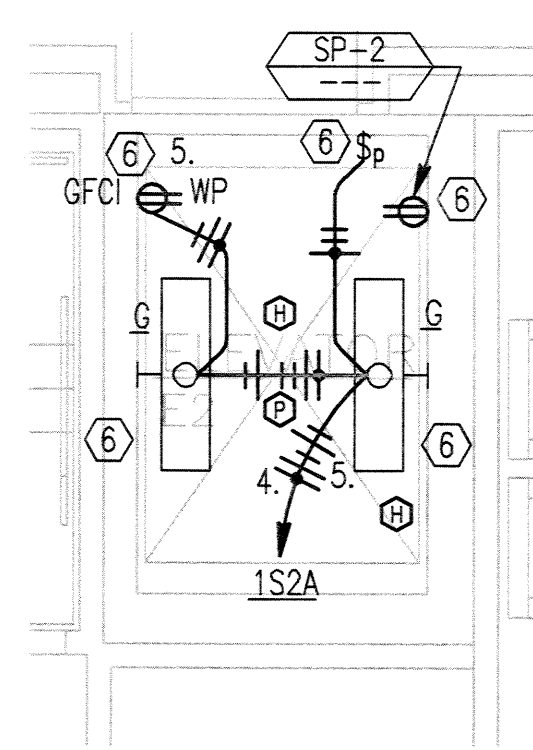


FIRST FLOOR

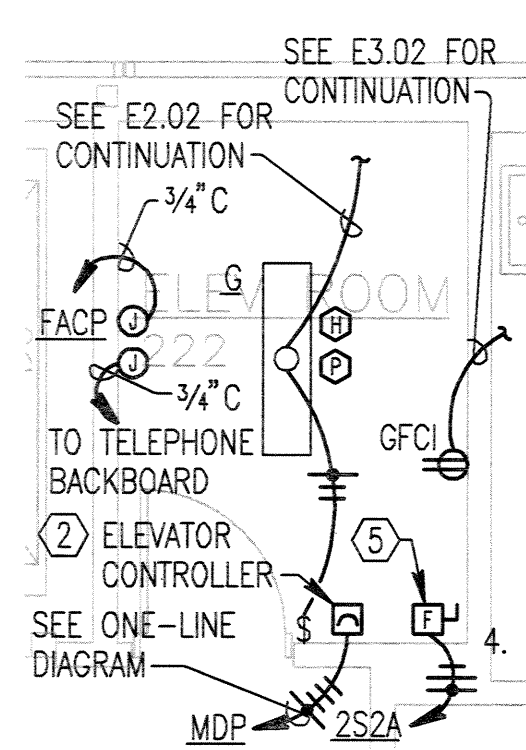

SECOND FLOOR

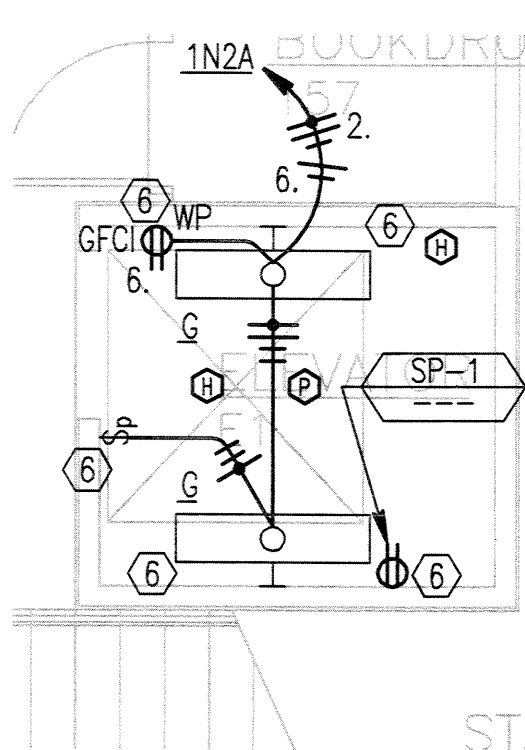


FIRST FLOOR

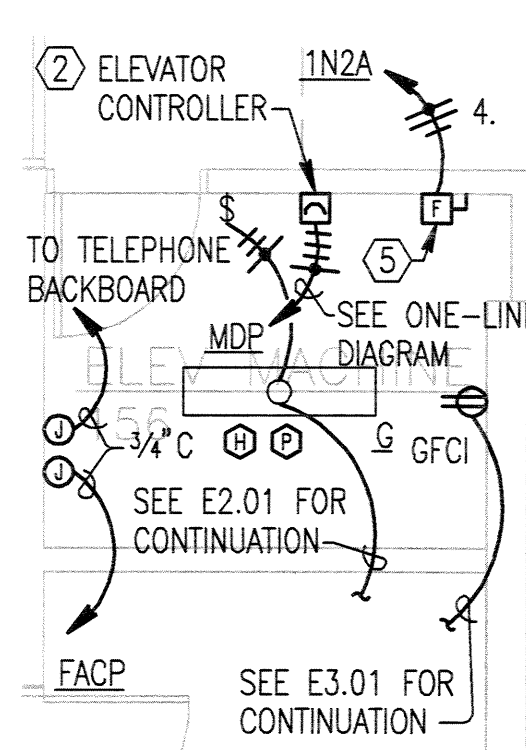


FIRST FLOOR


3 TYPICAL ELEVATOR DETAIL
E5.02 SCALE: NONE

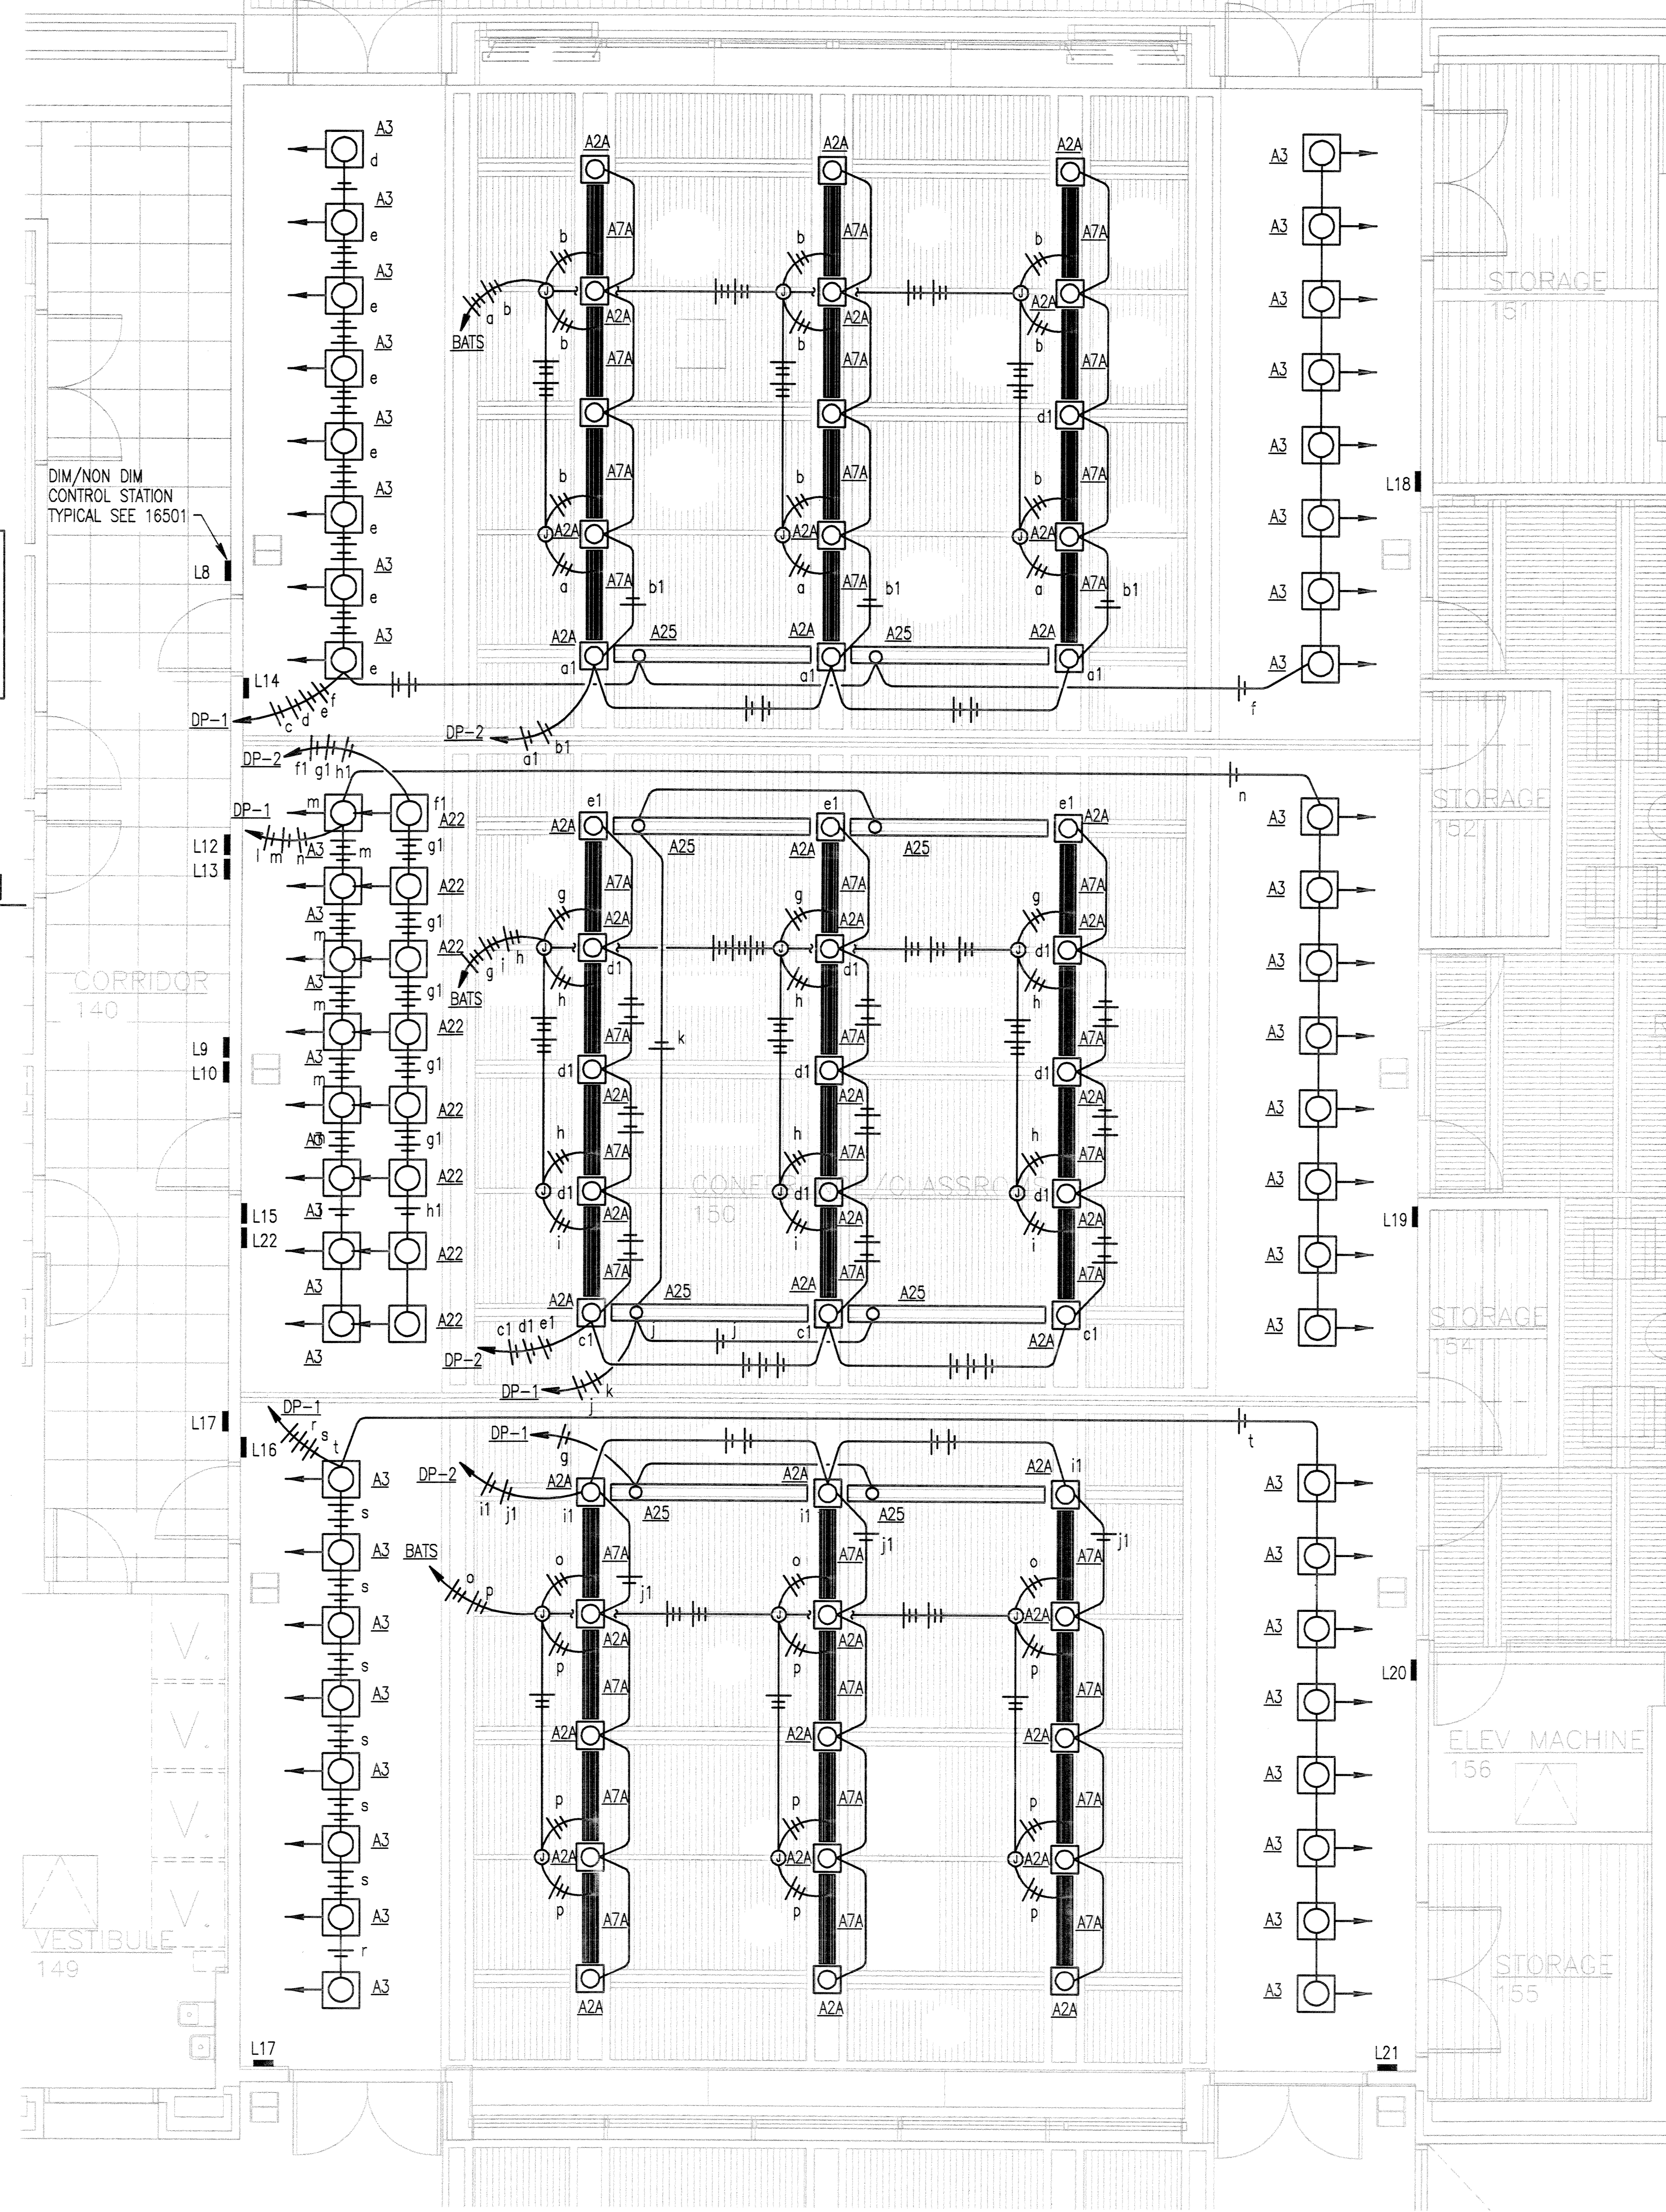

6 ENLARGED LIGHTING PLAN - FIRST FLOOR
E5.02 SCALE: 1/4" = 1'-0"

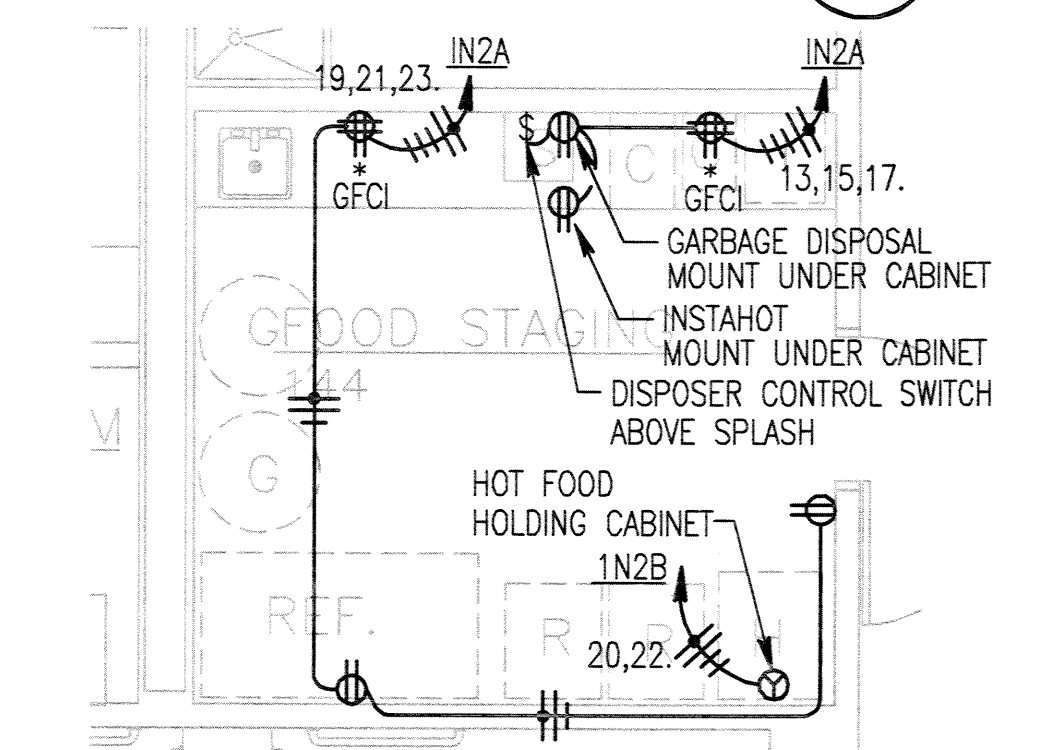

4 KITCHEN ENLARGED PLAN
E5.02 SCALE: 1/4" = 1'-0"

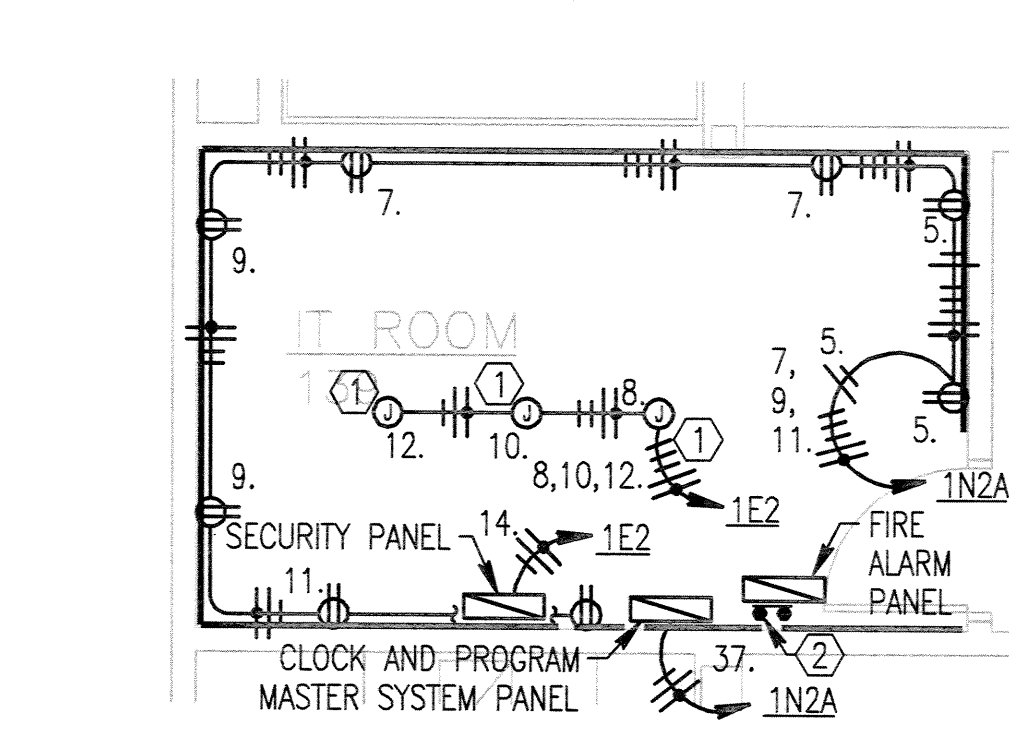

5 IT ENLARGED PLAN
E5.02 SCALE: 1/4" = 1'-0"

NOTES:

- COORDINATE J-BOX LOCATIONS WITH RACKS. COORDINATE QUANTITY AND LOCATION OF RECEPTACLES MOUNTED ON RACKS AS REQUIRED.
- PROVIDE GROUND BUS WITH (1) #4 CU TO MDP GROUND FOR IT CONNECTIONS.

DETAILS & ENLARGED PLANS - ELECTRICAL
PCC ROCK CREEK CAMPUS
NEW BUILDING

PORTLAND COMMUNITY COLLEGE
ROCK CREEK CAMPUS
908 NW Springville Road
PORTLAND, OREGON 97204
503.228.2921

REVISIONS : 03/21/03
DATE : 02/14/03
SCALE : NONE



EXPRES 12-31-04
DRAWN BY : WBD
JOB NO. : 0115
DWS. NO.

THOMAS HACKER
ARCHITECTS INC.



E5.02

PANEL LOCATION: MDP ELECTRICAL ROOM 130 FED FROM: MDP BUS	DC DEVICE TYPE: Breaker DEVICE FAMILY: Bolt On	ENCLOSURE: MOUNTING: VOLTAGE: 480/277	NEMA 1 Free Standing	MAINS(A): 1600A MCB WIRING: 3-Phase 4-Wire	BUS RATING(A): 1600 WITHSTAND(A): 65000 FAULT CURRENT(A): 30995		
CUBICLE NO	DESCRIPTION	CONNECTED KVA	DEMAND KVA	DESIGN KVA	DESIGN AMPS	DC DEVICE TRIP SIZE	NOTES
1	PANEL 254M	184.41	184.41	184.41	221.81	400	
2	PANEL 154	61.37	61.37	67.80	81.35	200	
3	PANEL 1N4	29.41	29.41	36.77	44.22	200	
4	T-S PRI BUS	120.41	76.15	76.98	92.59	175	
5	T-N PRI BUS	86.91	70.51	74.42	89.51	175	
6	ECC-1	362.31	362.31	362.31	435.79	500	
7	ELEVATOR #1	34.97	34.97	43.71	52.98	70	
8	ELEVATOR #2	34.97	34.97	43.71	52.98	70	
9	ATS NORM BUS	30.26	30.26	33.99	40.88	150	
10	SPARE	0.00	0.00	0.00	0.00	100	
11							
12							
13							
14							
ALL CONNECTED	KVA	AMPS	* PHASE TOTALS		VA	AMPS	BUS TOTALS
TOTAL CONNECTED	941.36	1132.3	* A-N		313788.1	1132.3	CONNECTED
TOTAL DEMAND	875.78	1053.4	* B-N		313788.1	1132.3	DEMAND
TOTAL DESIGN	905.89	1089.6	* C-N		313788.1	1132.3	DESIGN

PANEL LOCATION: SDP-S ELECTRICAL ROOM 130 FED FROM: T-S SEC FEED		DC DEVICE TYPE: Breaker DEVICE FAMILY: Bolt On		ENCLOSURE: MOUNTING: VOLTAGE: 208/120		NEMA 1 Surface 208/120		MAINS(A): 400A MCB WIRING: 3-Phase 4-Wire		BUS RATING(A): 400 WITHSTAND(A): 10000 FAULT CURRENT(A): 6199	
CUBICLE NO	DESCRIPTION	CONNECTED KVA	DEMAND KVA	DESIGN KVA	DESIGN AMPS	DC DEVICE TRIP SIZE	NOTES				
1	PANEL 132A	52.93	38.24	38.45	106.72	200					
2	PANEL 132B	19.52	14.76	14.76	40.97	200					
3	PANEL 132C	24.97	21.66	22.28	61.85	200					
4	SPARE	0.00	0.00	0.00	0.00	0					
5											
6											
7											
ALL CONNECTED KVA		AMPS	* PHASE TOTALS		VA	AMPS	BUS TOTALS		KVA		
TOTAL CONNECTED 97.39		270.3	* A-N		32463.4	270.3	CONNECTED		120.41		
TOTAL DEMAND 64.64		179.4	* B-N		32463.4	270.3	DEMAND		76.15		
TOTAL DESIGN 65.47		181.7	* C-N		32463.4	270.3	DESIGN		76.98		

PANEL LOCATION: FED FROM:		SDP-N ELECTRICAL ROOM 132 T-N SEC BUS	DC DEVICE TYPE: DEVICE FAMILY:	Breaker Bolt On	ENCLOSURE: MOUNTING: VOLTAGE:	NEMA 1 Surface 208/120	MAINS(A): WIRING:	400A MCB 3-Phase 4-Wire	BUS RATING(A): WITHSTAND(A): FAULT CURRENT(A):	400 10000 5391
CUBICLE NO	DESCRIPTION	CONNECTED kVA	DEMAND kVA	DESIGN kVA	DESIGN AMPS	DC DEVICE TRIP SIZE	NOTES			
1	PANEL 1N2A	47.23	31.55	31.76	88.16	200				
2	PANEL 1N2B	25.32	25.32	25.68	71.29	200				
3	PANEL 1N2C	14.72	14.72	18.12	50.30	200				
4	SPARE	0.00	0.00	0.00	0.00	0				
5										
6										
7										
ALL CONNECTED		kVA	AMPS	* PHASE TOTALS		VA	AMPS	BUS TOTALS		kVA
TOTAL CONNECTED		86.91	241.2	* A-N		28969.7	241.2	CONNECTED		86.91
TOTAL DEMAND		70.51	195.7	* B-N		28969.7	241.2	DEMAND		70.51
TOTAL DESIGN		74.42	206.6	* C-N		28969.7	241.2	DESIGN		74.42

PANEL LOCATION: 1E4 ELECTRICAL ROOM 130 FED FROM: ATS OUT FEED		DC DEVICE TYPE: Breaker DEVICE FAMILY: Bolt On		ENCLOSURE: NEMA 1 MOUNTING: Surface VOLTAGE: 480/277		MAINS(A): 150A MLD WIRING: 3-Phase 4-Wire		BUS RATING(A): 225 WITHSTAND(A): 25000 FAULT CURRENT(A): 24314				
CKT	DESCRIPTION	NOTES	DEMAND CODE	VA	DC AMPS P	PHASE	DC AMPS P	VA	DEMAND CODE	NOTES	DESCRIPTION	CKT
1	EGRESS SOUTH 1ST		Elghting	2331	20	A	20	3024	Elghting		DIMMER a,b,g,h,i,o,p	2
2	EGRESS SOUTH 1ST		Elghting	2604	20	B	20	2400	Elghting		DIMMER dd	4
3	EGRESS 2ND		Elghting	1948	20	C	20	0	SPARE			6
4	EGRESS 2ND		Elghting	2724	20	A	20	0	SPARE			8
5	SPARE		SPARE	0	20	B	20	0	SPARE			10
6	SPARE		SPARE	0	20	C	20	0	SPARE			12
7						A						14
8						B						16
9						C						18
10						A						20
11						B						22
12						C						24
13						A						26
14						B						28
15						C						30
16						A						32
17						B						34
18						C						36
19						A						38
20						B						40
21						C						42
22						A						44
23						B						46
24						C						48
25						A						50
26						B						52
27						C						54
28						A						56
29						B						58
30						C						60
ALL CONNECTED		KVA	AMPS	* PHASE TOTALS		VA	AMPS	BUS TOTALS		KVA		
TOTAL CONNECTED		30.26	36.4	* A-N		12134.2	47.4	CONNECTED		30.26		
TOTAL DEMAND		30.26	36.4	* B-N		10800.8	36.4	DEMAND		30.26		
TOTAL DESIGN		33.99	40.9	* C-N		7064.8	25.5	DESIGN		33.99		

PANEL LOCATION: 154 FED FROM: MDP BUS	ELECTRICAL ROOM 130	DC DEVICE TYPE: Breaker DEVICE FAMILY: Bolt On	ENCLOSURE: MOUNTING: VOLTAGE: 480/277	NEMA 1 Surface	MAINS(A): 225A MLD WIRING: 3-Phase 4-Wire	BUS RATING(A): 225 WITHSTAND(A): 45000 FAULT CURRENT(A): 38876						
CKT	DESCRIPTION	NOTES	DEMAND CODE	VA	DC AMPS P	PHASE	DC AMPS P	VA	DEMAND CODE	NOTES	DESCRIPTION	CKT
1	SOUTH	Nlghting	2412	20	1	A	20	3900	HVAC Systems		CHMP-3	2
2	SOUTH	Nlghting	2840	20	1	B	20	3900				4
3	SOUTH	Nlghting	1434	20	1	C	20	3900				6
4	SPARE	SPARE	0	20	1	A	20	3900	HVAC Systems		CHMP-4	8
5	CHMP-2	HVAC Systems	2107	20	3	A	20	3900				10
6	CHMP-2	HVAC Systems	2107	20	3	B	20	3900				12
7	CHMP-2	HVAC Systems	2107	20	3	C	20	3900				14
8	CHMP-1	HVAC Systems	2107	20	3	A	20	1200	Nlghting		SOUTH EAST	16
9	CHMP-1	HVAC Systems	2107	20	3	B	20	1200	Nlghting		SOUTH EAST	18
10	CHMP-1	HVAC Systems	2107	20	3	C	20	0	SPARE		SPARE	20
11	SPARE	SPARE	0	20	1	A	20					22
12	SPARE	SPARE	0	20	1	B	20					24
13	SPARE	SPARE	0	20	1	C	20					26
14	SPARE	SPARE	0	20	1	A	20					28
15	SPARE	SPARE	0	20	1	B	20					30
16	SPARE	SPARE	0	20	1	C	20					32
17	SPARE	SPARE	0	20	1	A	20					34
18	SPARE	SPARE	0	20	1	B	20					36
19	SPARE	SPARE	0	20	1	C	20					38
20	SPARE	SPARE	0	20	1	A	20					40
21	SPARE	SPARE	0	20	1	B	20					42
22	SPARE	SPARE	0	20	1	C	20					44
23	SPARE	SPARE	0	20	1	A	20					46
24	SPARE	SPARE	0	20	1	B	20					48
25	SPARE	SPARE	0	20	1	C	20					50
26	SPARE	SPARE	0	20	1	A	20					52
27	SPARE	SPARE	0	20	1	B	20					54
28	SPARE	SPARE	0	20	1	C	20					56
29	SPARE	SPARE	0	20	1	A	20					58
30	SPARE	SPARE	0	20	1	B	20					60
ALL CONNECTED												
TOTAL CONNECTED												
TOTAL DEMAND												
TOTAL DESIGN												
KVA												
AMPS												
* PHASE TOTALS												
VA												
AMPS												
BUS TOTALS												
KVA												
CONNECTED												
DESIGN												
DEMAND												
61.37												
61.37												
67.80												

PANEL:	1N4	DC DEVICE TYPE:	Breaker	ENCLOSURE:	NEMA 1	MAINS(A):	100A MLD	BUS RATING(A):	100			
LOCATION:	ELECTRICAL ROOM 142	DEVICE FAMILY:	Bolt On	MOUNTING:	Surface	WIRING:	3-Phase 4-Wire	WITHSTAND(A):	14000			
FED FROM:	MDP BUS			VOLTAGE:	480/277			FAULT CURRENT(A):	10227			
CKT	DESCRIPTION	NOTES	DEMAND CODE	VA	DC AMPS P	PHASE	DC AMPS P	VA	DEMAND CODE	NOTES	DESCRIPTION	CKT
1	BOOKSTORE	Nlghting	2400	20	1	A	20	2866	Nlghting		NORTH 1ST FLOOR	2
2	BOOKSTORE	Nlghting	1960	20	1	B	20	2488	Nlghting		NORTH 1ST FLOOR	4
3	EXTERIOR	Nlghting	844	20	1	C	20	1764	Nlghting		NORTH 1ST FLOOR	6
4	INVERTER	Nlghting	10000	45	1	A	20	3372	Nlghting		SOUTH 1ST FLOOR	8
5	SPARE	SPARE	0	20	1	B	20	0	SPARE		SPARE	10
6	SPARE	SPARE	0	20	1	C	20	0	SPARE		SPARE	12
7						A						14
8						B						16
9						C						18
10						A						20
11						B						22
12						C						24
13						A						26
14						B						28
15						C						30
16						A						32
17						B						34
18						C						36
19						A						38
20						B						40
21						C						42
22						A						44
23						B						46
24						C						48
25						A						50
26						B						52
27						C						54
28						A						56
29						B						58
30						C						60
31						A						62
32						B						64
33						C						66
34						A						68
35						B						70
36						C						72
37						A						74
38						B						76
39						C						78
40						A						80
41						B						82
42						C						84
43						A						86
44						B						88
45						C						90
46						A						92
47						B						94
48						C						96
49						A						98
50						B						100
51						C						102
52						A						104
53						B						106
54						C						108
55						A						110
56						B						112
57						C						114
58						A						116
59						B						118
60						C						120
61						A						122
62						B						124
63						C						126
64						A						128
65						B						130
66						C						132
67						A						134
68						B						136
69						C						138
70						A						140
71						B						142
72						C						144
73						A						146
74						B						148
75						C						150
76						A						152
77						B						154
78						C						156
79						A						158
80						B						160
81						C						162
82						A						164
83						B						166
84						C						168
85						A						170
86						B						172
87						C						174
88						A						176
89						B						178
90						C						180
91						A						182
92						B						184
93						C						186
94						A						188
95						B						190
96						C						192
97						A						194
98						B						196
99						C						198
100						A						200
101						B						202
102						C						204
103						A						206
104						B						208
105						C						210
106						A						212
107						B						214
108						C						216
109						A						218
110						B						220
111						C						222
112						A						224
113						B						226
114						C						228
115						A						230
116						B						232
117						C						234
118						A						236
119						B						238
120						C						240
121						A						242
122						B						244
123						C						246
124						A						248
125						B						250
126						C						252
127						A						254
128						B						256
129						C						258
130						A						260
131						B						262
132						C						264
133						A						266
134						B						268
135						C						270
136						A						272
137						B						274
138						C						276
139						A						278
140						B						280
141						C						282
142						A						284
143						B						286
144						C						288
145						A						290
146						B						292
147						C						294
148						A						296
149						B						298
150						C						300
151						A						302
152						B						304
153						C						306
154						A						308
155						B						310
156						C						312
157						A						314
158						B						316
159						C						318
160						A						320
161						B						322
162						C						324
163						A						326
164						B						328
165						C						330
166						A						332
167						B						334
168						C						336
169						A						338
170						B						340
171						C						342
172						A						344
173						B						346
174						C						348
175						A						350
176						B						352
177						C						354
178						A						356
179						B						358
180						C						360
181						A						362
182						B						364
183						C						366
184						A						368
185						B						

PANEL: 225A LOCATION: ELEC. CLOSET 226 FED FROM: PANEL 1S2A		DC DEVICE TYPE: Breaker DEVICE FAMILY: Bolt On		ENCLOSURE: NEMA 1 MOUNTING: Surface VOLTAGE: 208/120		MAINS(A): 225A MLD WIRING: 3-Phase 4-Wire		BUS RATING(A): WITHSTAND(A): FAULT CURRENT(A)		225 10000 4705		
CKT	DESCRIPTION	NOTES	DEMAND CODE	VA	DC AMPS P	PHASE	DC AMPS P	VA	DEMAND CODE	NOTES	DESCRIPTION	CKT
1	B-1		NEquipment	2400	30 1	A	20 1	700	NEquipment		EF-2	2
2	B-2		NEquipment	2400	30 1	B	20 1	500	NLighting		ELEVATOR CAB	4
3	B-3		NEquipment	2400	30 1	C	20 1	720	NEquipment		CIRCULATION DESK	6
7	RM 225		NReceptacles	720	20 1	A	20 1	540	NReceptacles		RM 230	8
9	RM 224, 225		NReceptacles	720	20 1	B	20 1	540	NReceptacles		MAIL RM 221	10
11	RM 223		NReceptacles	540	20 1	C	20 1	720	NReceptacles		RM 223	12
13	MAIL RM 221		NReceptacles	720	20 1	A	20 1	720	NReceptacles		RM 219	14
15	RM 219		NReceptacles	720	20 1	B	20 1	720	NReceptacles		RM 219	16
17	RM 219		NReceptacles	720	20 1	C	20 1	720	NReceptacles		RM 230	18
19	RM 229		NReceptacles	720	20 1	A	20 1	720	NReceptacles		RM 228	20
21	RM 227, 229, 230		NReceptacles	720	20 1	B	20 1	900	NReceptacles		RM 227	22
23	RM 229		NReceptacles	540	20 1	C	20 1	500	NReceptacles		GARAGE DIS. 227	24
25	RM 216, 219		NReceptacles	720	20 1	A	20 1	900	NReceptacles		A/V DESK, RM 227	26
27	RM 218, 219		NReceptacles	900	20 1	B	20 1	0	SPARE		SPARE	28
29	RM 217, 218		NReceptacles	900	20 1	C	20 1	0	SPARE		SPARE	30
31	RM 223 PARTITION		NReceptacles	720	20 1	A	20 1	720	NReceptacles		RM 217	32
33	RM 223 PARTITION		NReceptacles	720	20 1	B	20 1	720	NReceptacles		RM 214, 216	34
35	RM 214, 215		NReceptacles	1080	20 1	C	20 1	720	NReceptacles		PERIODICAL RM 214	36
37	SPARE		SPARE	0	20 1	A	20 1	0	SPARE		SPARE	38
39	SPARE		SPARE	0	20 1	B	20 1	0	SPARE		SPARE	40
41	SPARE		SPARE	0	20 1	C	20 1	0	SPARE		SPARE	42
ALL CONNECTED KVA AMPS * PHASE TOTALS VA AMPS BUS TOTALS KVA												
TOTAL CONNECTED		29.38	81.6	* A-N	10291.5			85.7	7	CONNECTED	29.38	
TOTAL DEMAND		23.87	66.3	* B-N	9537.0			79.4	7	DEMAND	23.87	
TOTAL DESIGN		23.99	66.6	* C-N	9552.9			79.5	7	DESIGN	23.99	

PANEL: 1N2A LOCATION: ELECTRICAL ROOM 132 FED FROM: PANEL SDP-N		DC DEVICE TYPE: Breaker DEVICE FAMILY: Bolt On		ENCLOSURE: NEMA 1 MOUNTING: Surface VOLTAGE: 208/120		MAINS(A): 225A MLD WIRING: 3-Phase 4-Wire		BUS RATING(A): WITHSTAND(A): FAULT CURRENT(A)		225 10000 5102	
CKT	DESCRIPTION	NOTES	DEMAND CODE	VA	DC AMPS P	PHASE	DC AMPS P	VA	DEMAND CODE	NOTES	DESCRIPTION
1	CUH-1		Electric Hea	250	20	A	20	1	360	NLighting	ELEVATOR 1 PIT
3	UH-1		Electric Hea	520	20	A	20	1	500	NLighting	ELEVATOR CAB
5	IT ROOM 139		NReceptacles	360	20	C	20	1	180	NReceptacles	ELEVATOR 1 PIT
7	IT ROOM 139		NReceptacles	360	20	A	20	1	0	SPARE	SPARE
9	IT ROOM 139		NReceptacles	360	20	B	20	1	0	SPARE	SPARE
11	IT ROOM 139		NReceptacles	360	20	C	20	1	0	SPARE	SPARE
13	STORAGE 138		NReceptacles	360	20	A	20	1	540	NReceptacles	RM 142, 146
15	CORR 140		NReceptacles	360	20	B	20	1	1000	NReceptacles	GARAGE DIS./INSTA
17	DISPLAY WINDOW		NReceptacles	360	20	C	20	1	540	NReceptacles	RM 144
19	DISPLAY WINDOW		NReceptacles	360	20	A	20	1	720	NReceptacles	RM 153, 155
21	SPARE		SPARE	0	20	B	20	1	720	NReceptacles	RECEPTION HALL, 153
23	SPARE		SPARE	0	20	C	20	1	180	NReceptacles	ELEVATOR MACHINE RM
25	MEN S 148		NReceptacles	360	20	A	20	1	720	NReceptacles	RM 155, 136
27	WOMEN S 147		NReceptacles	360	20	B	20	1	720	NReceptacles	RM 155, 136
29	CLOCK PROG.		NEquipment	300	20	C	20	1	720	NReceptacles	CASH REG. 136
31	CLOSET RM 135		NReceptacles	1000	20	A	20	1	720	NReceptacles	OFFICE 143
33	RM 135		NReceptacles	540	20	B	20	1	720	NReceptacles	OFFICE 143
35	RM 136		NReceptacles	540	20	C	20	1	360	NReceptacles	CASH REG 145
37	SPARE		SPARE	0	20	A	20	1	0	SPARE	SPARE
39	SPARE		SPARE	0	20	B	20	1	0	SPARE	SPARE
41	SPARE		SPARE	0	20	C	20	1	0	SPARE	SPARE
ALL CONNECTED		KVA	AMPS	* PHASE TOTALS		VA	AMPS	BUS TOTALS		KVA	
TOTAL CONNECTED		15.39	43.3	* A-N		5726.9	47.7	9		CONNECTED	47.23
TOTAL DEMAND		13.83	38.4	* B-N		5770.9	48.1	9		DEMAND	31.55
TOTAL DESIGN		14.04	39.0	* C-N		4098.3	34.1	9		DESIGN	31.76

FEED THRU LUGS

PANEL: 2N2A LOCATION: MECHANICAL ROOM 234 FED FROM: PANEL 1N2A	DC DEVICE TYPE: Breaker DEVICE FAMILY: Bolt On	ENCLOSURE: NEMA 1 MOUNTING: Surface VOLTAGE: 208/120	MAINS(A): 225A MLD WIRING: 3-Phase 4-Wire	BUS RATING(A): WITHSTAND(A): FAULT CURRENT(A)	225 10000 3949					
CKT DESCRIPTION	NOTES	DEMAND CODE	VA	DC AMPS P	PHASE	DC AMPS P	VA	DEMAND CODE	NOTES	DESCRIPTION
1 HWP-7		HVAC Systems	420	20 1	A	20 3	793			HVAC Systems
3 HWP-8		HVAC Systems	420	20 1	B	**	793			HVAC Systems
5 PROJECTOR 235		NEquipment	500	20 1	C	**	793			HVAC Systems
7 RM 206,209		NReceptacles	720	20 1	A	20 1	1620			NReceptacles
9 RM 206,207,208		NReceptacles	720	20 1	B	20 1	1620			NReceptacles
11 RM 204,205,206		NReceptacles	720	20 1	C	20 1	1620			NReceptacles
13 RM 202		NReceptacles	720	20 1	A	20 1	720			NReceptacles
15 RM 203,204		NReceptacles	900	20 1	B	20 1	720			NReceptacles
17 READING RM 201		NReceptacles	720	20 1	C	20 1	900			NReceptacles
19 RM 235		NReceptacles	360	20 1	A	20 1	0			SPARE
21 RM 235		NReceptacles	360	20 1	B	20 1	540			NReceptacles
23 RM 235		NReceptacles	360	20 1	C	20 1	360			NReceptacles
25 AHU-2		NReceptacles	360	20 1	A	20 1	1260			NReceptacles
27 AHU-3		NReceptacles	360	20 1	B	20 1	1650			NReceptacles
29 FLOOR BOX CONTROL		NEquipment	100	20 1	C	20 1	1650			NReceptacles
31 READING RM 201		NReceptacles	1620	20 1	A	20 1	1650			NReceptacles
33 READING RM 201		NReceptacles	1620	20 1	B	20 1	1650			NReceptacles
35 READING RM 201		NReceptacles	1620	20 1	C	20 1	1080			NReceptacles
37 SPARE		SPARE	0	20 1	A	20 1	0			SPARE
39 SPARE		SPARE	0	20 1	B	20 1	0			SPARE
41 SPARE		SPARE	0	20 1	C	20 1	0			SPARE
ALL CONNECTED KVA AMPS * PHASE TOTALS VA AMPS BUS TOTALS KVA										
TOTAL CONNECTED			31.65	87.8	* A-N	9879.1	82.3	3	CONNECTED	31.65
TOTAL DEMAND			22.73	63.1	* B-N	11349.1	94.5	3	DEMAND	22.73
TOTAL DESIGN			22.73	63.1	* C-N	10418.6	86.8	3	DESIGN	22.73

PANEL: 222C LOCATION: ELEC. CLOSET 226 FED FROM: PANEL 1S2C	DC DEVICE TYPE: Breaker DEVICE FAMILY: Bolt On	ENCLOSURE: NEMA 1 MOUNTING: Surface VOLTAGE: 208/120	MAINS(A): 225A MLD WIRING: 3-Phase 4-Wire	BUS RATING(A): WITHSTAND(A): FAULT CURRENT(A)	225 10000 4705						
CKT	DESCRIPTION	NOTES	DEMAND CODE	VA DC AMPS P	PHASE	DC AMPS P	VA DC AMPS P	DEMAND CODE	NOTES	DESCRIPTION	CKT
1	DL TRACK	NLighting	1800	20 1	A	20 1	720	NReceptacles		IT ROOM 228	2
3	AHU-1 LTG	NLighting	750	20 1	B	20 1	720	NReceptacles		IT ROOM 228	4
5	AHU-1	NReceptacles	360	20 1	C	20 1	720	NReceptacles		IT ROOM 228	6
7	GAH-1	NEquipment	360	20 1	A	20 1	180	NReceptacles		LABORATORY MACHINE RM	8
9	GAH-1	NEquipment	360	20 1	B	20 1	720	NReceptacles		STAFF 227	10
11	SPARE	SPARE	0	20 1	C	20 1	500	NReceptacles		ELEVATOR DIS. 227	12
13	PERIODICAL RM 214	NReceptacles	1080	20 1	A	20 1	720	NReceptacles		RM 213	14
15	COPIER RM 212	Copiers	1000	20 1	B	20 1	720	NReceptacles		COPY RM 212, RM 213	16
17	COPIER RM 212	Copiers	1000	20 1	C	20 1	720	NReceptacles		COPY RM 212, STAIR 18	18
19	COMPUTER WORKRM	NReceptacles	720	20 1	A	20 1	0	SPARE		SPARE	20
21	COMPUTER WORKRM	NReceptacles	720	20 1	B	20 1	0	SPARE		SPARE	22
23	SPARE	SPARE	0	20 1	C	20 1	0	SPARE		SPARE	24
25					A						26
27					B						28
29					C						30
31					A						32
33					B						34
35					C						36
37					A						38
39					B						40
41					C						42
ALL CONNECTED KVA AMPS * PHASE TOTALS VA AMPS BUS TOTALS KVA											
TOTAL CONNECTED			13.78	38.3	* A-N	5542.1	46.1	3	CONNECTED	13.78	
TOTAL DEMAND			13.78	38.3	* B-N	4964.0	41.3	3	DEMAND	13.78	
TOTAL DESIGN			14.41	40.0	* C-N	3286.0	27.4	3	DESIGN	14.41	

PANEL: 1N2B LOCATION: ELECTRICAL ROOM 132 FED FROM: PANEL SDP-N		DC DEVICE TYPE: Breaker DEVICE FAMILY: Bolt On		ENCLOSURE: NEMA 1 MOUNTING: Surface VOLTAGE: 208/120		MAINS(A): 225A MLD WIRING: 3-Phase 4-Wire		BUS RATING(A): WITHSTAND(A): FAULT CURRENT(A)		225 10000 5102		
CKT	DESCRIPTION	NOTES	DEMAND CODE	VA	DC AMPS P	PHASE	DC AMPS P	VA	DEMAND CODE	NOTES	DESCRIPTION	CKT
1	DRAPERY MOTOR 155	NEquipment	500	20 1	A	20 1	500	NEquipment			COFFEE MAKER	2
3	RECEPTION HALL 153	NEquipment	720	20 1	B	20 1	500	NEquipment			REFRIGERATOR	4
5	RECEPTION HALL 153	NEquipment	540	20 1	C	20 1	1500	NEquipment			MICROWAVE	6
7	DRAPERY MOTOR 138	NEquipment	500	20 1	A	20 1	500	NEquipment			MOTORIZED DOOR 149	8
9	MOTORIZED DOOR 101	NEquipment	500	20 1	B	20 1	500	NEquipment			MOTORIZED DOOR 147	10
11	MOTORIZED DOOR 101	NEquipment	500	20 1	C	20 1	500	NEquipment			VENDING MACH 149	12
13	INSTA-HOT	NEquipment	1000	20 1	A	20 1	500	NEquipment			VENDING MACH 149	14
15	GARAGE DIS.	NEquipment	1000	20 1	B	20 1	500	NEquipment			VENDING MACH 149	16
17	COFFEE MACH	NEquipment	1000	20 1	C	20 1	500	NEquipment			VENDING MACH 149	18
19	KITCHEN MISC.	NEquipment	500	20 1	A	40 2	3000	NEquipment			HOT FOOD HOLDING	20
21	REFRIGERATOR	NEquipment	500	20 1	B	**	3000	NEquipment			SECURITY GATE	22
23	KITCHEN MISC.	NEquipment	500	20 1	C	20 1	600	NEquipment			SECURITY GATE	24
25	SPARE	SPARE	0	20 1	A	20 1	500	NEquipment			GARAGE DISPOSAL	26
27	SPARE	SPARE	0	20 1	B	20 1	0	SPARE			SPARE	28
29	SPARE	SPARE	0	20 1	C	20 1	0	SPARE			SPARE	30
31					A							32
33					B							34
35					C							36
37					A							38
39					B							40
41					C							42
ALL CONNECTED KVA AMPS * PHASE TOTALS VA AMPS BUS TOTALS KVA												
TOTAL CONNECTED			20.36	56.5	* A-N	7697.4	64.1	9	CONNECTED	25.32		
TOTAL DEMAND			20.36	56.5	* B-N	7424.9	61.8	9	DEMAND	25.32		
TOTAL DESIGN			20.36	56.5	* C-N	5640.4	47.0	9	DESIGN	25.68		